

**WILLIAM J. CLINTON
PRESIDENTIAL
CENTER**

LITTLE ROCK, ARKANSAS

Architect
POLSHEK PARTNERSHIP LLP
320 West 13th Street
New York, New York 10014
212.607.7171

Coordinating Architects
POLK STANLEY YEARY ARCHITECTS Ltd
700 South Schaller Street
Little Rock, Arkansas 72201
501.378.0878

WITSELL EVANS RASCO
901 West Third Street
Little Rock, Arkansas 72201
501.374.5300

WOODS CARADINE ARCHITECTS
2200 South Main Street
Little Rock, Arkansas 72206
501.374.4300

Landscape Architects
HARGREAVES ASSOCIATES
118 Maguire Street
Cambridge, Massachusetts 02139
617.661.0070

LANDSCAPE ARCHITECTURE, Inc.
2309 Cotuit Lane Suite 202
Little Rock, Arkansas 72202
501.374.5810

Structural Engineer
LESLIE E. ROBERTSON ASSOC. P.C.
30 Broad Street 47th Floor
New York, New York 10004
212.759.9000


MEP Engineers
FLACK + KURTZ Inc.
475 Fifth Avenue
New York, New York 10017
212.532.9900

CROMWELL ARCHITECTS ENGINEERS
101 South Spring Street
Little Rock, Arkansas 72201
501.372.2300

Outfall Consultant
R. A. HEINTGES ARCHITECTS
128 Fifth Avenue 9th Floor
New York, New York 10011
212.652.2966



100% Construction Documents	09/27/02
90% Progress Permitting	08/30/02
100% Design Development	03/01/02
Issue	Date

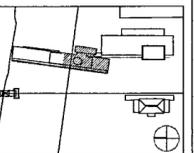


Job No: POLSHEK & PARTNERS ARCH. 0906
CROMWELL AE 99-114
Scale: 1/8" = 1'-0"
Date: SEPTEMBER 27, 2002

Title: **BASEMENT LEVEL
AREA B
POWER PLAN**

Sheet No. **E100b**



- KEYED NOTES**
- ◇ COORDINATE J-BOXES AND FLEX CONDUIT WITH EXACT LOCATION OF (4) COMPRESSORS
 - ◇ SEE ELECTRICAL SINGLE LINE DIAGRAM FOR CIRCUIT INFORMATION
 - ◇ COORDINATE LOCATION OF HAND DRYER

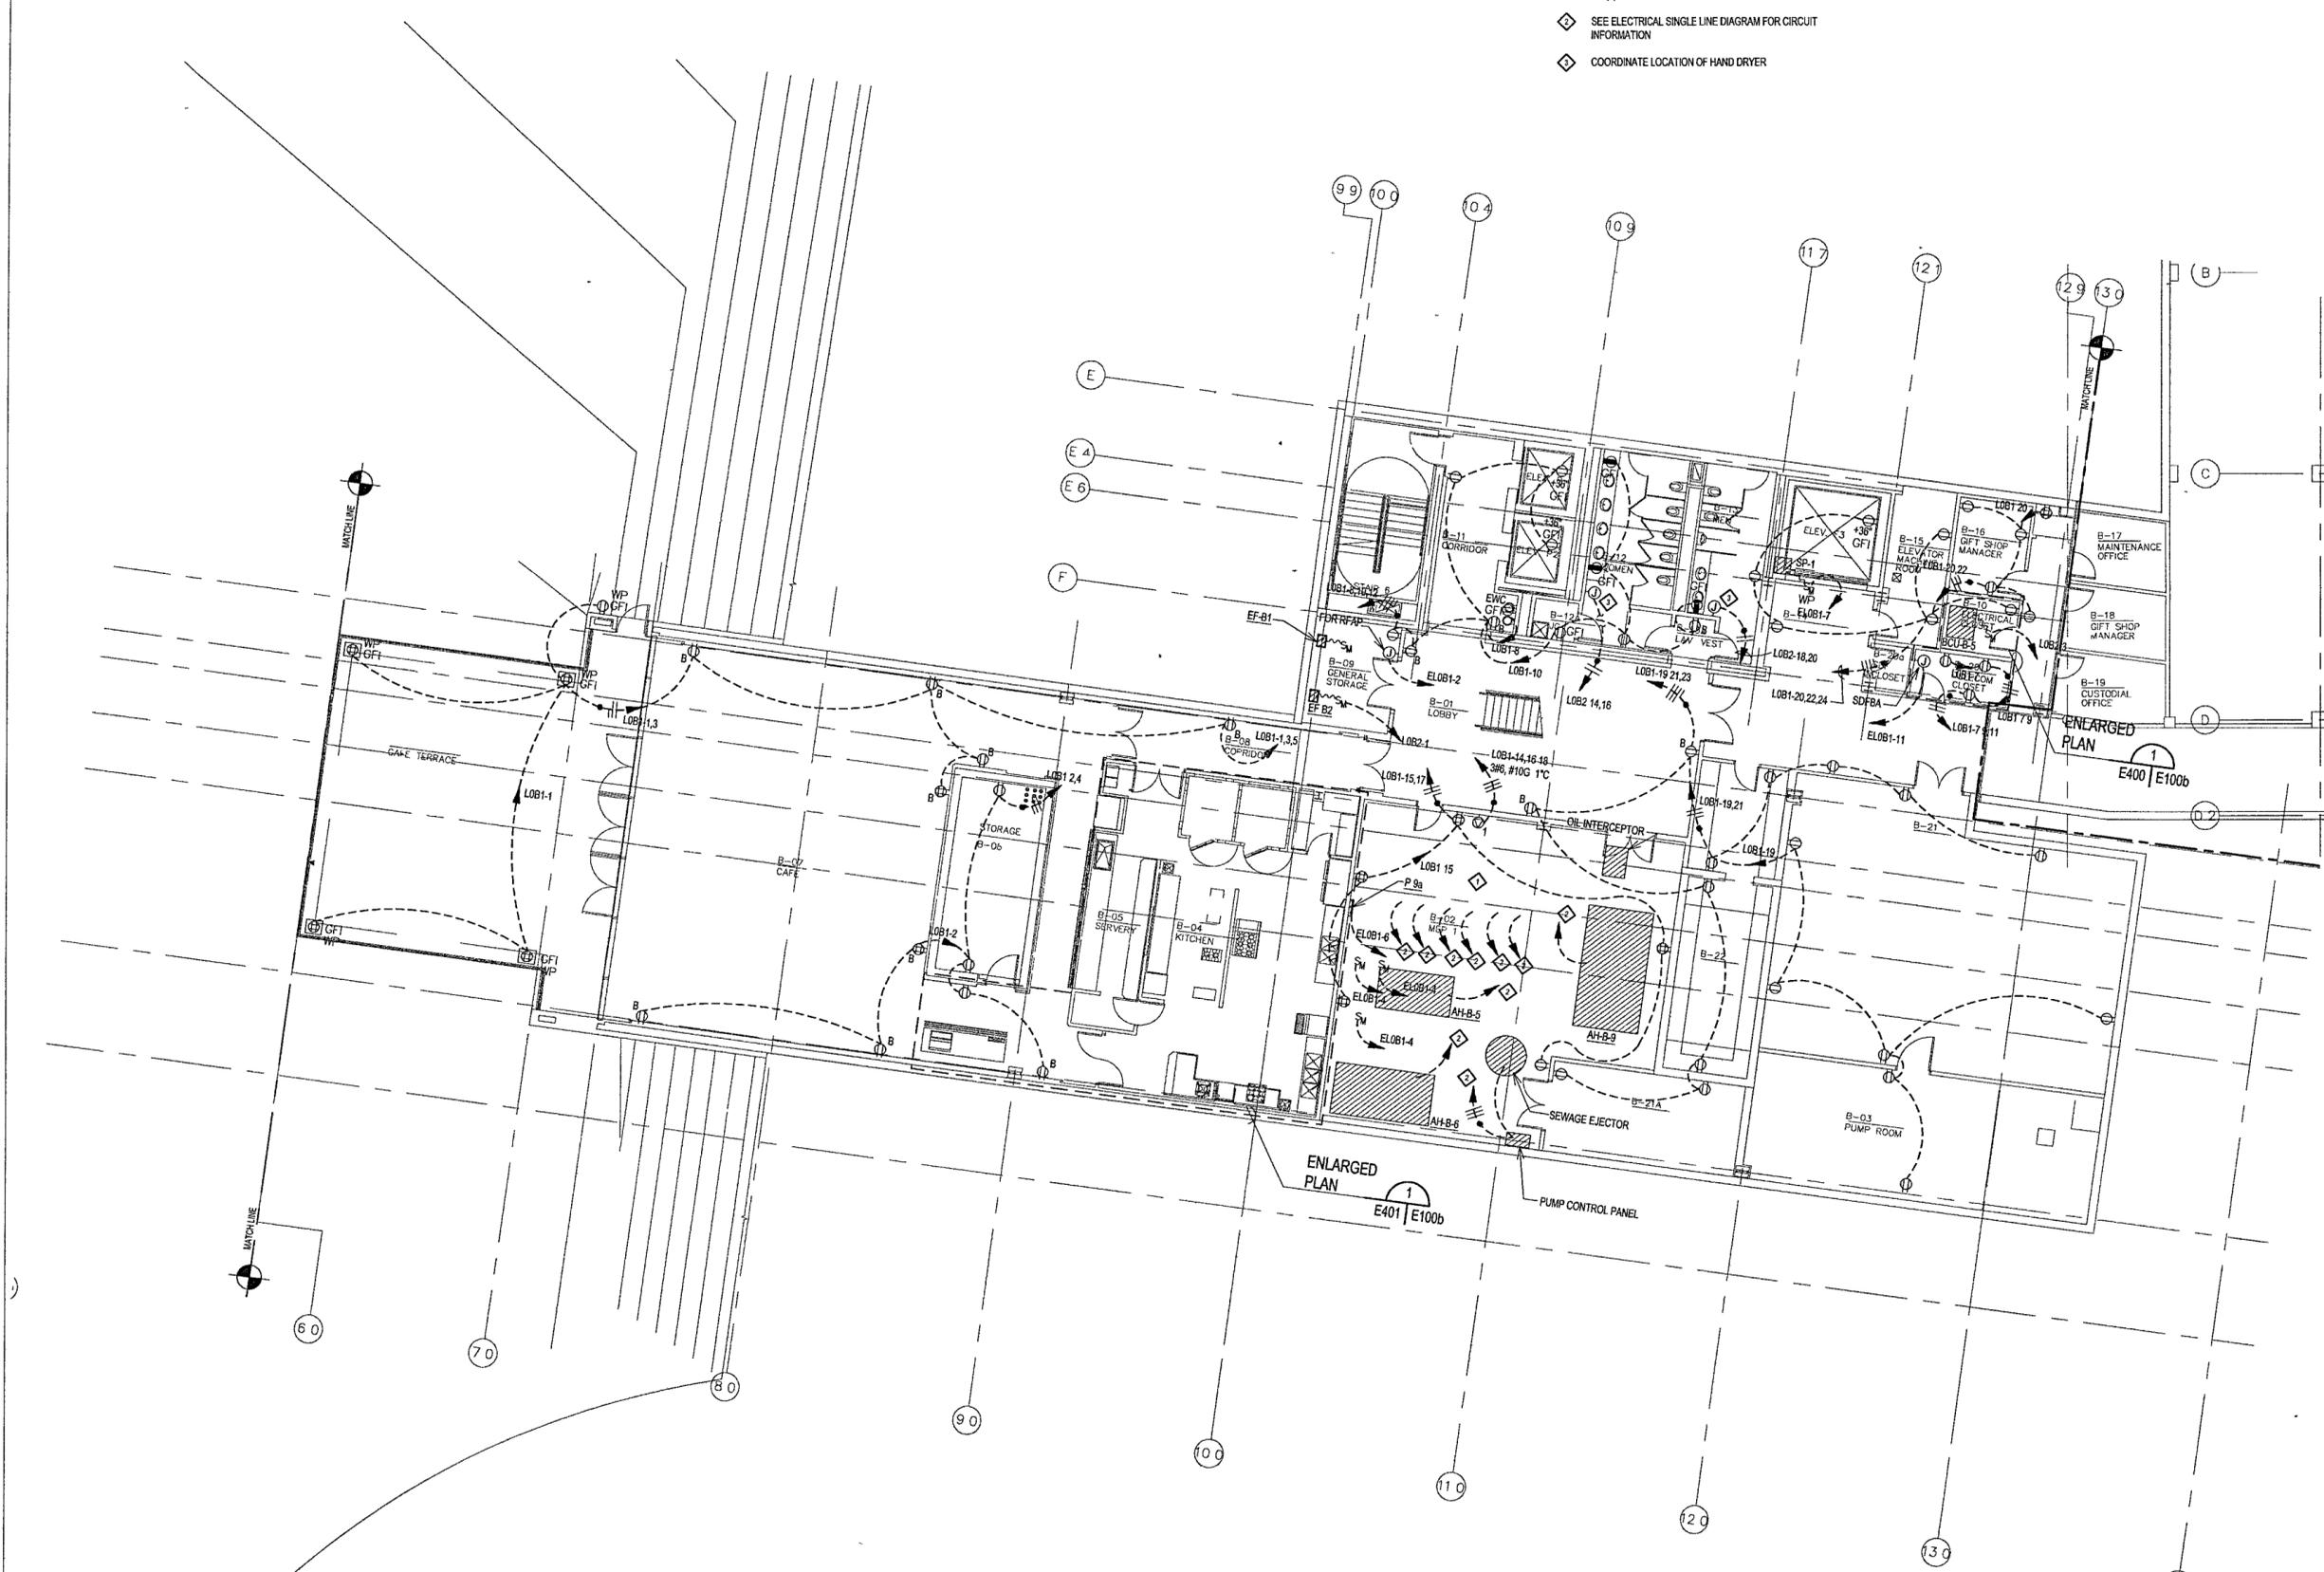

1 BASEMENT LEVEL AREA B POWER PLAN
E100b | E100b 1/8" = 1'-0"

