

**WILLIAM J CLINTON
PRESIDENTIAL
CENTER**

LITTLE ROCK ARKANSAS

Architect
POLSHEK PARTNERSHIP LLP
320 West 13th Street
New York, New York 10014
212.807.7171

Coordinating Architects
POLK STANLEY YEARY ARCHITECTS, Ltd
700 South Schiller Street
Little Rock, Arkansas 72201
501.378.0878

WITSELL EVANS RASCO
901 West Third Street
Little Rock, Arkansas 72201
501.374.5300

WOODS CARADINE ARCHITECTS
2200 South Main Street
Little Rock, Arkansas 72206
501.374.4008

Landscape Architects
HARGREAVES ASSOCIATES
118 Magalloway Street
Cambridge, Massachusetts 02139
617.691.0070


LANDSCAPE ARCHITECTURE, Inc.
2300 Cottingham Lane Suite 202
Little Rock, Arkansas 72202
501.374.5610

Structural Engineer
LESLIE E ROBERTSON ASSOC. RLLP
30 Broad Street, 4th Floor
New York, New York 10004
212.750.9000


MEP Engineers
FLACK + KURTZ Inc.
475 Fifth Avenue
New York, New York 10017
212.532.9600

CROMWELL ARCHITECTS ENGINEERS
101 South Spring Street
Little Rock, Arkansas 72201
501.372.2900

Curriculum Consultant
R. A. HENTGES ARCHITECTS
105 Fifth Avenue 9th Floor
New York, New York 10011
212.652.2966

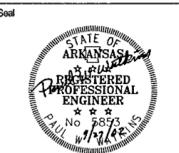

Issue	Date
100% Construction Document	09/27/02
90% Progress Printing	08/30/02
100% Design Development	03/01/02

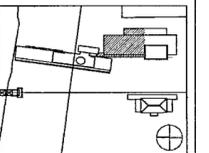


Job No: POLSHEK & PARTNERS ARCH. 9908
CROMWELL AE 99-114
Scale: 1/8" = 1'-0"
Date: SEPTEMBER 27, 2002

**BASEMENT LEVEL
AREA C
POWER PLAN**

Sheet No. **E100c**



FOR OFFICIAL USE ONLY

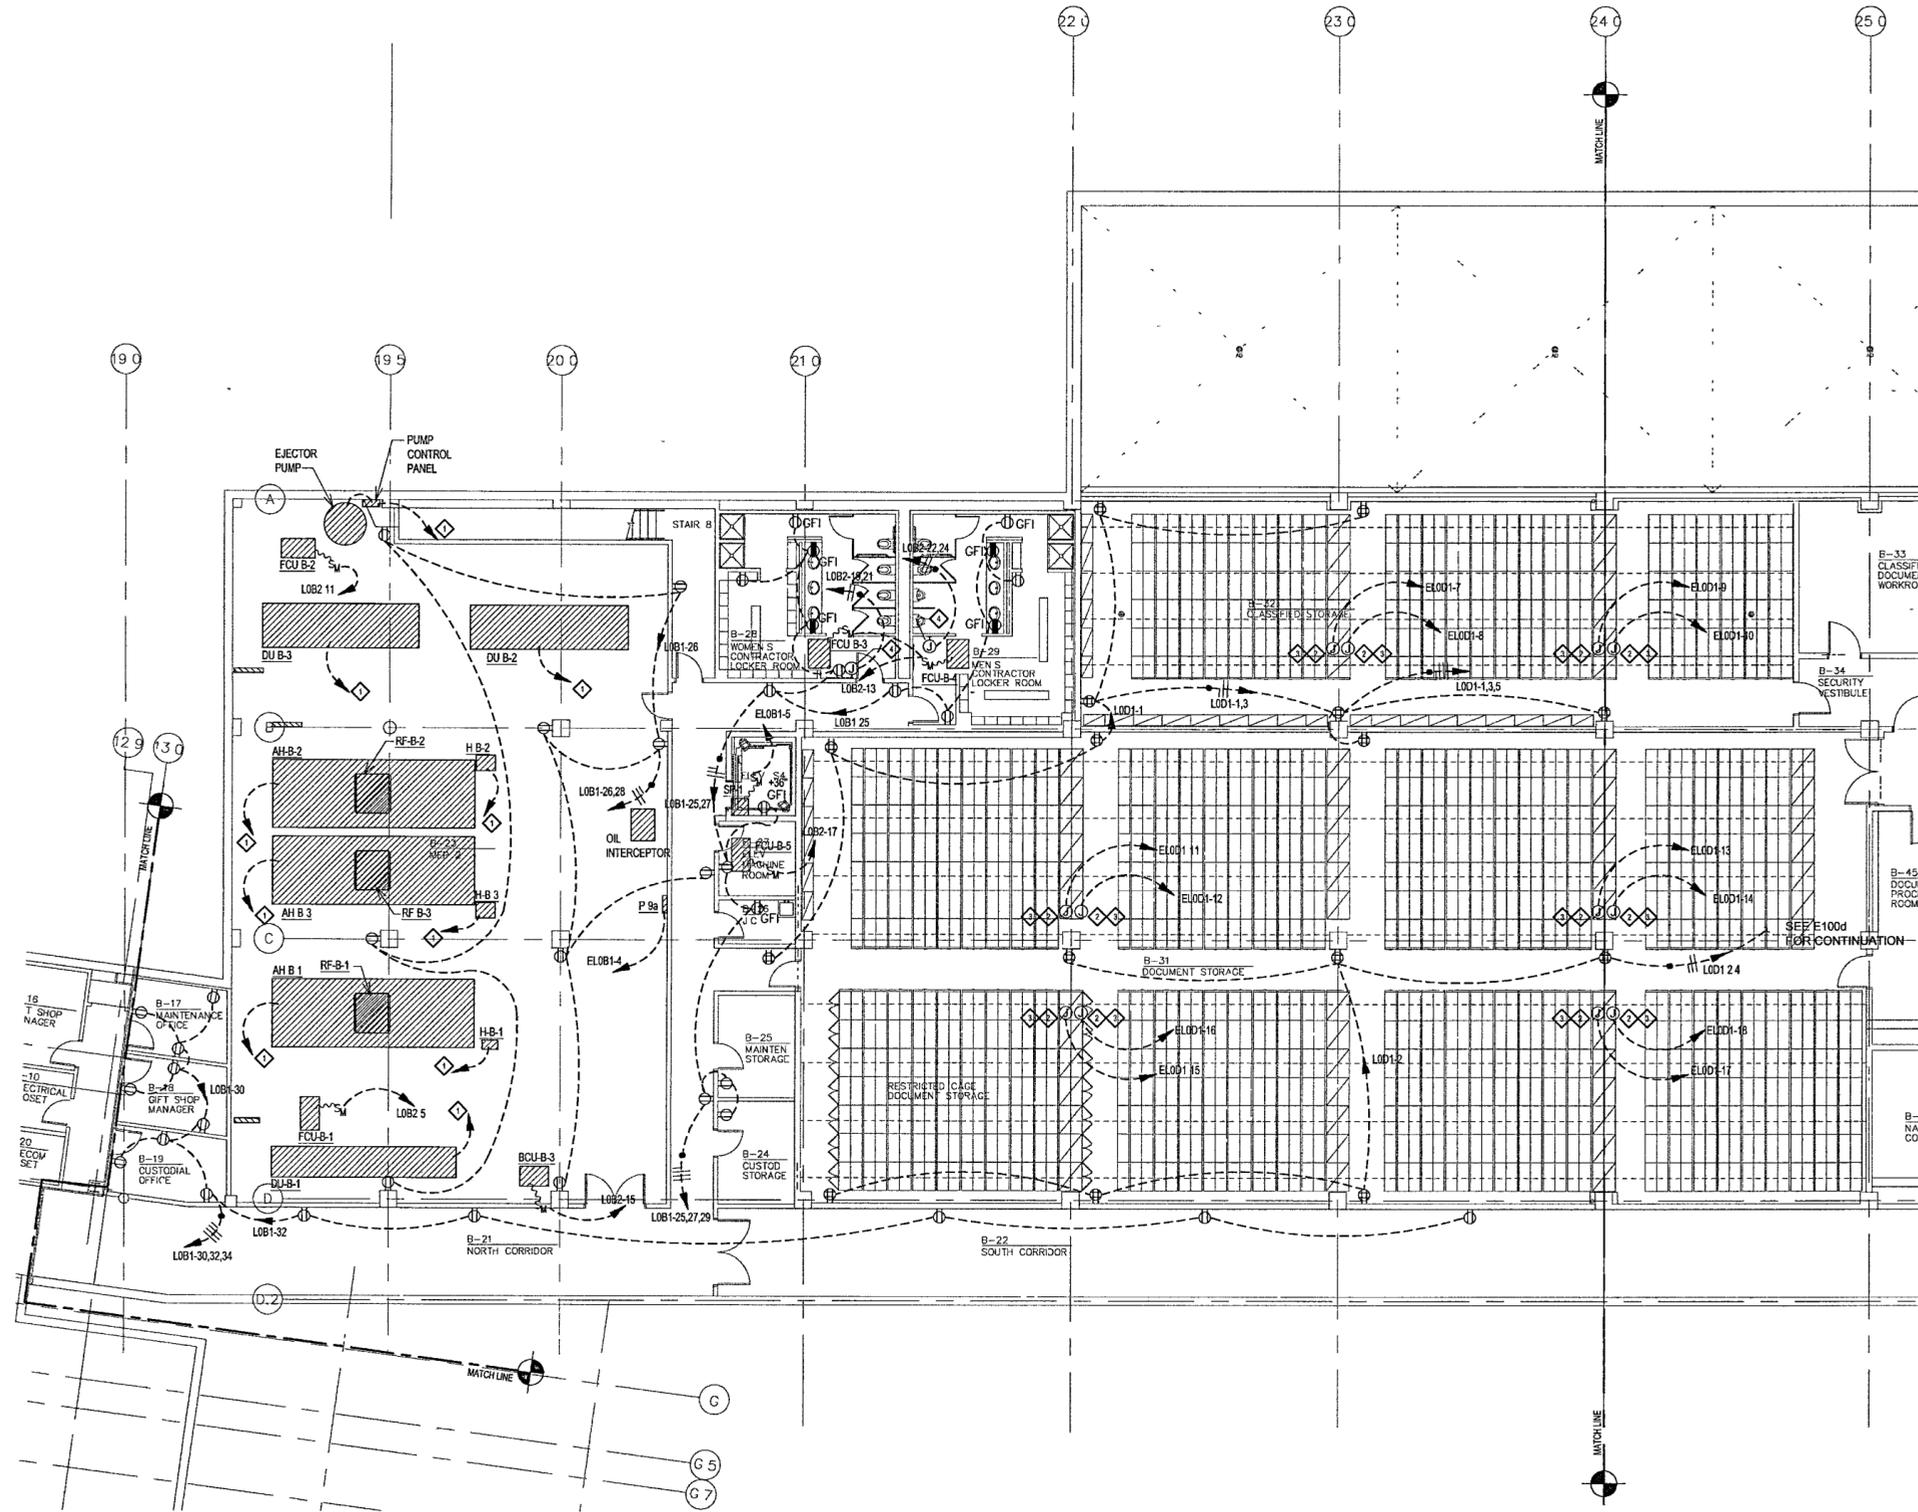

KEY NOTES

- ◆ SEE ELECTRICAL SINGLE LINE DIAGRAM FOR CIRCUIT INFORMATION
- ◆ PROVIDE TWO 1" CONDUITS FROM EACH DOCUMENT STORAGE MODULE TO FIRE ALARM PANEL AND ONE TO BMS DRY CONTACT INTERFACE
- ◆ THESE J-BOXES ARE CEILING MOUNTED FOR LATER CONNECTION TO THE HIGH DENSITY STORAGE SYSTEM MODULES, COORDINATED WITH EXACT LOCATIONS OF SYSTEM ELECTRONICS
- ◆ COORDINATE LOCATION OF HAND DRYER

1 BASEMENT LEVEL AREA C POWER PLAN
E100c | E100c 1/8" = 1'-0"
0 4' 8' 16' 24'