

**WILLIAM J CLINTON
PRESIDENTIAL
CENTER**

LITTLE ROCK, ARKANSAS

Architect
POLSHK PARTNERSHIP LLP
320 West 13th Street
New York, New York 10014
212.807.7171

Coordinating Architects
POLK STANLEY YEARY ARCHITECTS, Ltd
700 South Schuler Street
Little Rock, Arkansas 72201
501.378.0878

WITSELL EVANS RASCO
901 West Third Street
Little Rock, Arkansas 72201
501.374.5300

WOODS CARADINE ARCHITECTS
2200 South Main Street
Little Rock, Arkansas 72206
501.374.4060

Landscape Architects
HARGREAVES ASSOCIATES
118 Magazine Street
Cambridge, Massachusetts 02139
617.861.0070

LANDSCAPE ARCHITECTURE, Inc.
2300 Cottondale Lane Suite 202
Little Rock, Arkansas 72202
501.374.5610

Structural Engineer
LESLIE E. ROBERTSON ASSOC. R.L.P.
30 Broad Street, 4th Floor
New York, New York 10004
212.750.9000

MEP Engineers
FLACK + KURTZ Inc.
475 Fifth Avenue
New York, New York 10017
212.532.9600


CROMWELL ARCHITECTS ENGINEERS
101 South Spring Street
Little Rock, Arkansas 72201
501.372.2300

Curtilwall Consultant
R. A. HEINTGES ARCHITECTS
126 Fifth Avenue, 9th Floor
New York, New York 10011
212.652.2965

Seal



Issue	Date
100% Construction Documents	09/27/02
90% Progress Printing	08/30/02
100% Design Development	03/01/02

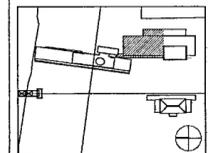

Job No. POLSHK & PARTNERS ARCH 9908
CROMWELL AE 99-114

Scale: 1/8" = 1'-0"

Date: SEPTEMBER 27, 2002

Title:


**GROUND LEVEL
AREA C
POWER PLAN**

Sheet No.

E101c



FOR OFFICIAL USE ONLY

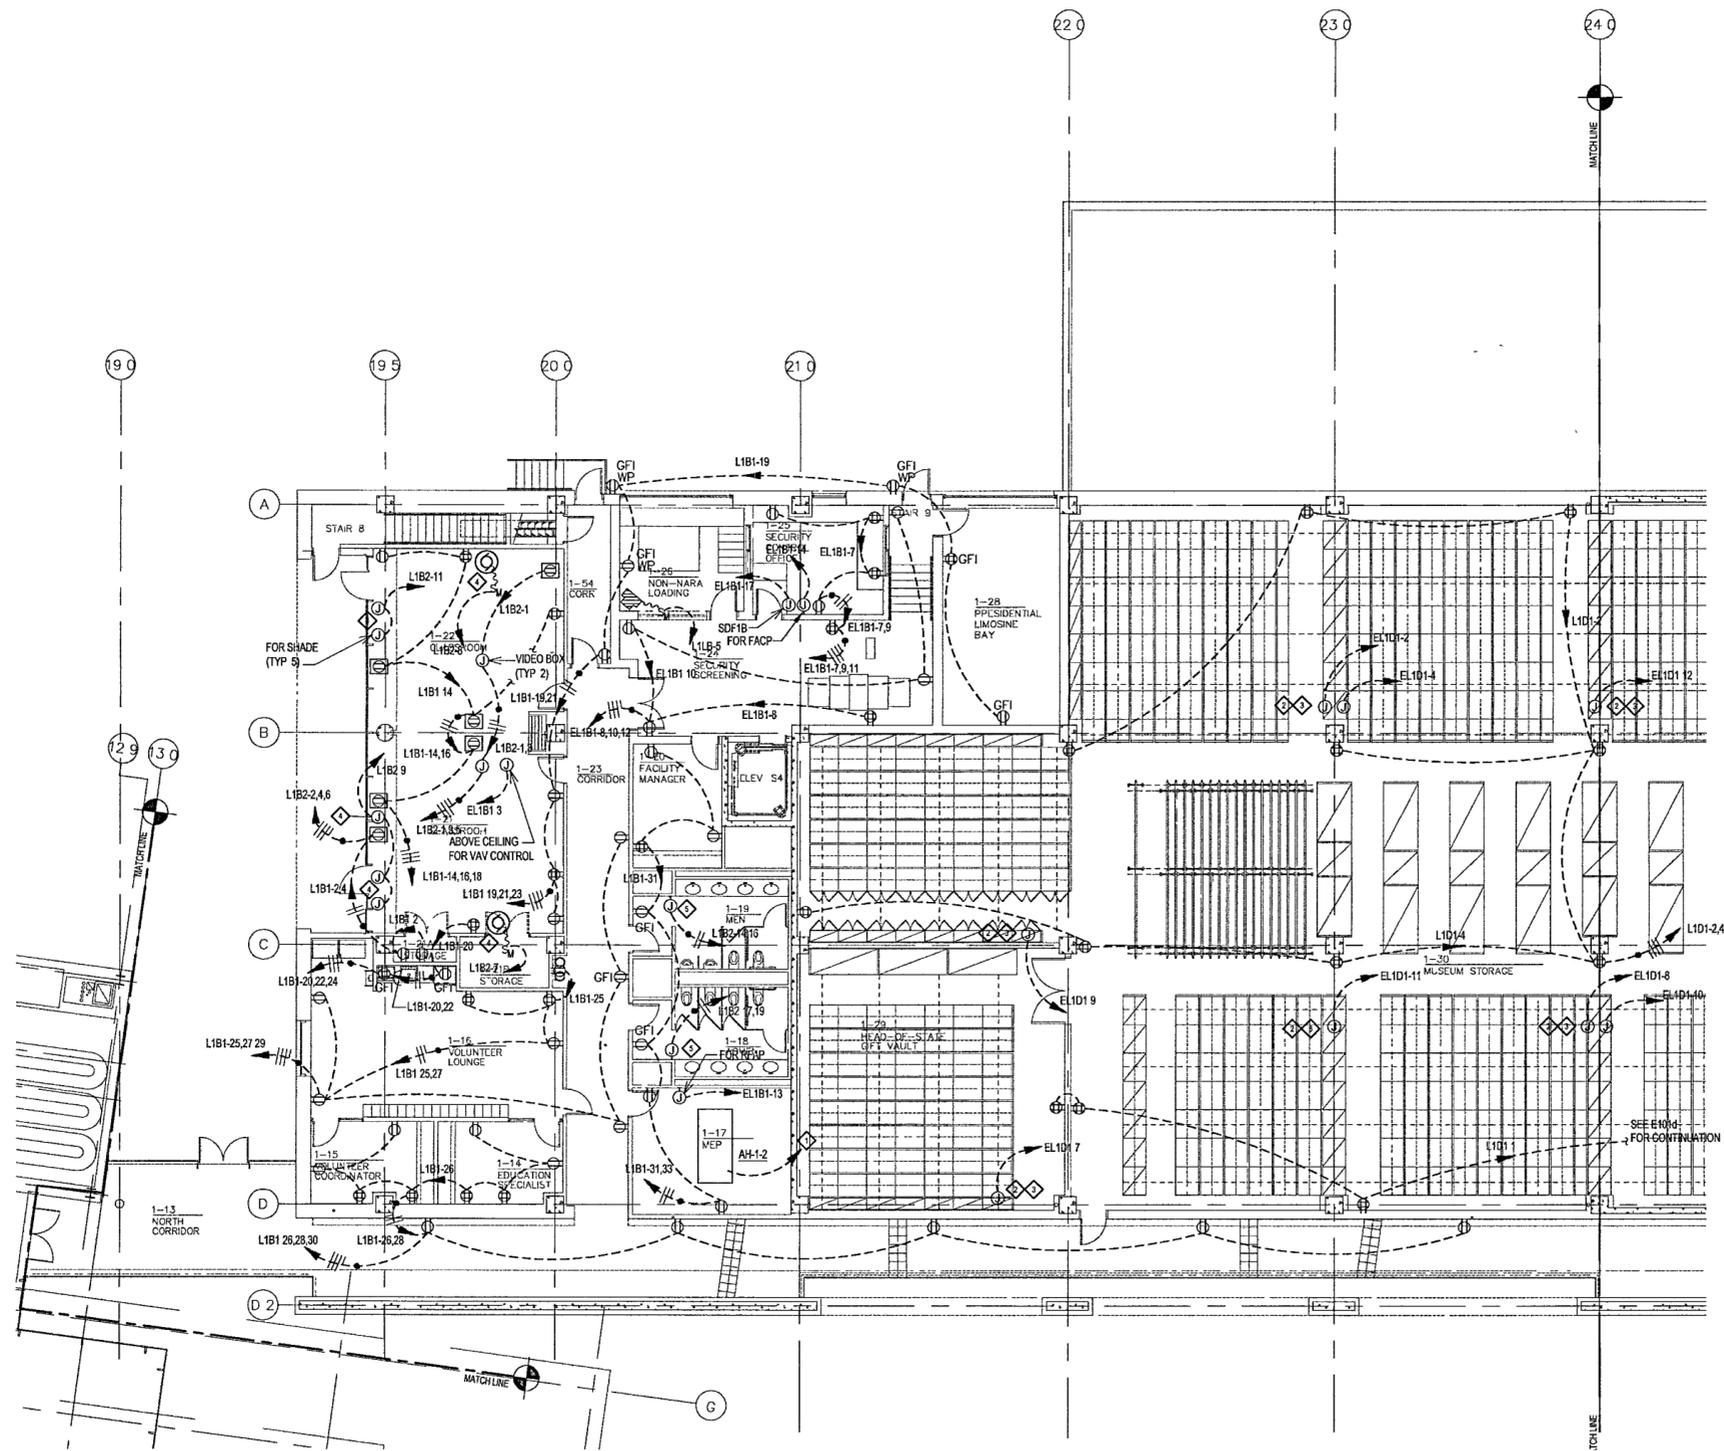

- KEYED NOTES**
- ◆ SEE ELECTRICAL SINGLE LINE DIAGRAM FOR CIRCUIT INFORMATION
 - ◆ THESE J-BOXES ARE CEILING MOUNTED FOR LATER CONNECTION TO THE HIGH DENSITY STORAGE SYSTEM MODULES, COORDINATED WITH EXACT LOCATION OF SYSTEM ELECTRONICS
 - ◆ PROVIDE TWO 1" CONDUITS FROM EACH DOCUMENT STORAGE MODULE TO FIRE ALARM PANEL AND ONE TO BMS DRY CONTACT INTERFACE
 - ◆ MOUNT SWITCH FOR SCREENSHADE WITH LIGHT SWITCHES
 - ◆ COORDINATE LOCATION OF HAND DRYER.

1 GROUND LEVEL AREA C POWER PLAN
E101c | E101c 1/8" = 1'-0"
0 4 8 16 24
NORTH

459