

LITTLE ROCK, ARKANSAS

Architect
POLSHEK PARTNERSHIP LLP
320 West 128 Street
New York, New York 10014
212 807 7171

Coordinating Architects
POLK STANLEY YEARY ARCHITECTS Ltd
700 South Schiller Street
Little Rock, Arkansas 72201
501 378 0878

WITSELL EVANS RASCO
901 West Third Street
Little Rock, Arkansas 72201
501 374 5300

WOODS CARADINE ARCHITECTS
2200 South Main Street
Little Rock, Arkansas 72206
501 374 4060

Landscape Architects
HARGREAVES ASSOCIATES
118 Magazine Street
Cambridge, Massachusetts 02139
617 651 0070


LANDSCAPE ARCHITECTURE, Inc.
2300 Cottondale Lane Suite 202
Little Rock, Arkansas 72202
501 374 5810

Structural Engineer
LESLIE E. ROBERTSON ASSOC. RLLP
33 Broad Street, 47th Floor
New York, New York 10004
212 750 9000


MEP Engineers
FLACK + KURTZ Inc.
475 Fifth Avenue
New York, New York 10017
212 532 9600

CROMWELL ARCHITECTS ENGINEERS
101 South Spring Street
Little Rock, Arkansas 72201
501 372 2900

Curtainwall Consultant
R. A. HEINTGES ARCHITECTS
128 Fifth Avenue, 9th Floor
New York, New York 10011
212 652 2566

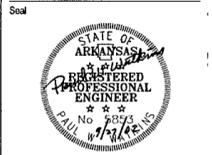


100% Construction Document	09/27/02
90% Progress Printing	08/30/02
100% Design Development	03/01/02
Issue	Date

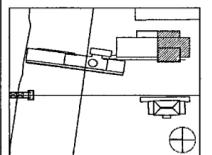


Job No POLSHEK & PARTNERS ARCH 9008
CROMWELL AE 99-114
Scale 1/8" = 1'-0"
Date SEPTEMBER 27, 2002
Title

**GROUND LEVEL
AREA D
POWER PLAN**

 Sheet No
E101d



- KEYED NOTES**
- ◆ SEE ELECTRICAL SINGLE LINE DIAGRAM FOR CIRCUIT INFORMATION
 - ◆ THESE J BOXES ARE CEILING MOUNTED FOR LATER CONNECTION TO THE HIGH DENSITY STORAGE SYSTEM MODULES, COORDINATED WITH EXACT LOCATION OF SYSTEM ELECTRONICS
 - ◆ PROVIDE TWO 1" CONDUITS FROM EACH DOCUMENT STORAGE MODULE TO FIRE ALARM PANEL AND ONE TO BMS DRY CONTACT INTERFACE
 - ◆ COORDINATE LOCATION OF HAND DRYER.

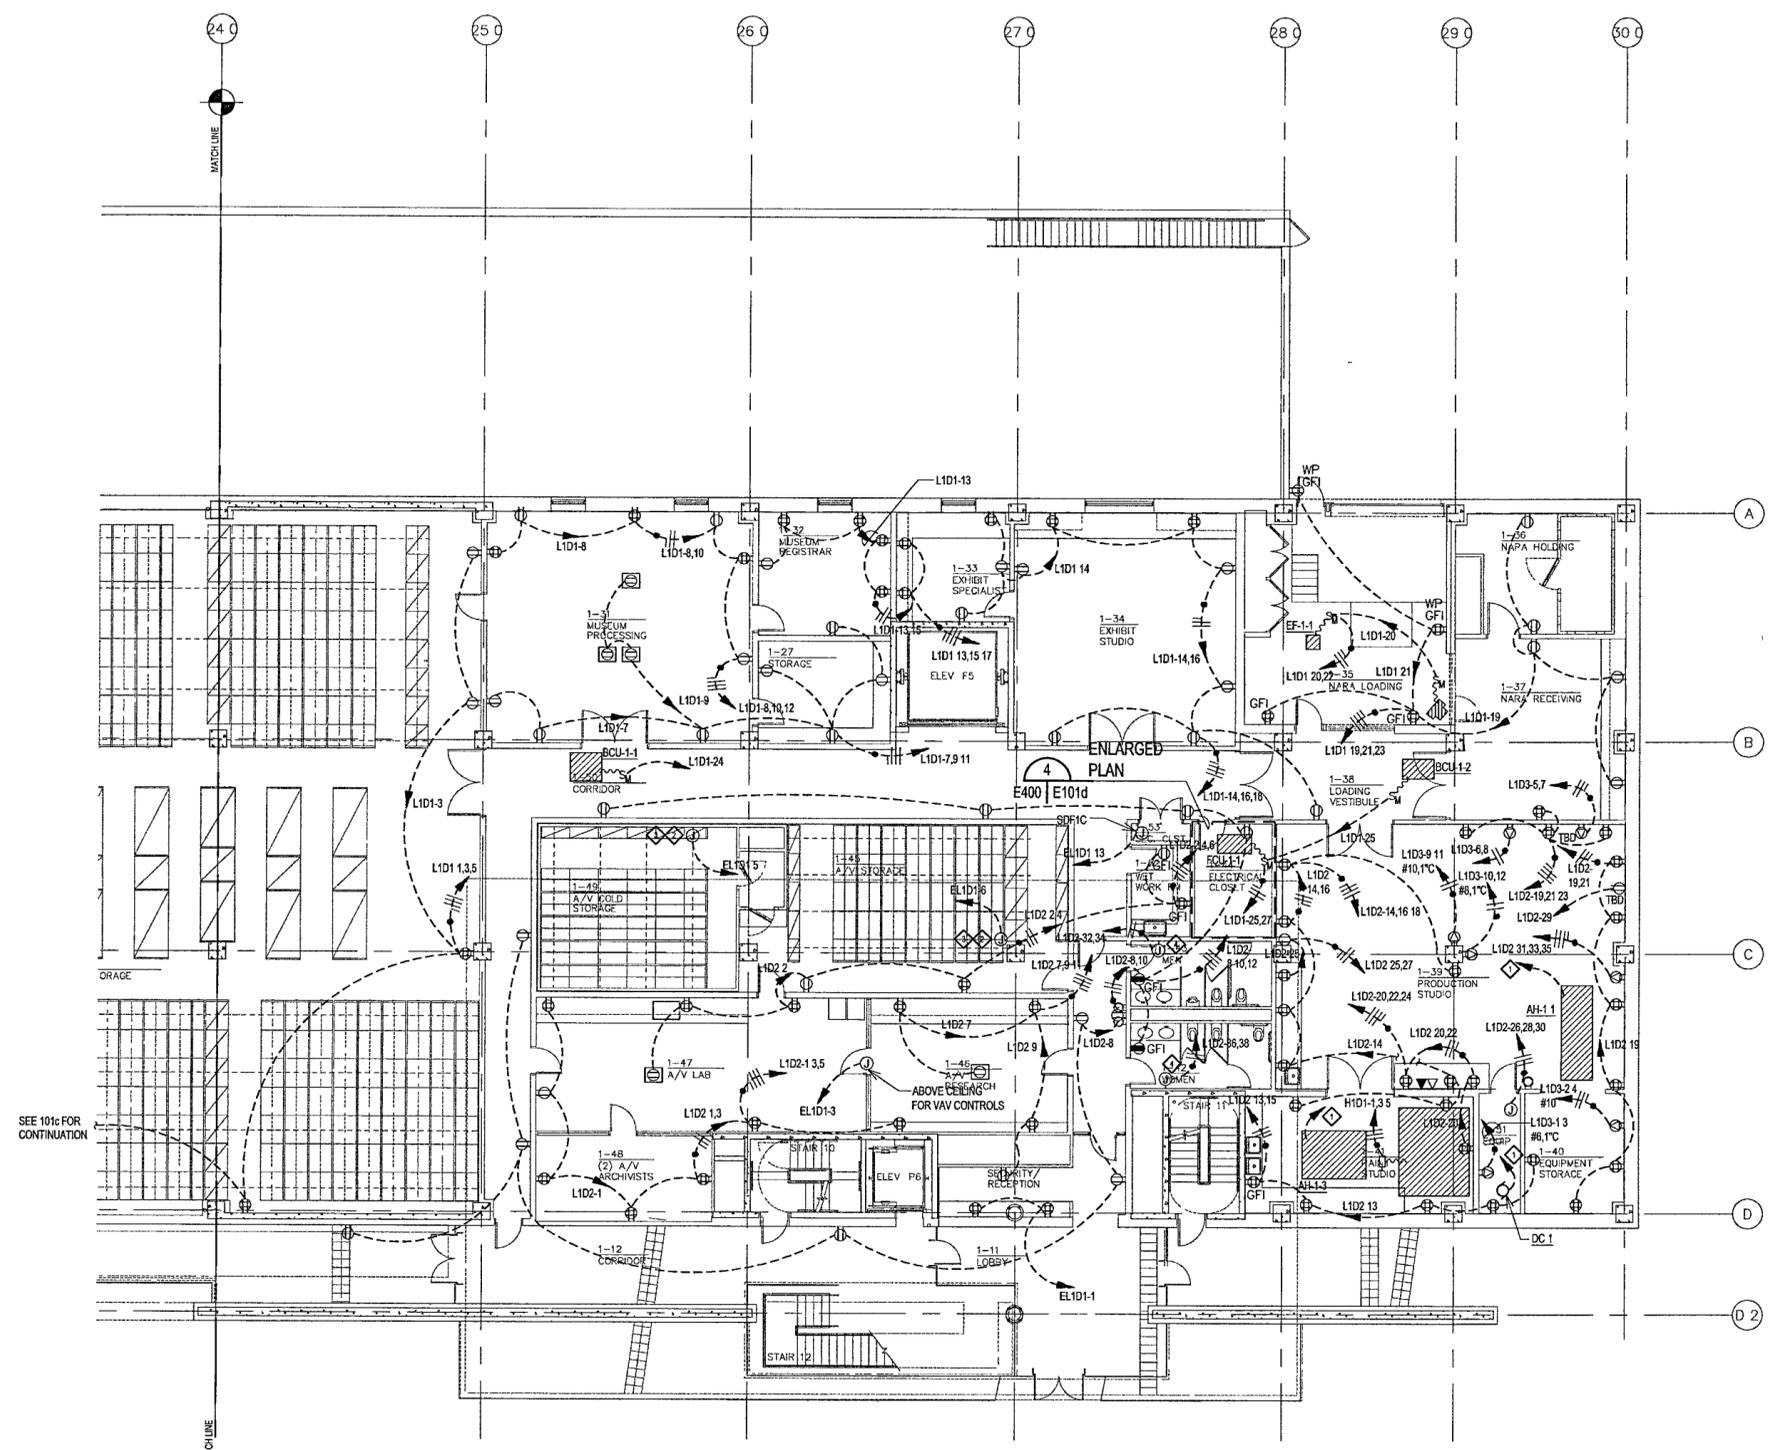

1 GROUND LEVEL AREA D POWER PLAN
E101d | E101d 1/8" = 1'-0"
NORTH



907