

**WILLIAM J. CLINTON
PRESIDENTIAL
CENTER**

LITTLE ROCK, ARKANSAS

Architect
POLSHEK PARTNERSHIP LLP
320 West 13th Street
New York, New York 10014
212 807 7171

Coordinating Architects
POLK STANLEY YEARY ARCHITECTS Ltd
700 South Schiller Street
Little Rock, Arkansas 72201
501.378.0878

WITSELL EVANS RASCO
501 West Third Street
Little Rock, Arkansas 72201
501 374 5300

WOODS CARADINE ARCHITECTS
2208 South Nam Street
Little Rock, Arkansas 72206
501 374 4050

Landscape Architects
HARGREAVES ASSOCIATES
118 Magazine Street
Cambridge, Massachusetts 02139
617 661 0070

LANDSCAPE ARCHITECTURE, Inc.
2300 Cottondale Lane Suite 202
Little Rock, Arkansas 72202
501 374 5610

Structural Engineer
LESLIE E. ROBERTSON ASSOC. R.L.P.
30 Broad Street, 4th Floor
New York, New York 10004
212 550 9000


MEP Engineers
FLACK + KURTZ Inc.
475 Fifth Avenue
New York, New York 10017
212 532 9600

CROMWELL ARCHITECTS ENGINEERS
151 South Spring Street
Little Rock, Arkansas 72201
501 372 2900

Curianwell Consultant
R. A. HEINTGES ARCHITECTS
126 Fifth Avenue, 9th Floor
New York, New York 10011
212 622 2966




Issue	Date
100% Construction Documents	08/27/02
90% Progress Printing	08/30/02
100% Design Development	03/01/02

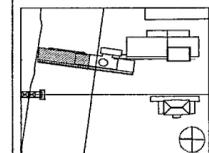


Job No: POLSHEK & PARTNERS ARCH-1 9908
CROMWELL AE 99-114
Scale: 1/8" = 1'-0"
Date: SEPTEMBER 27 2002

**SECOND LEVEL
AREA A
POWER PLAN**

 Sheet No.
E102a



KEYED NOTES
◆ SEE ELECTRICAL SINGLE LINE DIAGRAM FOR CIRCUIT INFORMATION

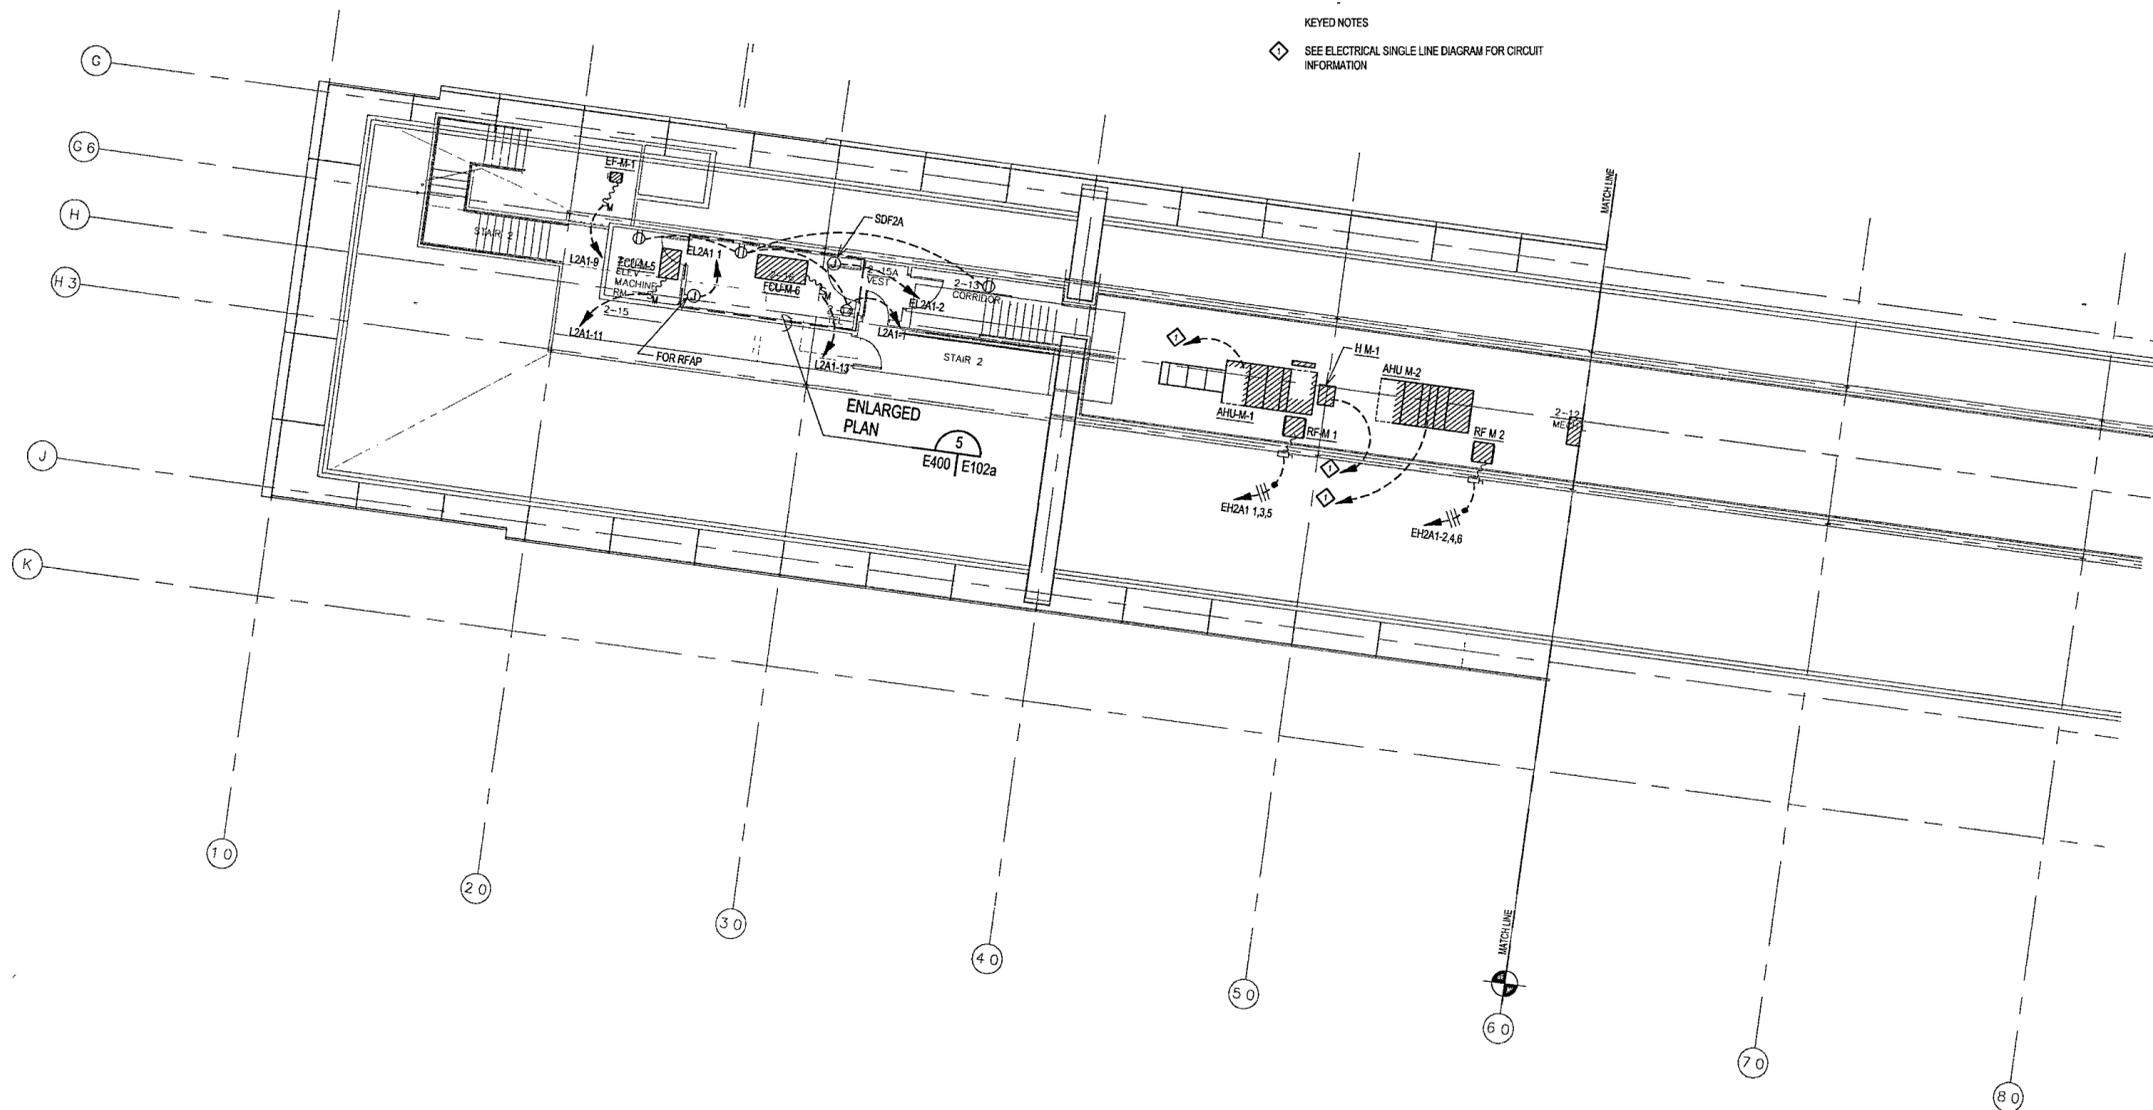

1 SECOND LEVEL AREA A POWER PLAN
E102a | E102a 1/8" = 1'-0"
0 4' 8' 16' 24'

