




Issue	Date
100% Construction Documents	09/27/02
90% Progress Printing	09/30/02
100% Design Development	03/01/02

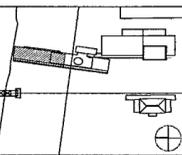

Job No POLSHEK & PARTNERS ARCH 9908
CROMWELL AE 99-114




Scale 1/8" = 1'-0"

Date SEPTEMBER 27, 2002


Title MUSEUM LOWER LEVEL AREA A POWER PLAN

Sheet No

E103a

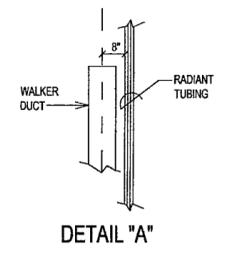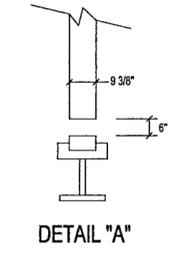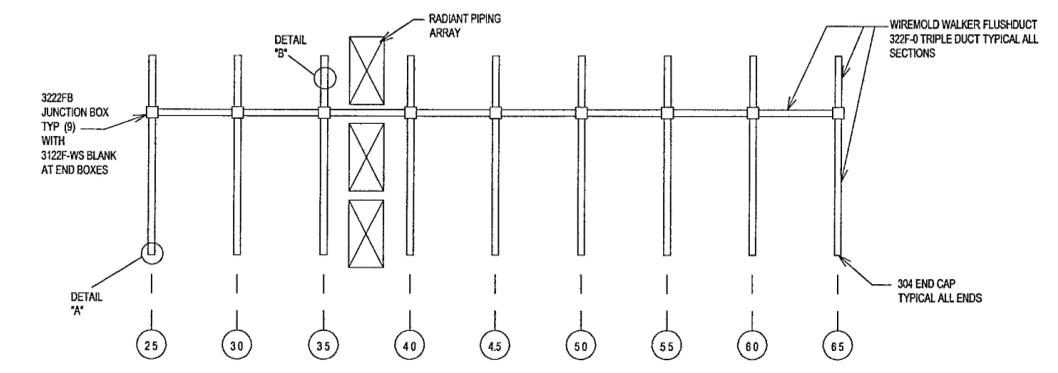

2 RADIANT FLOOR POWER DIAGM
E103a | E103a NTS

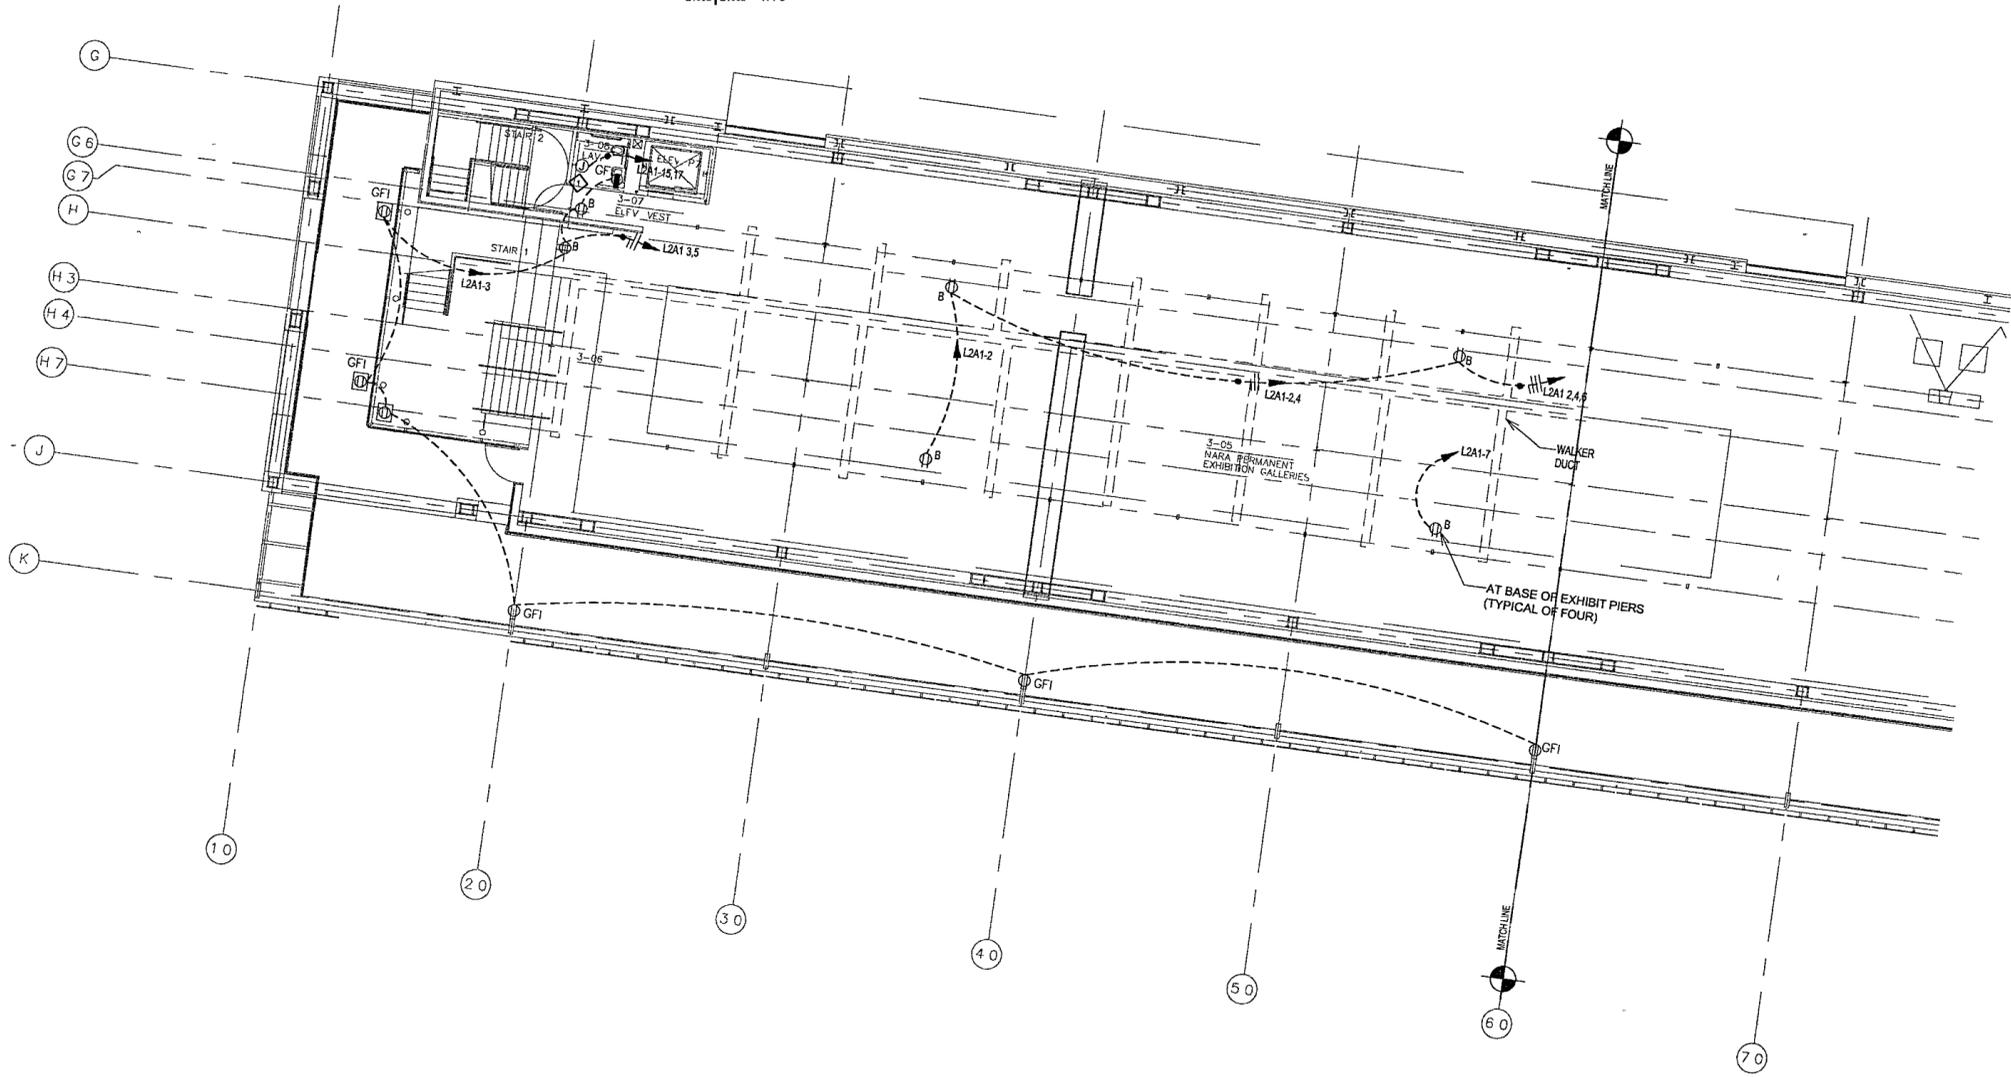

1 MUSEUM LOWER LEVEL AREA A POWER PLAN
E103a | E103a 1/8" = 1'-0"

