


KEYED NOTES
 ◆ COORDINATE LOCATION OF HAND DRYER

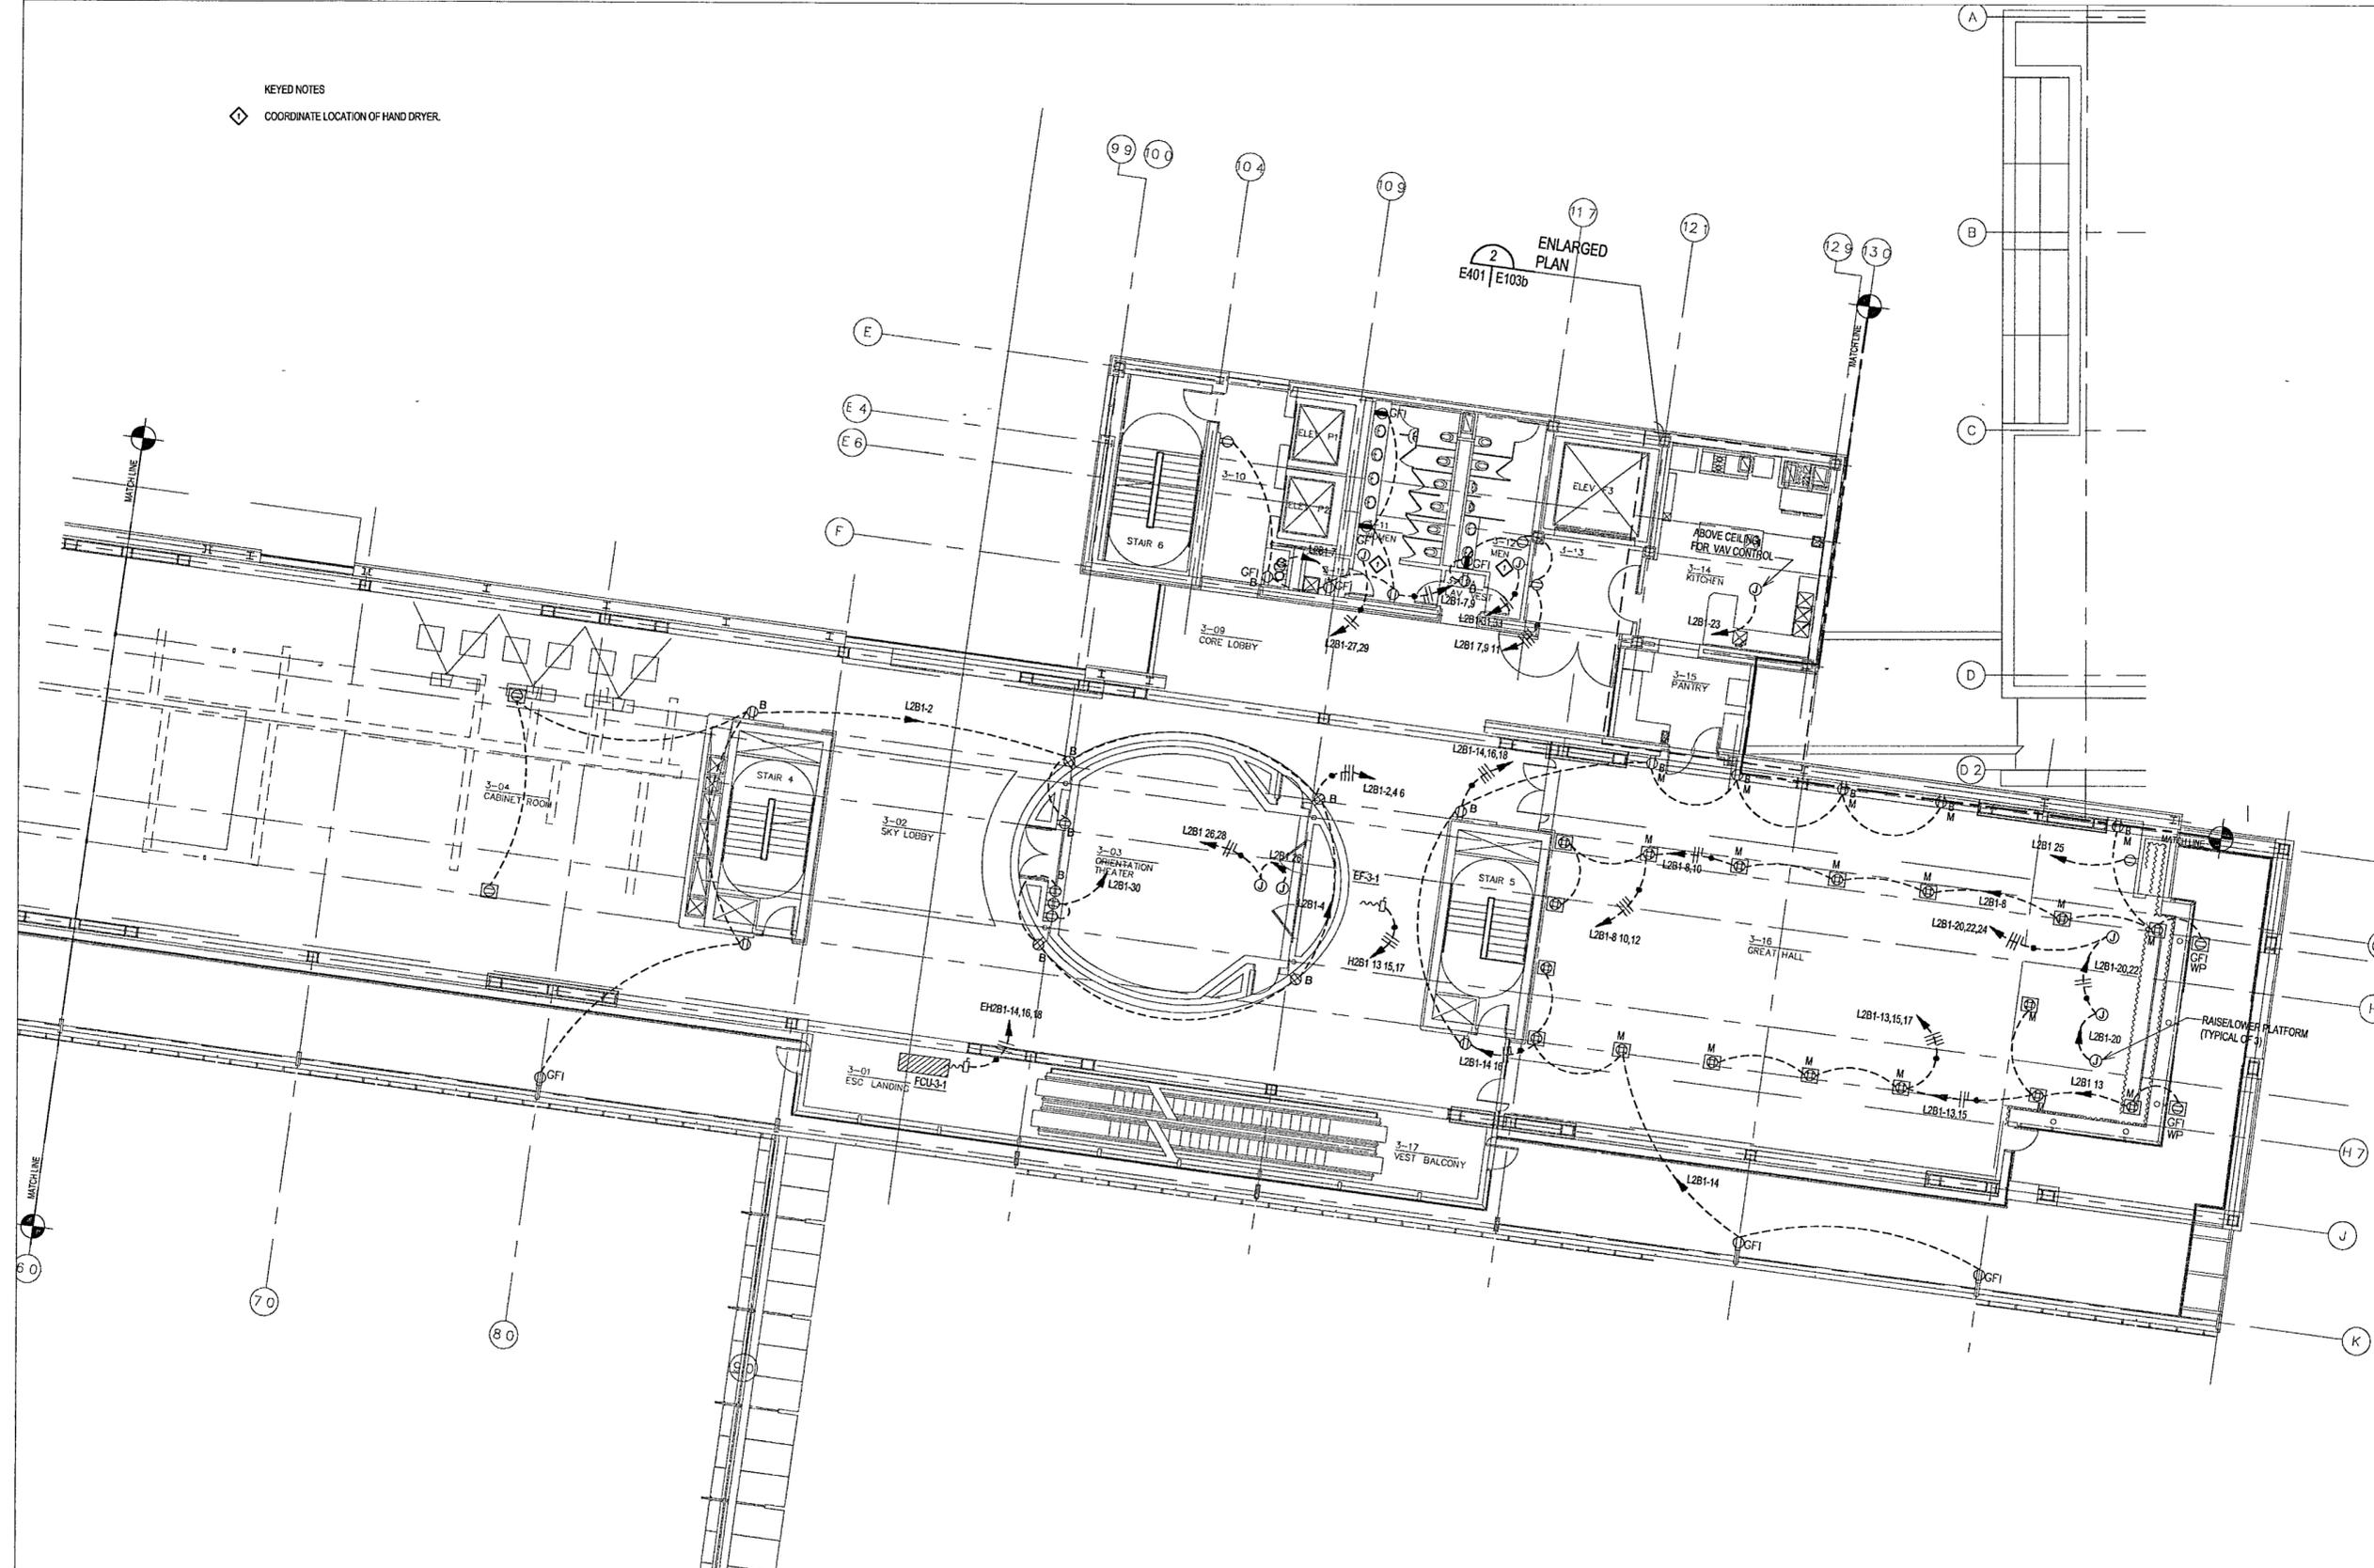

1 MUSEUM LOWER LEVEL AREA B POWER PLAN
 E103b E103b 1/8" = 1'-0"
 0 4 8 16 24
 NORTH

**WILLIAM J CLINTON
 PRESIDENTIAL
 CENTER**

LITTLE ROCK ARKANSAS

Architect
 POLSHEK PARTNERSHIP LLP
 320 West 13th Street
 New York, New York 10014
 212.807.7171

Coordinating Architects
 POLK STANLEY YEARY ARCHITECTS LM
 700 South Schiller Street
 Little Rock, Arkansas 72201
 501.378.0878

WITSELL EVANS RASCO
 901 West Third Street
 Little Rock, Arkansas 72201
 501.374.5300

WOODS CARADINE ARCHITECTS
 2200 South Main Street
 Little Rock, Arkansas 72206
 501.374.4060

Landscape Architects
 HARGREAVES ASSOCIATES
 118 Magazine Street
 Cambridge, Massachusetts 02138
 617.651.0070

LANDSCAPE ARCHITECTURE, Inc.
 2300 Cottondale Lane Suite 202
 Little Rock, Arkansas 72202
 501.374.5510

Structural Engineer
 LESLIE E ROBERTSON ASSOC RLP
 30 Broad Street 47th Floor
 New York, New York 10004
 212.750.8000


MEP Engineers
 FLACK + KURTZ Inc
 475 Fifth Avenue
 New York, New York 10017
 212.532.9000

CROMWELL ARCHITECTS ENGINEERS
 101 South Spring Street
 Little Rock, Arkansas 72201
 501.372.2900

Curtainwall Consultant
 R. A. HEINTGES ARCHITECTS
 126 Fifth Avenue 9th Floor
 New York, New York 10011
 212.632.2966



100% Construction Documents	09/27/02
90% Progress Planning	09/30/02
100% Design Development	03/01/02
Issue	Date

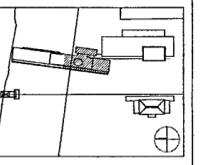

Job No POLSHEK & PARTNERS ARCH 9908
 CROMWELL AE 99-114

Scale 1/8" = 1'-0"

Date SEPTEMBER 27, 2002

Title
**MUSEUM
 LOWER LEVEL
 AREA B
 POWER PLAN**

Sheet No.
E103b



FOR OFFICIAL USE ONLY