

**WILLIAM J CLINTON
PRESIDENTIAL
CENTER**

LITTLE ROCK, ARKANSAS

Architect
POLSHEK PARTNERSHIP LLP
530 West 53rd Street
New York, New York 10014
212.807.7171

Coordinating Architects
POLK STANLEY YEARY ARCHITECTS Ltd
700 South Schiller Street
Little Rock, Arkansas 72201
501.378.0878

WITSELL EVANS RASCO
901 West Third Street
Little Rock, Arkansas 72201
501.374.5300

WOODS CARADINE ARCHITECTS
2200 South Main Street
Little Rock, Arkansas 72206
501.374.4060

Landscape Architects
HARGREAVES ASSOCIATES
118 Magazine Street
Cambridge Massachusetts 02139
617.691.0270

LANDSCAPE ARCHITECTURE, Inc.
2300 Cottondale Lane Suite 202
Little Rock, Arkansas 72202
501.374.5910

Structural Engineer
LESLIE E. ROBERTSON ASSOC. RLLP
30 Broad Street 4th Floor
New York, New York 10004
212.750.9000


MEP Engineers
FLACK + KURTZ Inc.
475 Fifth Avenue
New York, New York 10017
212.532.9000

CROMWELL ARCHITECTS ENGINEERS
101 South Spring Street
Little Rock, Arkansas 72201
501.372.2900

Curranwill Consultant
R. A. HEINTGES ARCHITECTS
126 Fifth Avenue, 8th Floor
New York, New York 10011
212.652.2966



Issue	Date
100% Construction Documents	09/27/02
90% Progress Planning	06/30/02
100% Design Development	03/01/02

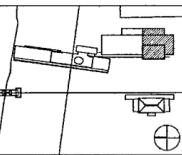


Job No POLSHEK & PARTNERS ARCH 9909
CROMWELL AE 99-114
Scale 1/8" = 1'-0"
Date SEPTEMBER 27, 2002

Title **MUSEUM
LOWER LEVEL
AREA D
POWER PLAN**

Sheet No **E103d**



FOR OFFICIAL USE ONLY

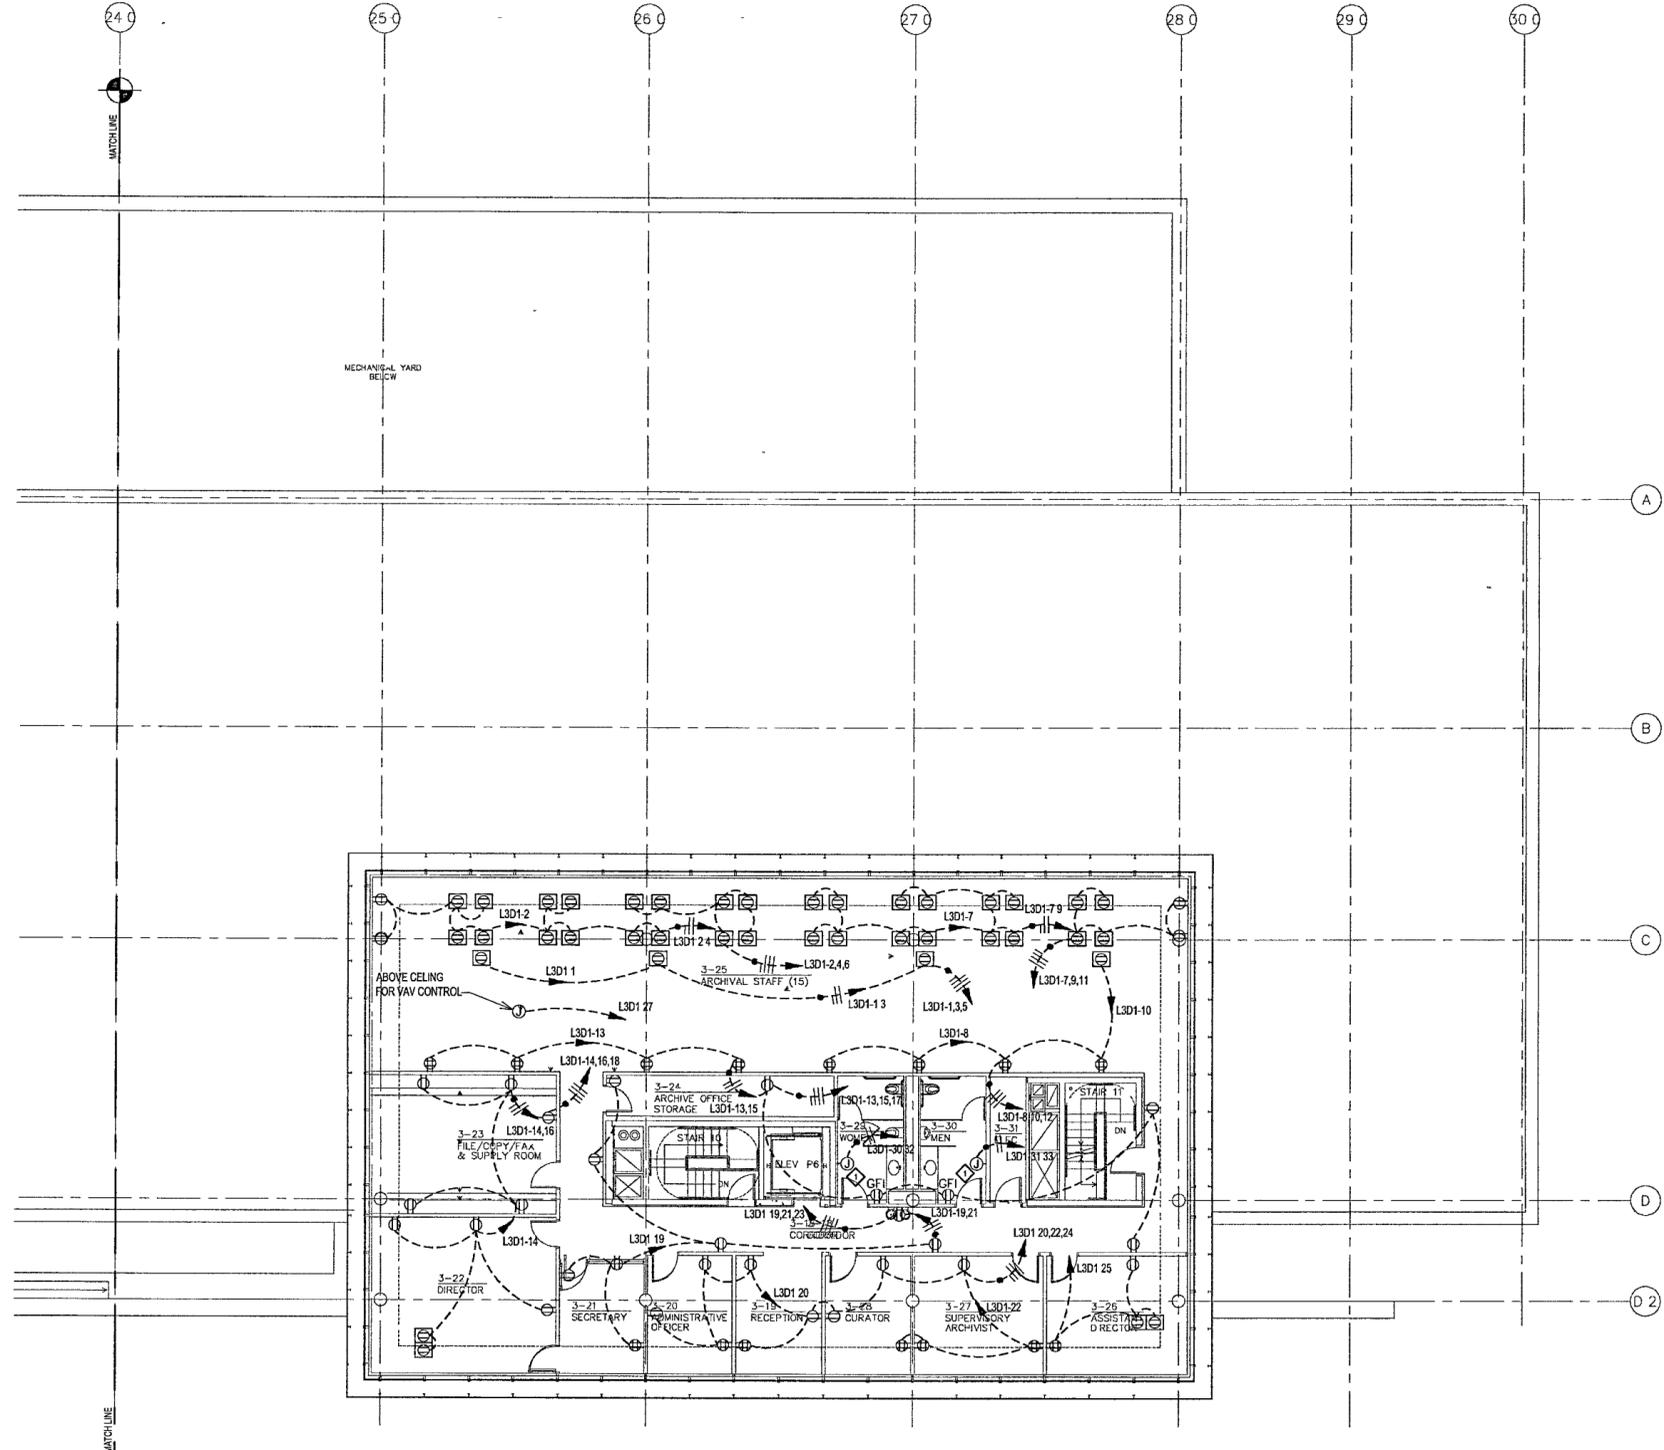

KEYED NOTES
◊ COORDINATE LOCATION OF HAND DRYER.

1 MUSEUM LOWER LEVEL AREA D POWER PLAN
E103d | E103d 1/8" = 1'-0"

