

**WILLIAM J CLINTON  
PRESIDENTIAL  
CENTER**

LITTLE ROCK, ARKANSAS

Architect  
POLSHEK PARTNERSHIP LLP  
520 West 13th Street  
New York, New York 10014  
212.807.7171

Coordinating Architects  
POLK STANLEY YEARY ARCHITECTS, Ltd  
700 South Schiller Street  
Little Rock, Arkansas 72201  
501.378.0878

WITSELL EVANS RASCO  
801 West Third Street  
Little Rock, Arkansas 72201  
501.374.5300

WOODS CARADINE ARCHITECTS  
2200 South Main Street  
Little Rock, Arkansas 72206  
501.374.4060

Landscape Architects  
HARGREAVES ASSOCIATES  
118 Magazine Street  
Cambridge Massachusetts 02139  
617.861.0070


LANDSCAPE ARCHITECTURE Inc.  
2300 Cottondale Lane Suite 202  
Little Rock Arkansas 72202  
501.374.5610

Structural Engineer  
LESLIE E. ROBERTSON ASSOC. RLP  
30 Broad Street, 4th Floor  
New York, New York 10004  
212.750.9000


MEP Engineers  
FLACK + KURTZ Inc.  
475 Fifth Avenue  
New York, New York 10017  
212.532.9600

CROMWELL ARCHITECTS ENGINEERS  
101 South Spring Street  
Little Rock Arkansas 72201  
501.372.2900

Cursewall Consultant  
R. A. HEINTGES ARCHITECTS  
126 Fifth Avenue 9th Floor  
New York, New York 10011  
212.852.2966

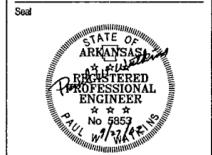

Issue	Date
100% Construction Documents	05/27/02
90% Progress Printing	08/30/02
100% Design Development	03/01/02

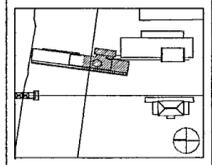

Job No POLSHEK & PARTNERS ARCH 9908  
CROMWELL AE 99-114

Scale 1/8" = 1'-0"


Date SEPTEMBER 27 2002

Title **MUSEUM UPPER LEVEL  
AREA B  
POWER PLAN**

Sheet No **E104b**



**FOR OFFICIAL USE ONLY**

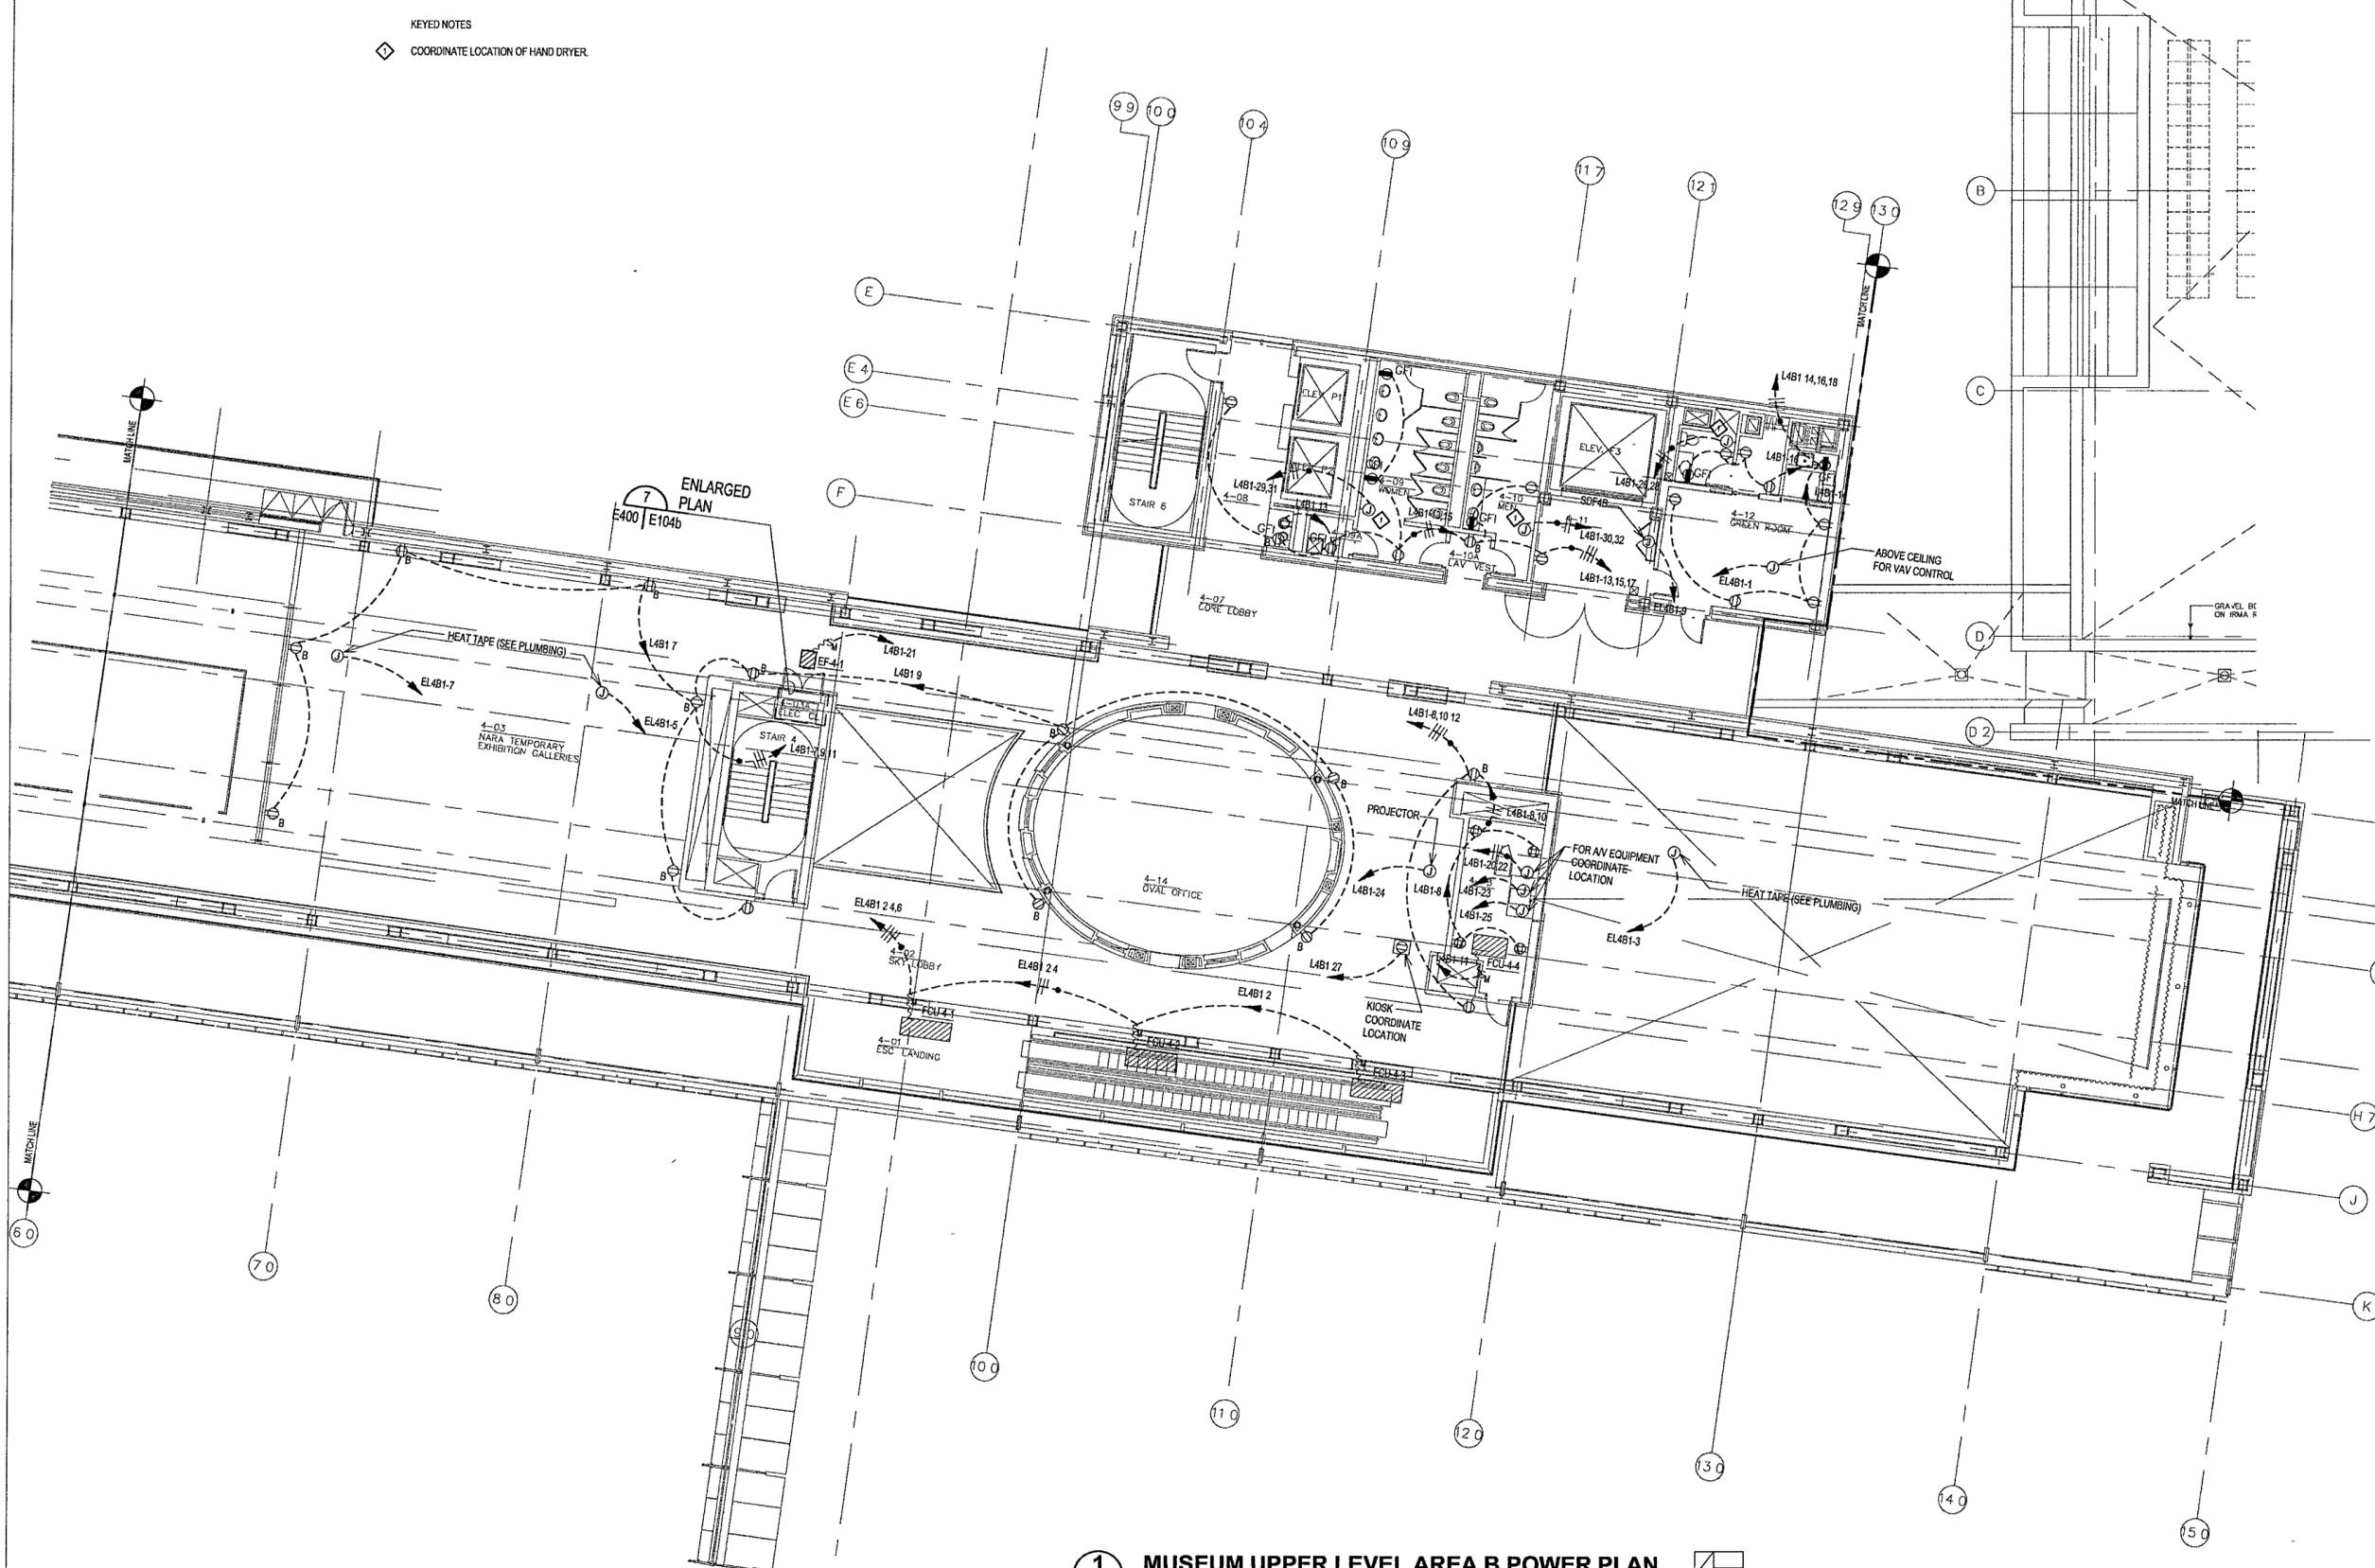

KEYED NOTES  
◇ COORDINATE LOCATION OF HAND DRYER.

ENLARGED PLAN  
E400 | E104b

**1 MUSEUM UPPER LEVEL AREA B POWER PLAN**  
E104b | E104b 1/8" = 1'-0"



494