

**WILLIAM J CLINTON
PRESIDENTIAL
CENTER**

LITTLE ROCK, ARKANSAS

Architect
POLSHEK PARTNERSHIP LLP
320 West 13th Street
New York, New York 10014
212.607.7171

Coordinating Architects
POLK STANLEY YEARY ARCHITECTS, LTD
700 South Schiller Street
Little Rock, Arkansas 72201
501.378.0878

WITSELL EVANS RASCO
901 West Third Street
Little Rock, Arkansas 72201
501.374.5300

WOODS CARADINE ARCHITECTS
2200 South Main Street
Little Rock, Arkansas 72206
501.374.4060

Landscape Architects
HARGREAVES ASSOCIATES
118 Magazine Street
Cambridge, Massachusetts 02139
617.661.0070


LANDSCAPE ARCHITECTURE, INC.
2300 Cottondale Lane Suite 202
Little Rock, Arkansas 72202
501.374.5610

Structural Engineer
LESLIE E ROBERTSON ASSOC., RLP
30 Broad Street, 47th Floor
New York, New York 10004
212.750.9000


MEP Engineers
FLACK + KURTZ, Inc.
475 Fifth Avenue
New York, New York 10017
212.532.9900

CROMWELL ARCHITECTS ENGINEERS
101 South Spring Street
Little Rock, Arkansas 72201
501.372.2900

Curtilaw Consultant
R. A. HENTGES ARCHITECTS
126 Fifth Avenue 9th Floor
New York, New York 10011
212.652.2966

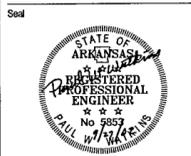

Issue	Date
100% Construction Documents	09/27/02
90% Progress Printing	09/30/02
100% Design Development	03/01/02

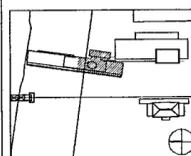


Job No: POLSHEK & PARTNERS ARCH 9908
CROMWELL AE 99-114
Scale: 1/8" = 1'-0"
Date: SEPTEMBER 27, 2002

**EXECUTIVE LEVEL & ROOF
AREA B
POWER PLAN**


Sheet No.
E105b



FOR OFFICIAL USE ONLY

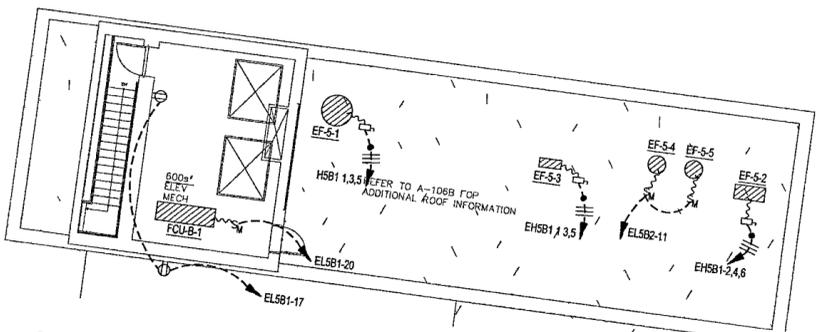

2 MECHANICAL ROOM POWER PLAN
E105b | E105b 1/8" = 1'-0"

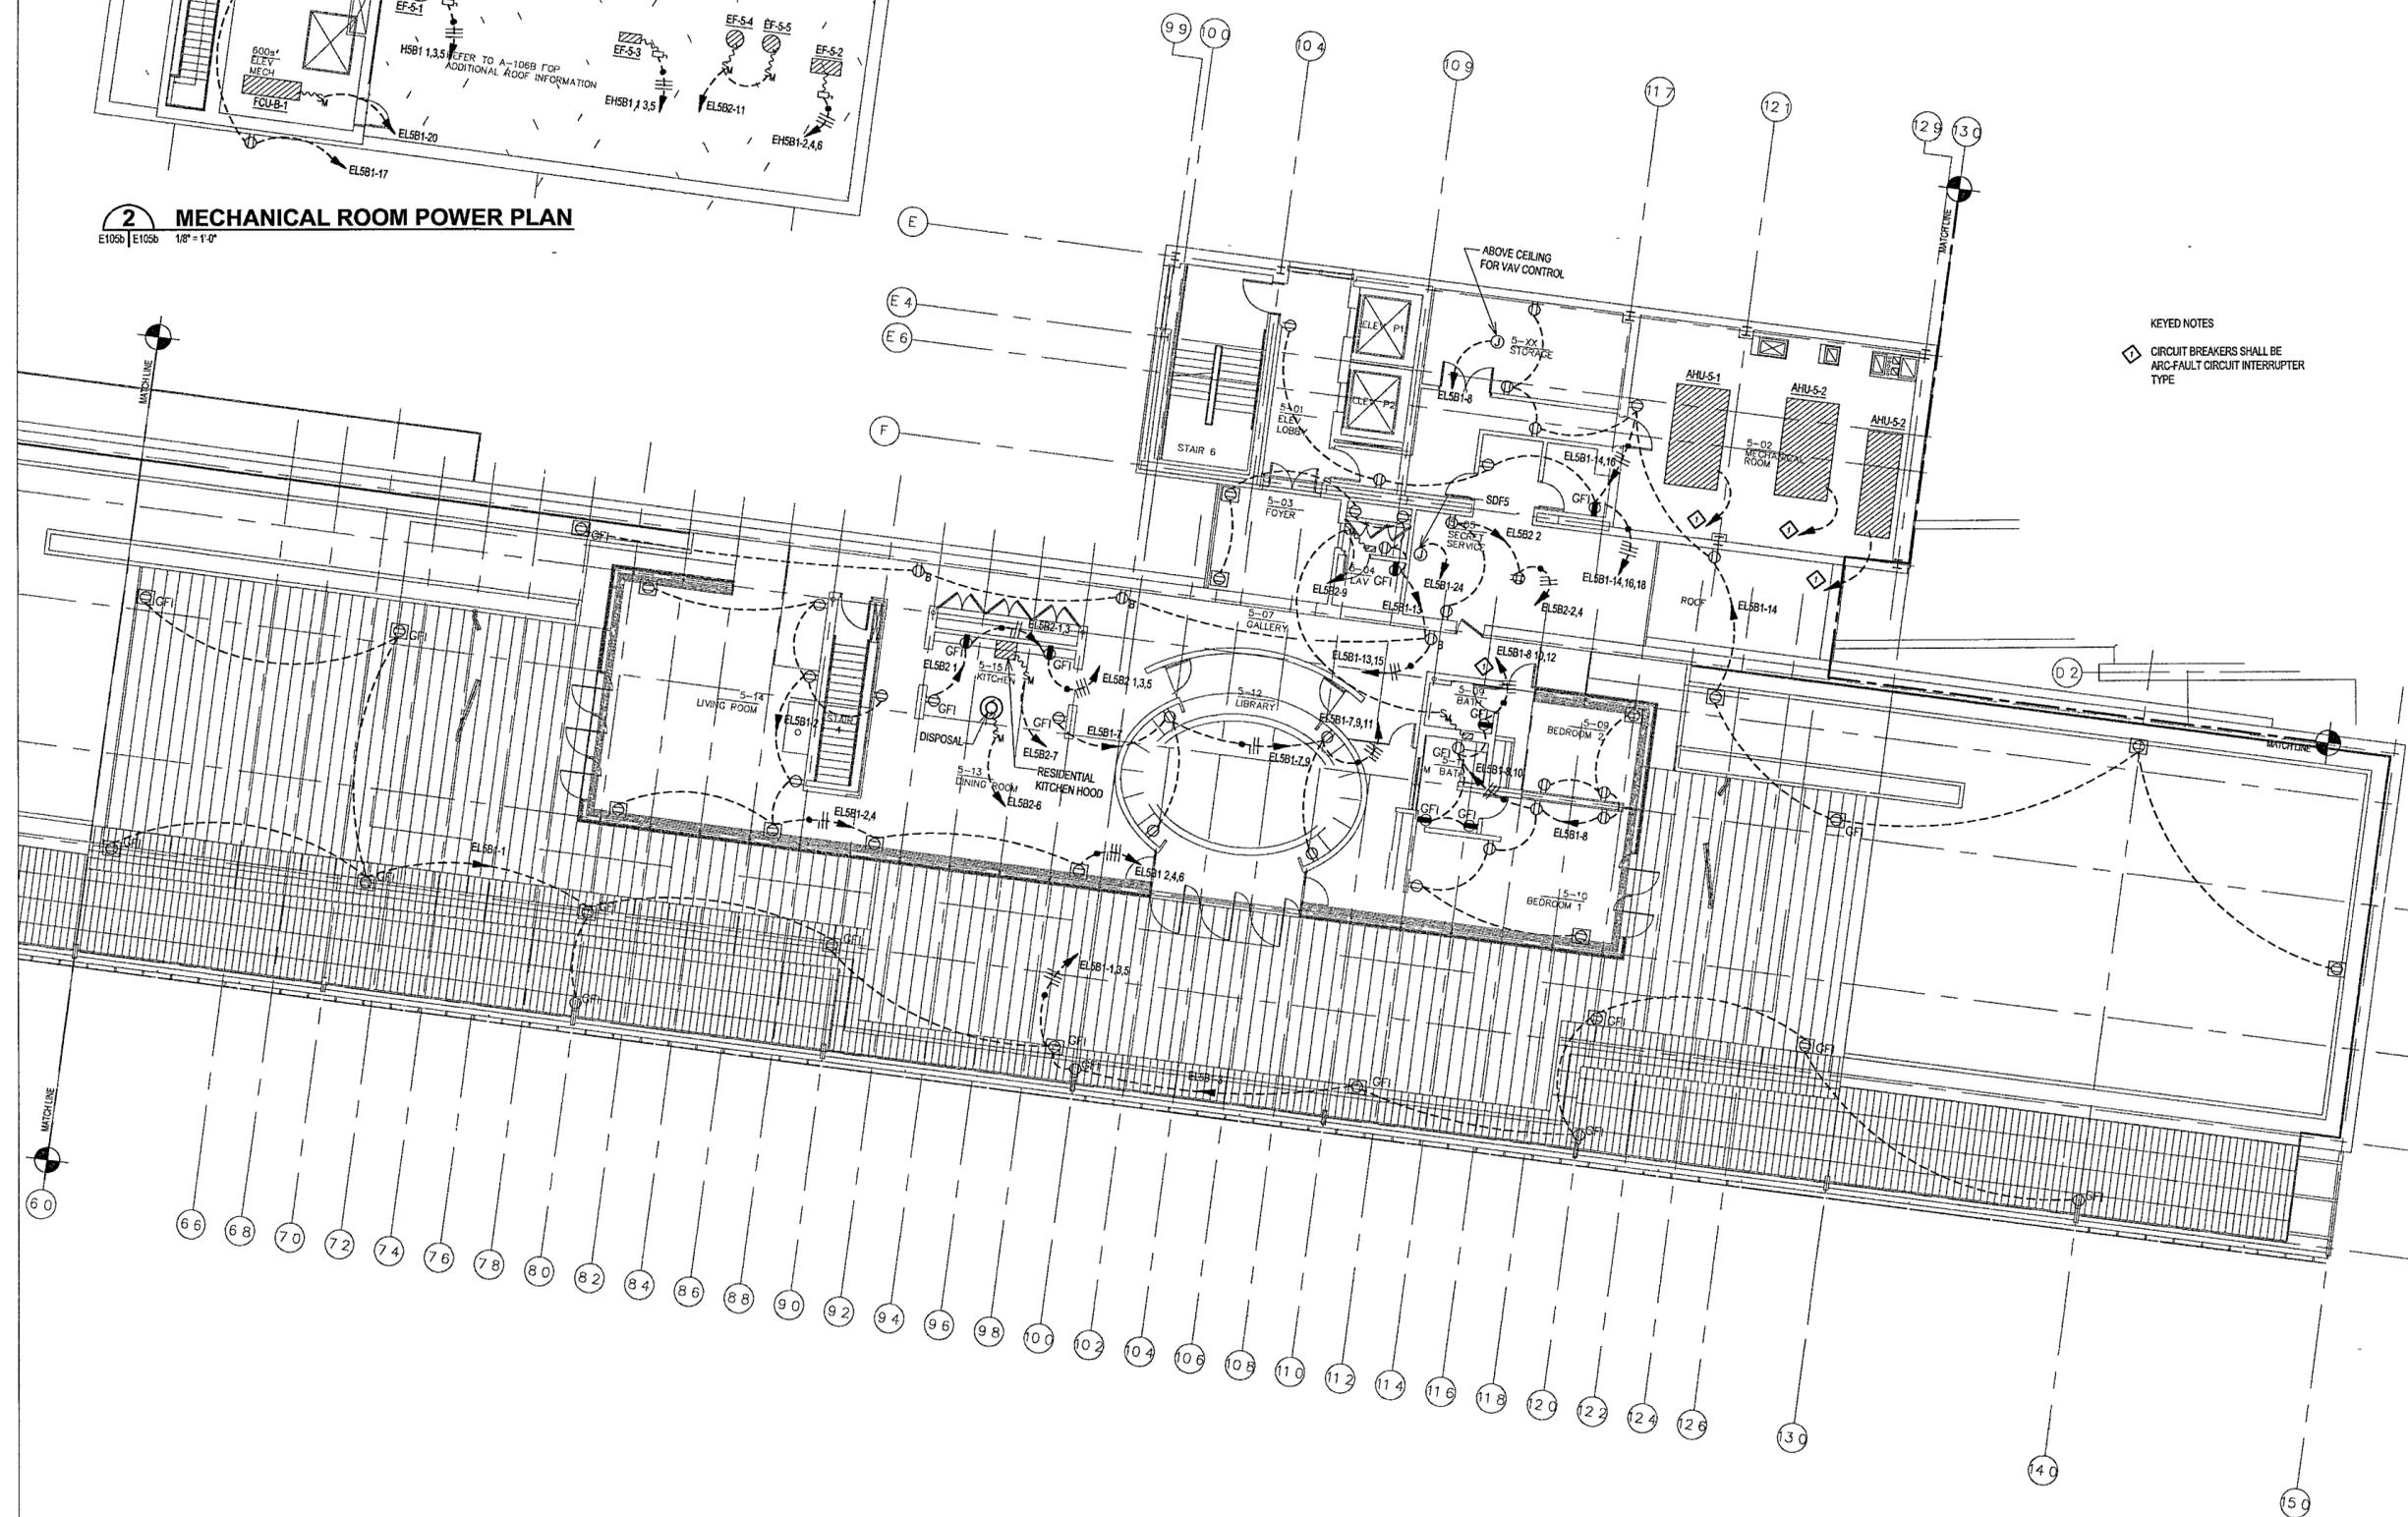

1 EXECUTIVE LEVEL & ROOF AREA B POWER PLAN
E105b | E105b 1/8" = 1'-0"



45L