

**WILLIAM J CLINTON
PRESIDENTIAL
CENTER**

LITTLE ROCK, ARKANSAS

Architect
POLLSHEK PARTNERSHIP LLP
220 West 13th Street
New York, New York 10014
212.807.7171

Coordinating Architects
POLK STANLEY YEARY ARCHITECTS Ltd
700 South Schaller Street
Little Rock, Arkansas 72201
501.378.0878

WITSELL EVANS PASCO
501 West Third Street
Little Rock, Arkansas 72201
501.374.5300

WOODS CARADINE ARCHITECTS
2200 South Main Street
Little Rock, Arkansas 72206
501.374.4060

Landscape Architects
HARGREAVES ASSOCIATES
118 Magazine Street
Cambridge, Massachusetts 02139
617.861.0070


LANDSCAPE ARCHITECTURE, Inc.
2300 Cottondale Lane Suite 202
Little Rock, Arkansas 72202
501.374.5510

Structural Engineer
LESLIE E ROBERTSON ASSOC. P.L.P.
30 Broad Street, 4th Floor
New York, New York 10004
212.750.9000


MEP Engineers
FLACK + KURTZ, Inc.
475 Fifth Avenue
New York, New York 10017
212.532.9900

CROMWELL ARCHITECTS ENGINEERS
101 South Spring Street
Little Rock, Arkansas 72201
501.372.2900

Curianwall Consultant
R. A. HEINTGES ARCHITECTS
126 Fifth Avenue, 9th Floor
New York, New York 10011
212.652.2866

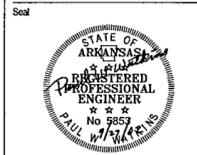


Issue	Date
100% Construction Documents	09/27/02
90% Progress Printing	08/30/02
100% Design Development	03/01/02

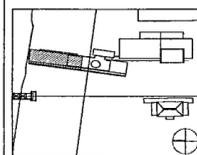

Job No: POLLSHEK & PARTNERS ARCH 99-114
CROMWELL AE 99-114
Scale: 1/8" = 1'-0"
Date: SEPTEMBER 27, 2002

**EXECUTIVE LEVEL
ROOF
AREA A
POWER PLAN**

Sheet No:
E106a

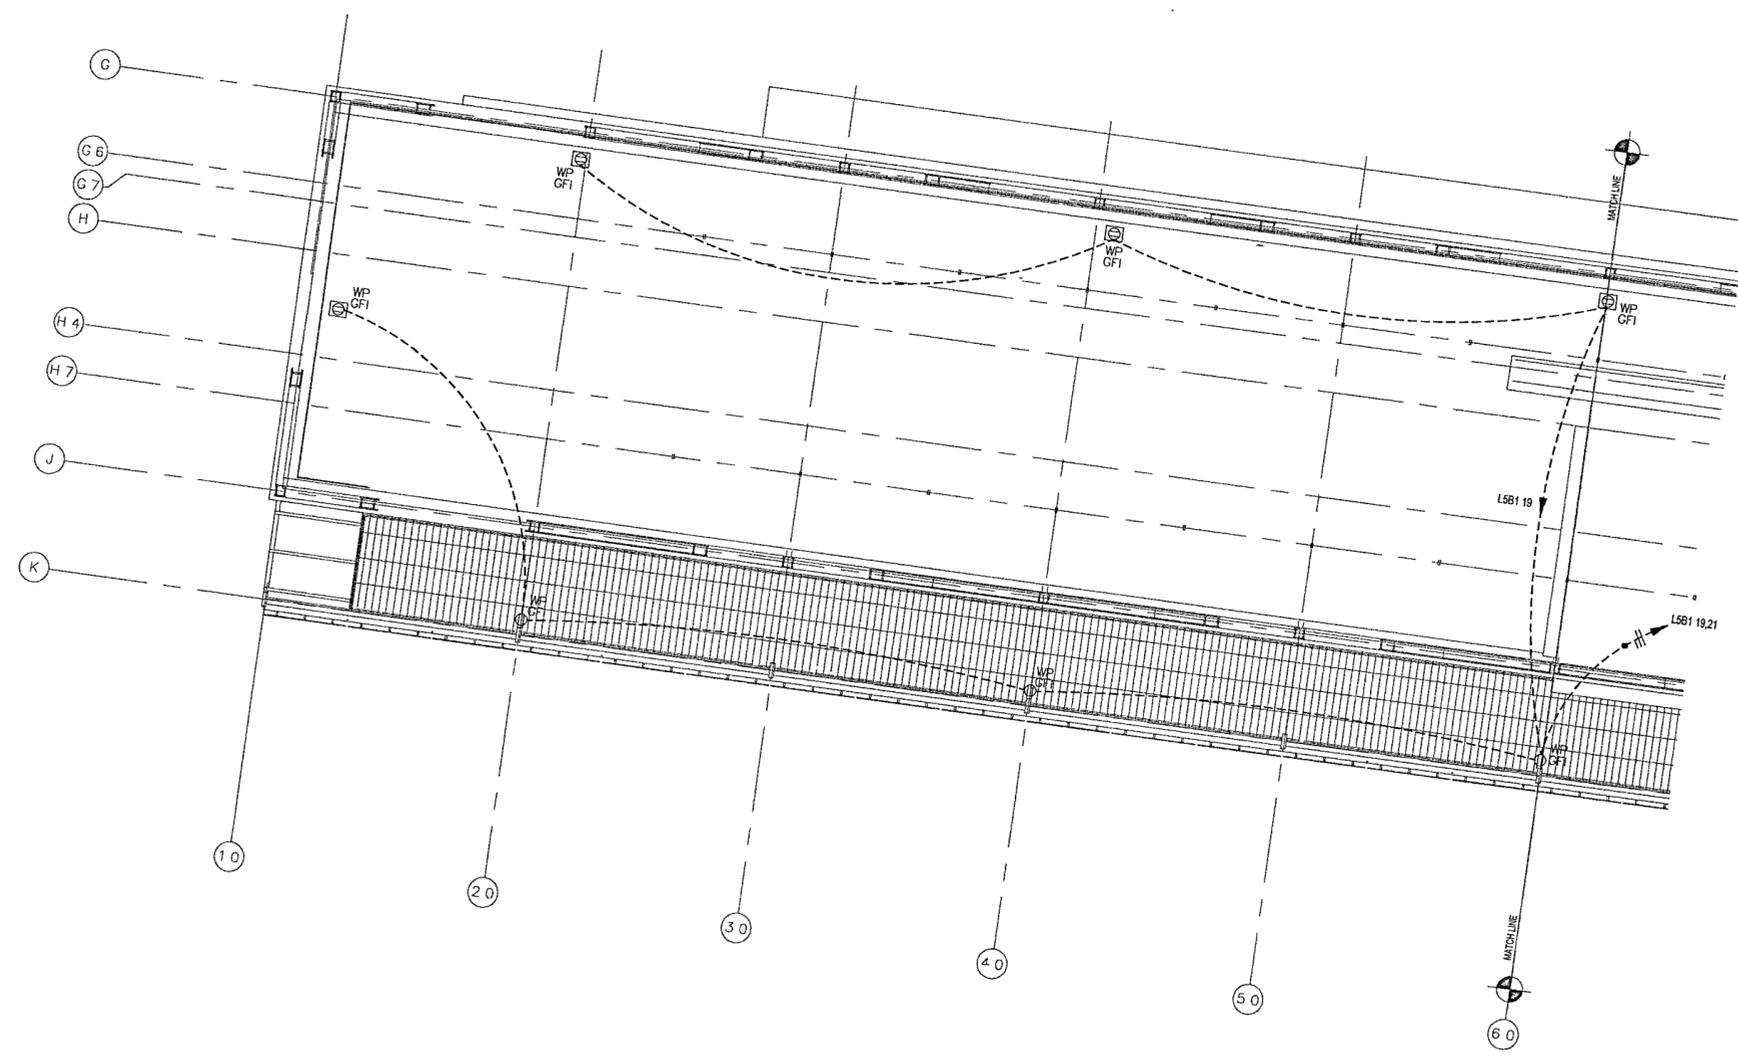

1 EXECUTIVE LEVEL ROOF AREA A POWER PLAN
E106a | E106a 1/8" = 1'-0"
0 4' 8' 16' 24'
NORTH