

**WILLIAM J CLINTON  
PRESIDENTIAL  
CENTER**

LITTLE ROCK, ARKANSAS

Architect  
POLSKY PARTNERSHIP LLP  
320 West 13th Street  
New York, New York 10014  
212.807.7171

Coordinating Architects  
POLK STANLEY YEARY ARCHITECTS, Ltd  
700 South Schiller Street  
Little Rock, Arkansas 72201  
501.378.0878

WITSELL EVANS RASCO  
901 West Third Street  
Little Rock, Arkansas 72201  
501.374.5300

WOODS CARADINE ARCHITECTS  
2200 South Main Street  
Little Rock, Arkansas 72206  
501.374.4060

Landscape Architects  
HARGREAVES ASSOCIATES  
118 Magazine Street  
Cambridge, Massachusetts 02139  
617.661.0070

LANDSCAPE ARCHITECTURE, Inc.  
2300 Cottondale Lane Suite 202  
Little Rock, Arkansas 72202  
501.374.5610

Structural Engineer  
LESLIE E. ROBERTSON ASSOC. RLP  
30 Brent Street, 4th Floor  
New York, New York 10004  
212.750.9000


MEP Engineers  
FLACK + KURTZ Inc.  
475 Fifth Avenue  
New York, New York 10017  
212.532.9600

CROMWELL ARCHITECTS ENGINEERS  
101 South Spring Street  
Little Rock, Arkansas 72201  
501.372.2990

Outfall Consultant  
R. A. HEINTGES ARCHITECTS  
126 Fifth Avenue, 9th Floor  
New York, New York 10011  
212.652.2966



| Issue                       | Date     |
|-----------------------------|----------|
| 100% Construction Documents | 09/27/02 |
| 90% Progress Printing       | 08/30/02 |
| 100% Design Development     | 03/01/02 |

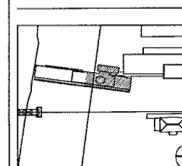

Job No POLSHEK & PARTNERS ARCH. 9908  
CROMWELL AE 99-114  
Scale 1/8" = 1'-0"  
Date SEPTEMBER 27, 2002


Title  
**ROOF  
AREA B  
POWER PLAN**

Sheet No

**E106b**



FOR OFFICIAL USE ONLY

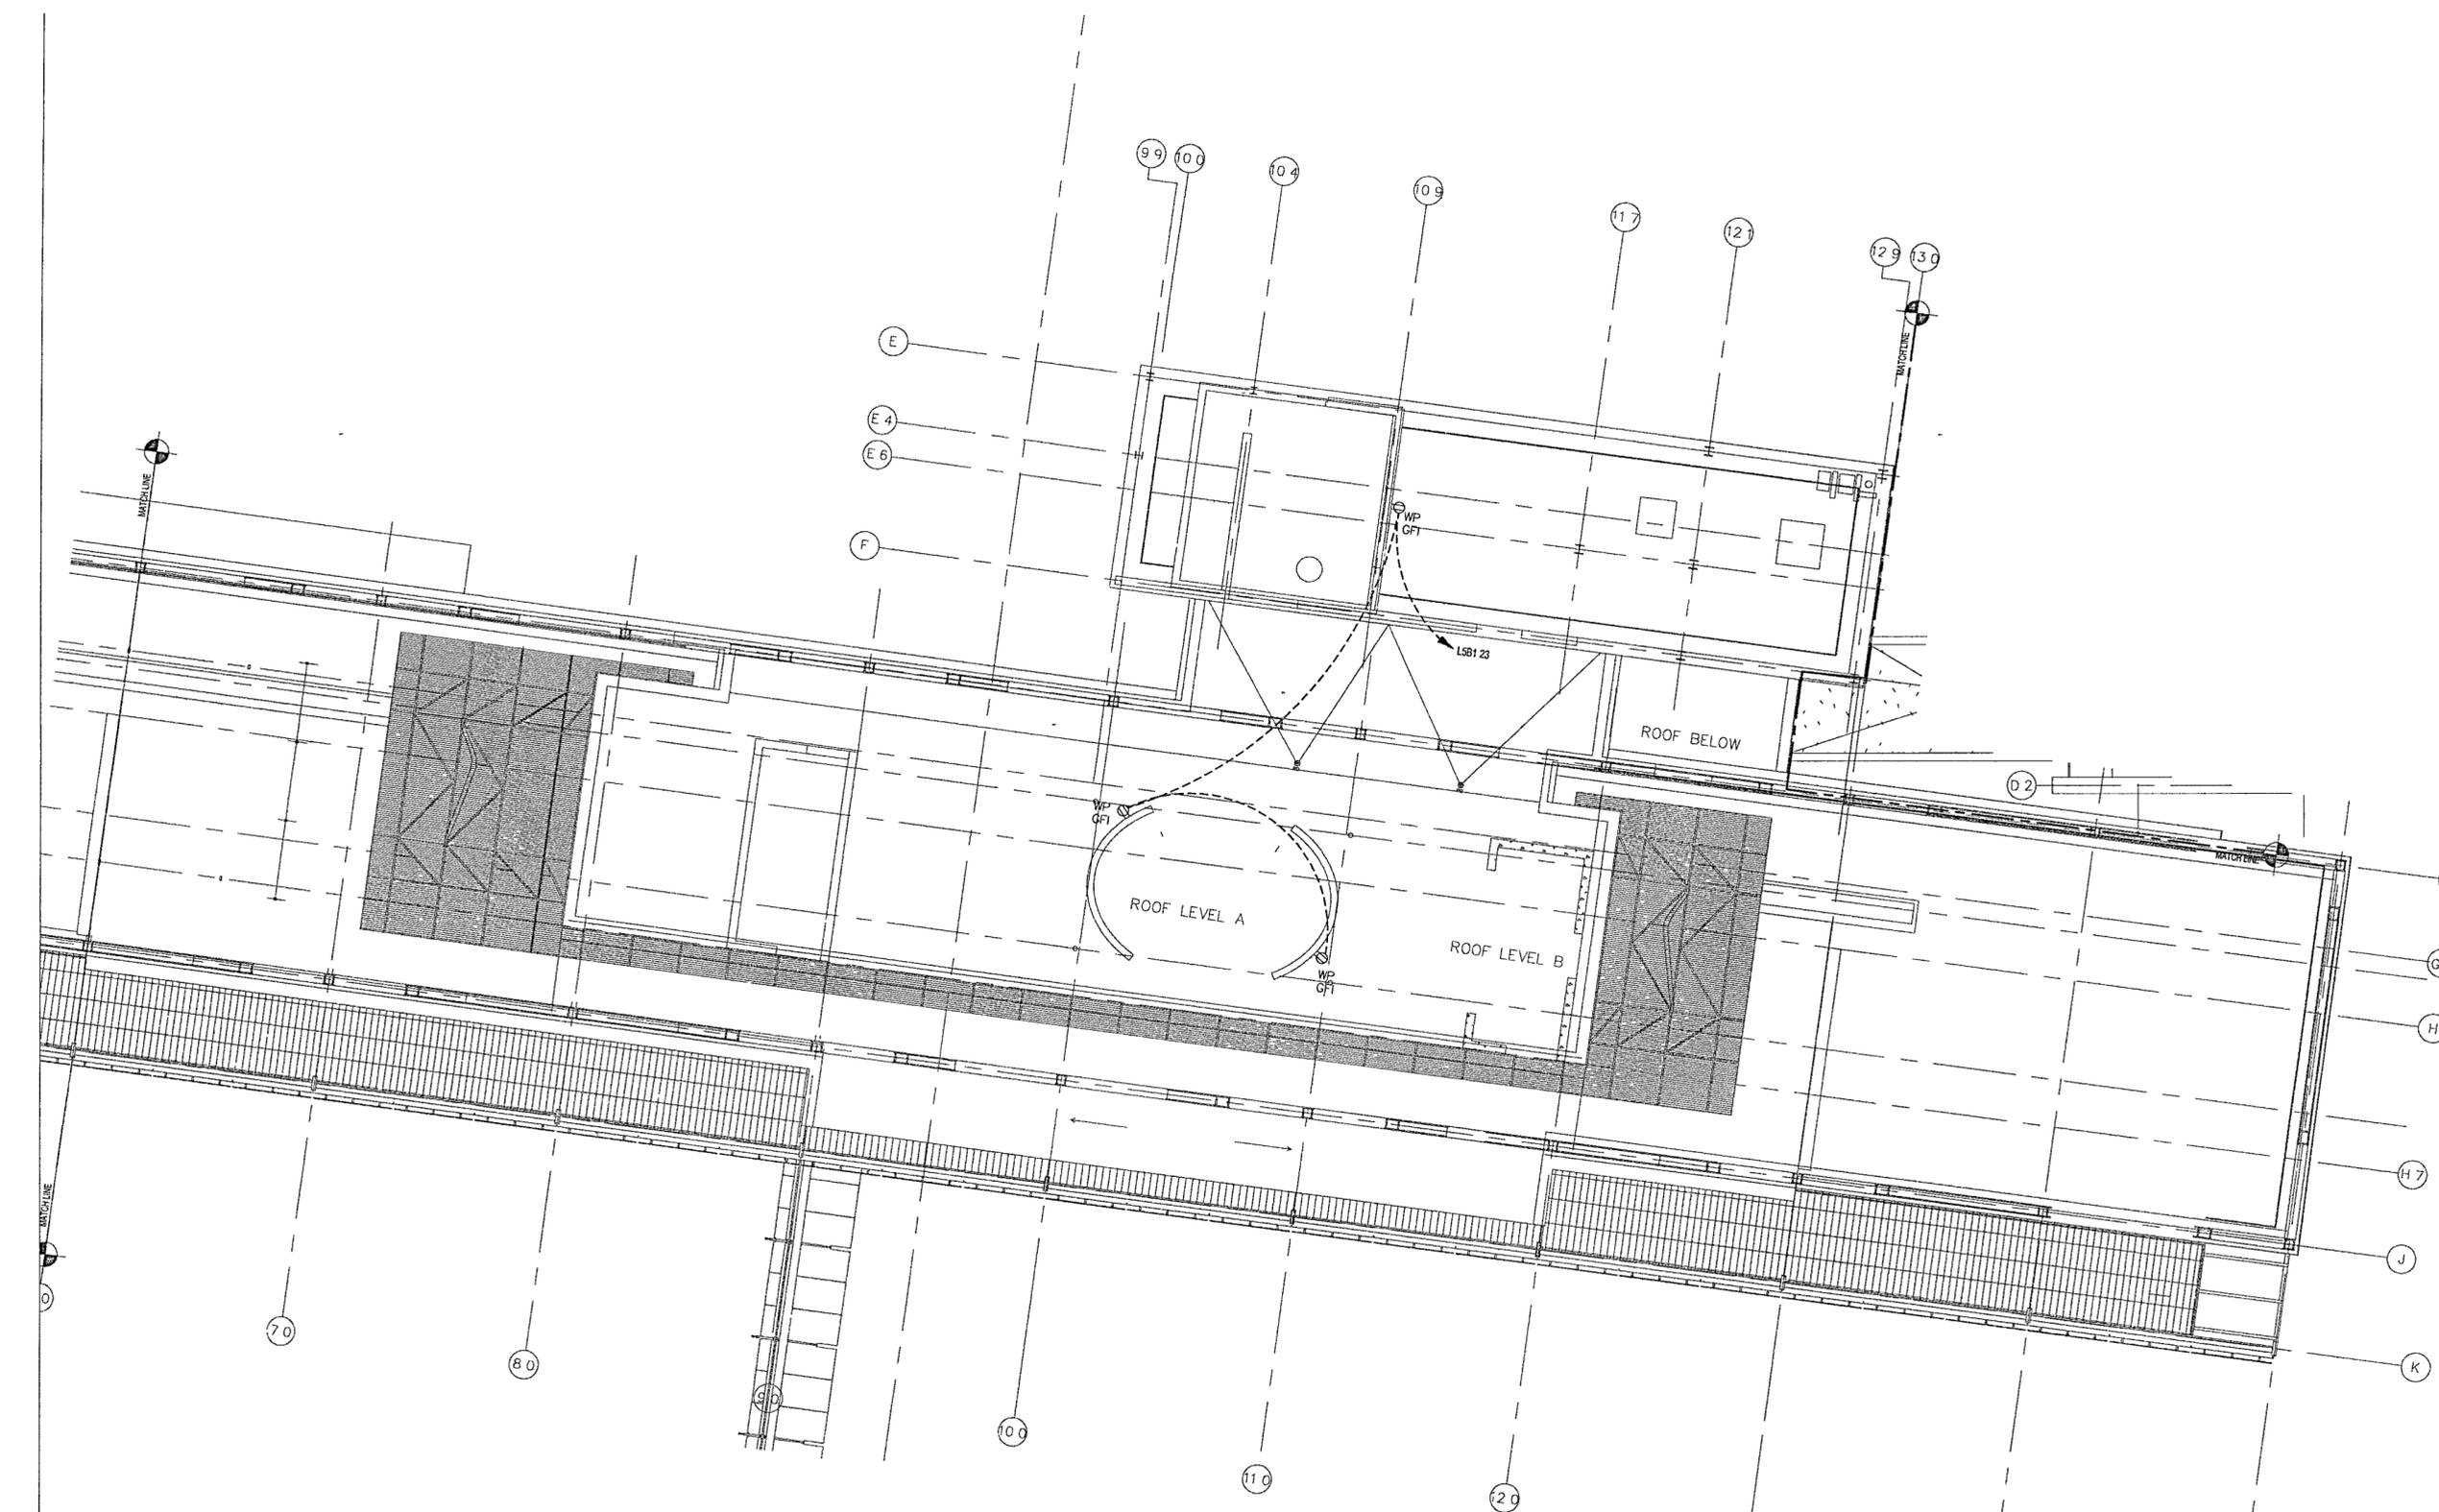

**1 ROOF AREA B POWER PLAN**  
E106B | E106B 1/8" = 1'-0"  
0 4' 8' 16' 24'  
NORTH

178