

**WILLIAM J CLINTON
PRESIDENTIAL
CENTER**

LITTLE ROCK, ARKANSAS

Architect
POLSHIEK PARTNERSHIP LLP
320 West 13th Street
New York, New York 10014
212.807.7171

Coordinating Architects
POLK STANLEY YEARY ARCHITECTS, Ltd
700 South Schiller Street
Little Rock, Arkansas 72201
501.378.0878

WITSELL EVANS RASCO
901 West Third Street
Little Rock, Arkansas 72201
501.374.5300

WOODS CARADINE ARCHITECTS
2200 South Main Street
Little Rock, Arkansas 72206
501.374.4060

Landscape Architects
HARGREAVES ASSOCIATES
118 Magazine Street
Cambridge, Massachusetts 02139
617.661.0070


LANDSCAPE ARCHITECTURE, Inc.
2300 Cottondale Lane Suite 202
Little Rock, Arkansas 72202
501.374.5610

Structural Engineer
LESLIE E. ROBERTSON ASSOC. RLLP
30 Broad Street 47th Floor
New York, New York 10004
212.750.9000


MEP Engineers
FLACK + KURTZ Inc.
475 Fifth Avenue
New York, New York 10017
212.532.9600

CROMWELL ARCHITECTS ENGINEERS
101 South Spring Street
Little Rock, Arkansas 72201
501.372.2900

Curiamwall Consultant
R. A. HEINTGES ARCHITECTS
128 Fifth Avenue 9th Floor
New York, New York 10011
212.652.2965

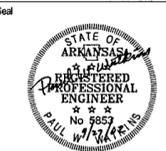


100% Construction Documents	09/21/02
90% Progress Printing	08/30/02
100% Design Development	03/01/02
Issue	Date

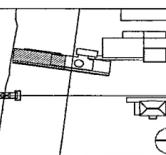


Job No. POLSHIEK & PARTNERS ARCH 9808
CROMWELL AE 99-114
Scale 1/8" = 1'-0"
Date SEPTEMBER 27 2002

**GROUND LEVEL
AREA A
LIGHTING PLAN**

 Sheet No. **E201a**



- GENERAL NOTES
- COORDINATE EXACT LOCATION QUANTITY AND STYLE OF S, AND OS DEVICES WITH ARCHITECT FOR CONTROL INTENT
 - PROVIDE CLASS 2 WIRING AND CONDUIT FROM EVERY OS AND SL DEVICE HOMERUNS BACK TO BMS SERVER CLOSETS
 - CIRCUIT EXIT SIGNS TO NEAREST SPARE CIRCUIT BREAKER IN A LOW VOLTAGE EMERGENCY PANEL, UNSWITCHED
 - TWO-TRACK SYSTEMS ARE USED FOR NORMAL AND EMERGENCY LIGHTING, ONE TRACK FOR EACH ON TRACKS RUNNING NORTH-SOUTH, WIRE EMERGENCY CIRCUITS TO WEST-SIDE TRACK ON TRACKS RUNNING EAST WEST, WIRE EMERGENCY CIRCUITS TO NORTH-SIDE TRACK EMERGENCY CIRCUITS HOME RUNS ARE DXXXX, DLXXX, SHXXX, SLXXX MOUNT L27A FIXTURES PERMANENTLY TO EMERGENCY TRACK SIDE
 - ON DXXXX AND SXXXX (DIMMERS AND SWITCHES) NEVER USE A NEUTRAL IN COMMON TO TWO OR MORE MODULES IN THE PANELS ALL DXXXX AND SXXXX MUST HAVE DEDICATED NEUTRALS FROM THE LOAD(S) ALL THE WAY BACK TO THE MODULE

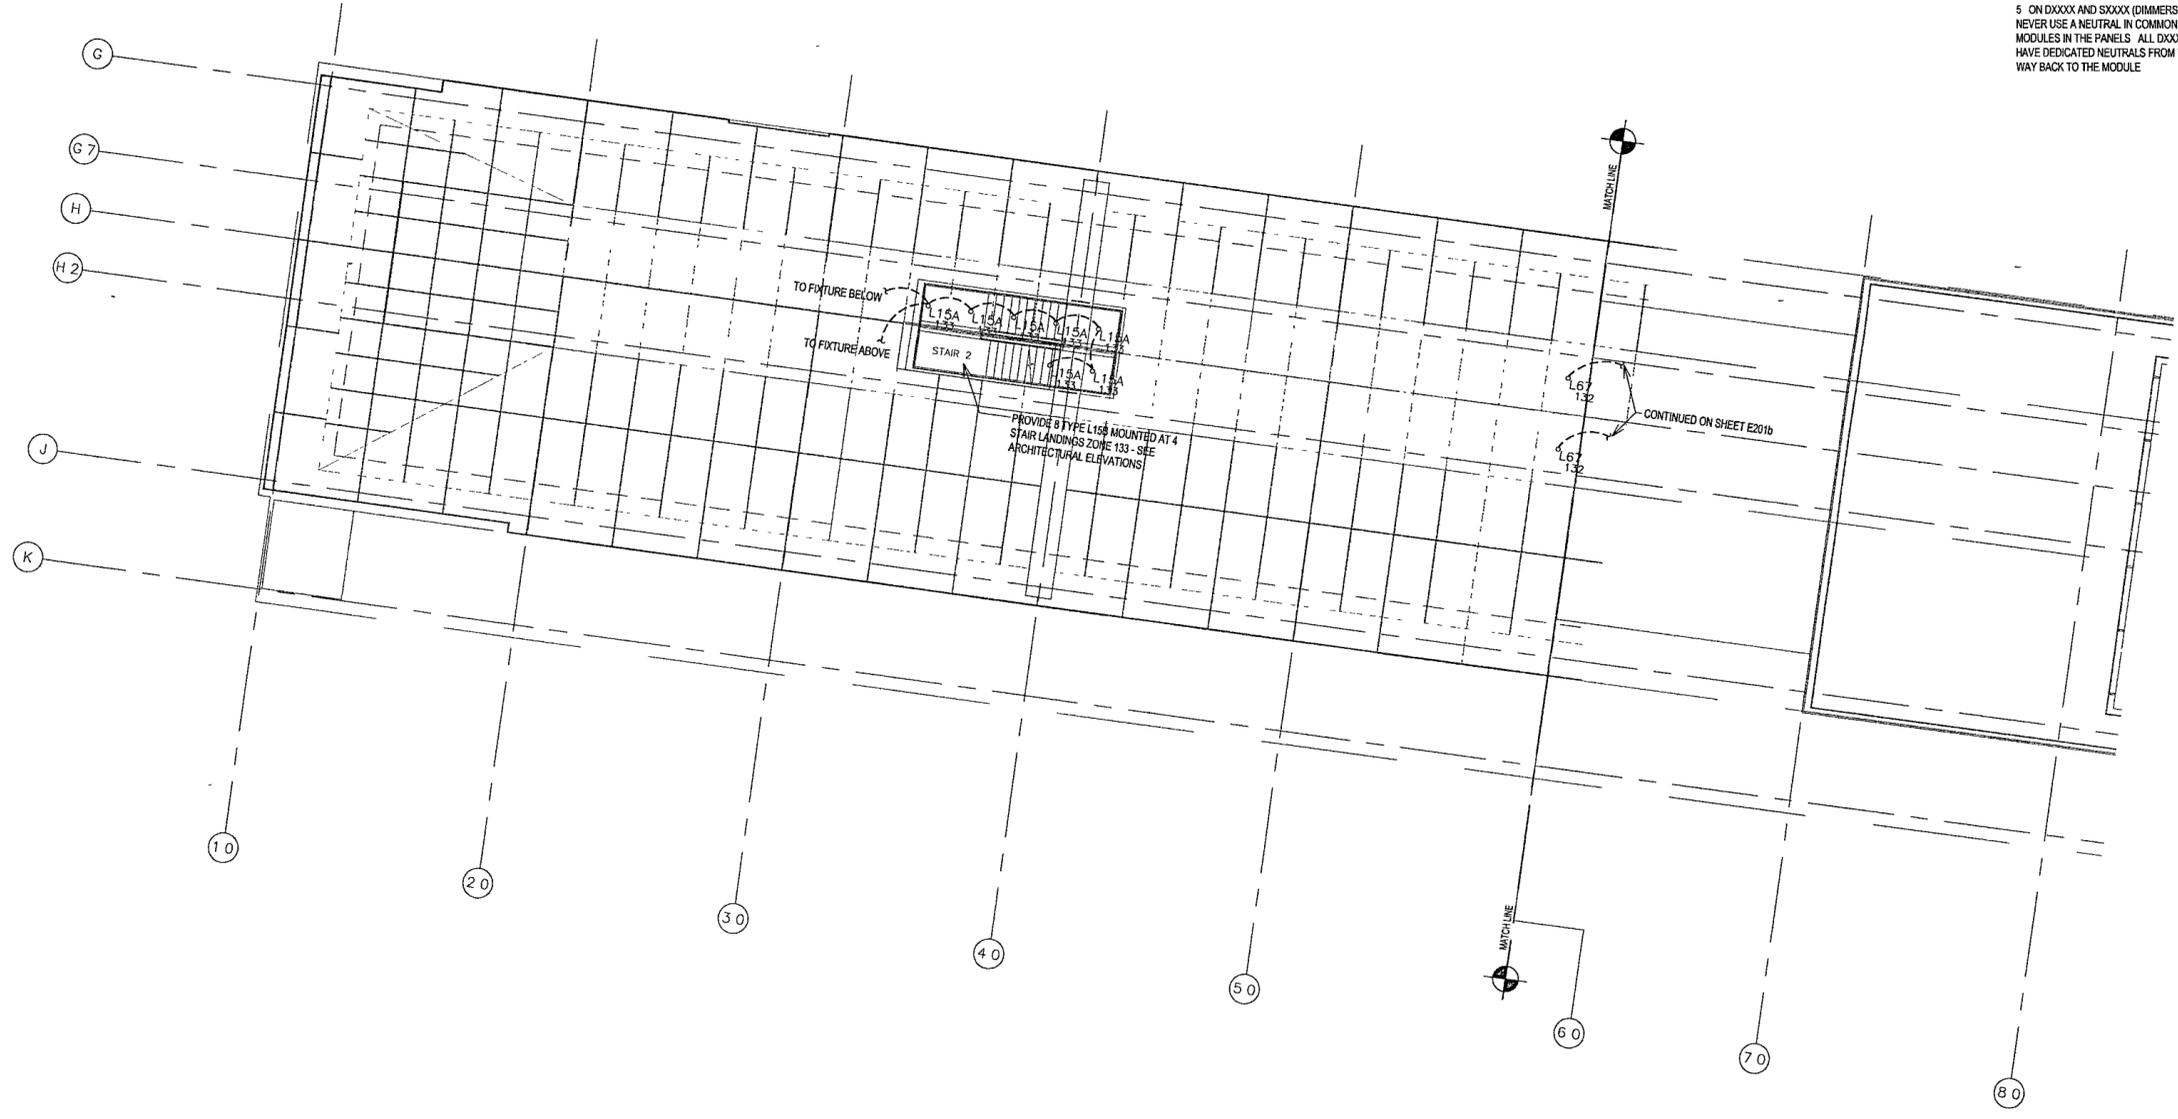

1 GROUND LEVEL AREA A LIGHTING PLAN
E201a | E201a 1/8" = 1'-0"