

GENERAL NOTES


1 COORDINATE EXACT LOCATION, QUANTITY AND STYLE OF S<sub>1</sub> AND OS<sub>1</sub> DEVICES WITH ARCHITECT FOR CONTROL INTENT

2 PROVIDE CLASS 2 WIRING AND CONDUIT FROM EVERY OS AND SL DEVICE, HOMERUNS BACK TO BMS SERVER CLOSETS

3 CIRCUIT EXIT SIGNS TO NEAREST SPARE CIRCUIT BREAKER IN A LOW VOLTAGE EMERGENCY PANEL, UNSWITCHED

4 TWO-TRACK SYSTEMS ARE USED FOR NORMAL AND EMERGENCY LIGHTING, ONE-TRACK FOR EACH ON TRACKS RUNNING NORTH-SOUTH. WIRE EMERGENCY CIRCUITS TO WEST-SIDE TRACK. ON TRACKS RUNNING EAST-WEST, WIRE EMERGENCY CIRCUITS TO NORTH-SIDE TRACK. EMERGENCY CIRCUITS HOME RUNS ARE DHXXX, DLXXX, SHXXX, SLXXX. MOUNT L27A FIXTURES PERMANENTLY TO EMERGENCY TRACK SIDE

5 ON DXXXX AND SXXXX (DIMMERS AND SWITCHES) NEVER USE A NEUTRAL IN COMMON TO TWO OR MORE MODULES IN THE PANELS. ALL DXXXX AND SXXXX MUST HAVE DEDICATED NEUTRALS FROM THE LOAD(S) ALL THE WAY BACK TO THE MODULE

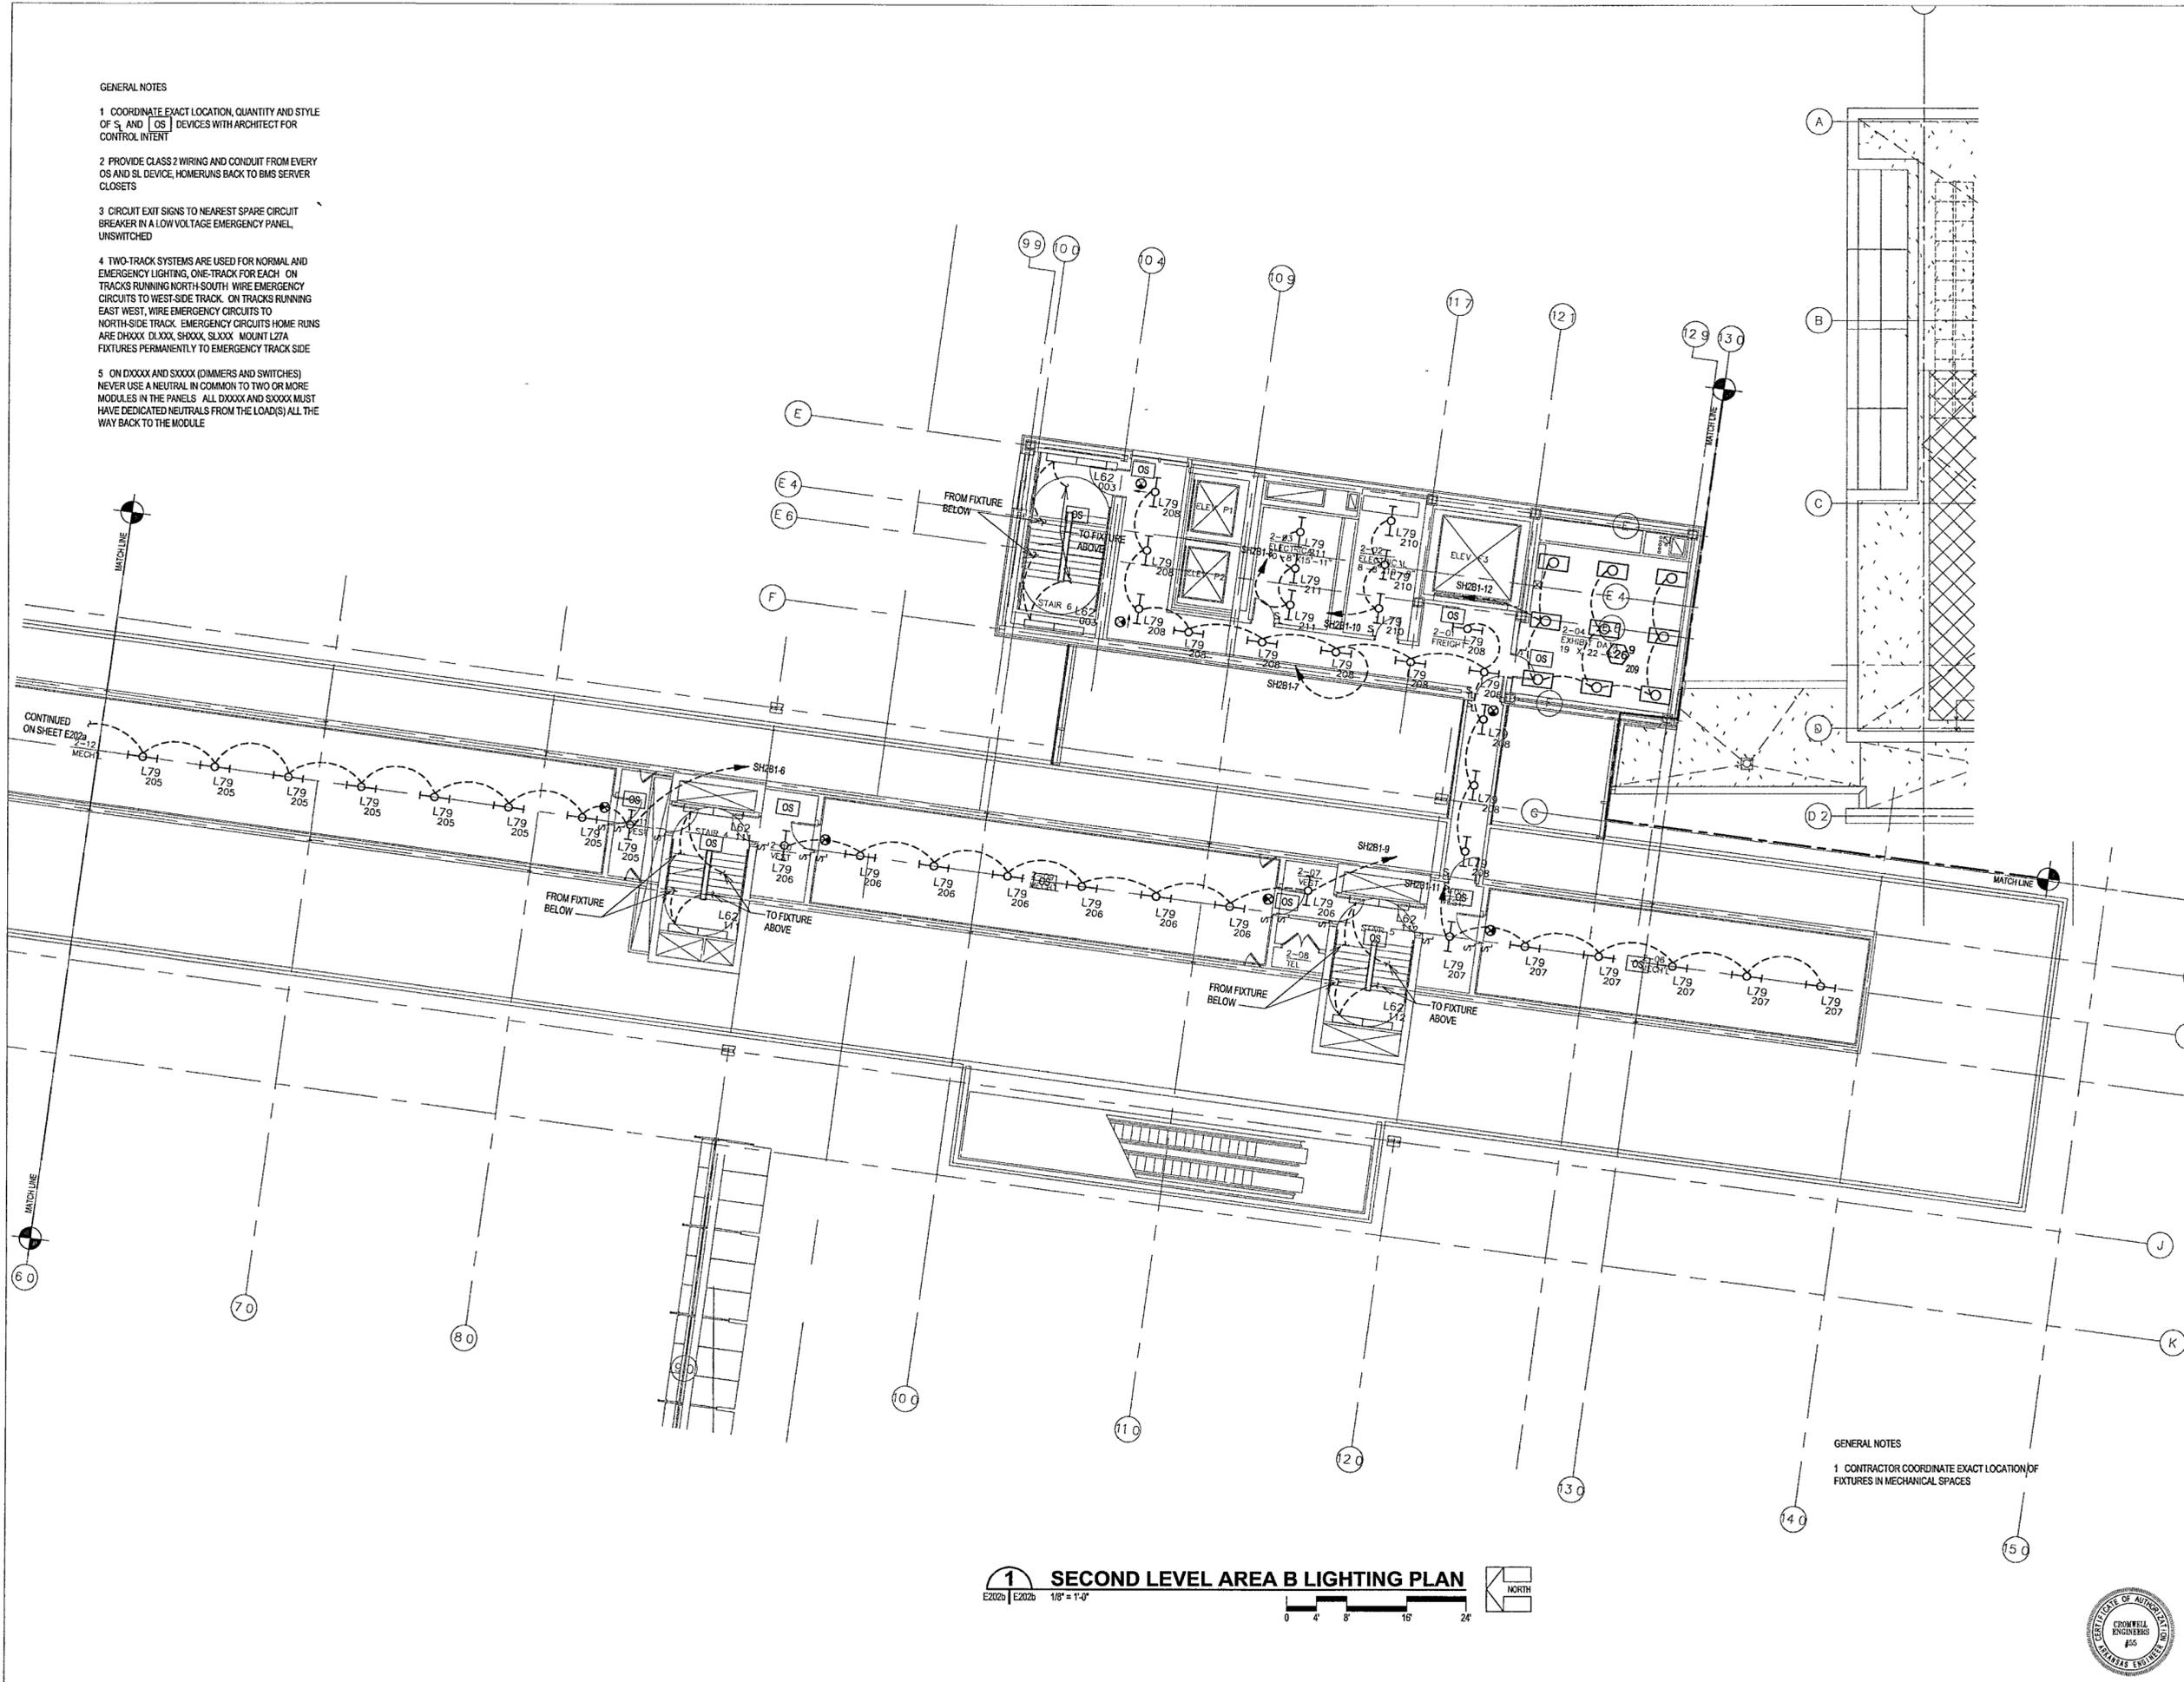

GENERAL NOTES  
1 CONTRACTOR COORDINATE EXACT LOCATION OF FIXTURES IN MECHANICAL SPACES

**1 SECOND LEVEL AREA B LIGHTING PLAN**  
E202b | E202b 1/8" = 1'-0"

**WILLIAM J CLINTON  
PRESIDENTIAL  
CENTER**

LITTLE ROCK ARKANSAS

Architect  
POLSHEK PARTNERSHIP LLP  
320 West 12th Street  
New York, New York 10014  
212.807.7171

Coordinating Architects  
POLK STANLEY YEARY ARCHITECTS, Ltd  
700 South Schuler Street  
Little Rock, Arkansas 72201  
501.378.0878

WITSELL EVANS RASCO  
901 West Third Street  
Little Rock, Arkansas 72201  
501.374.5300

WOODS CARADINE ARCHITECTS  
2200 South Main Street  
Little Rock, Arkansas 72206  
501.374.4060

Landscape Architects  
HARGREAVES ASSOCIATES  
118 Magariane Street  
Cambridge, Massachusetts 02139  
617.661.0070

LANDSCAPE ARCHITECTURE Inc  
2300 Cottondale Lane Suite 202  
Little Rock, Arkansas 72202  
501.374.5510

Structural Engineer  
LESLIE E. ROBERTSON ASSOC. RLLP  
30 Broad Street 47th Floor  
New York, New York 10004  
212.750.9000


MEP Engineers  
FLACK + KURTZ Inc  
475 Fifth Avenue  
New York, New York 10017  
212.532.9000

CROMWELL ARCHITECTS ENGINEERS  
101 South Spring Street  
Little Rock, Arkansas 72201  
501.372.2300

Curtilaw Consultant  
R. A. HEINTGES ARCHITECTS  
128 Fifth Avenue, 9th Floor  
New York, New York 10011  
212.652.2956



100% Construction Documents	09/27/02
90% Progress Printing	09/30/02
100% Design Development	03/01/02
Issue	Date

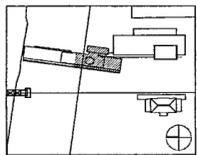

Job No: POLSHEK & PARTNERS ARCH 9908  
CROMWELL AE 99-114  
Scale: 1/8" = 1'-0"  
Date: SEPTEMBER 27, 2002

**SECOND LEVEL  
AREA B  
LIGHTING PLAN**

Sheet No: **E202b**



FOR OFFICIAL USE ONLY