

**WILLIAM J CLINTON
PRESIDENTIAL
CENTER**

LITTLE ROCK, ARKANSAS

Architect
POLSHEK PARTNERSHIP LLP
320 West 53rd Street
New York, New York 10014
212 807 7171

Coordinating Architects
POLK STANLEY YEARY ARCHITECTS, Ltd
700 South Schiller Street
Little Rock, Arkansas 72201
501 378 0878

WITSELL EVANS RASCO
901 West Third Street
Little Rock, Arkansas 72201
501 374 5300

WOODS CARADINE ARCHITECTS
2200 South Main Street
Little Rock, Arkansas 72205
501 374 4060

Landscape Architects
HARGREAVES ASSOCIATES
118 Magazine Street
Cambridge, Massachusetts 02139
617 661 0070


LANDSCAPE ARCHITECTURE, Inc
2300 Cottondale Lane Suite 202
Little Rock, Arkansas 72202
501.374.5610

Structural Engineer
LESLIE E. ROBERTSON ASSOC. RLP
30 Broad Street 47th Floor
New York, New York 10004
212.750.9000


MEP Engineers
FLACK + KURTZ Inc
475 Fifth Avenue
New York, New York 10017
212.532.9600

CROMWELL ARCHITECTS ENGINEERS
101 South Spring Street
Little Rock, Arkansas 72201
501 372-2900

Curriculum Consultant
R. A. HEINTGES ARCHITECTS
128 Fifth Avenue 9th Floor
New York, New York 10011
212.652-2966

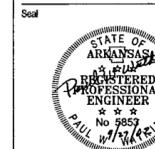

Issue	Date
100% Construction Documents	09/27/02
90% Progress Printing	09/30/02
100% Design Development	03/01/02

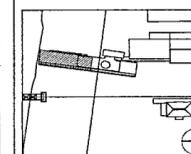

Job No: POLSHEK & PARTNERS ARCH 9908
CROMWELL AE 99-114

Scale: 1/8" = 1'-0"

Date: SEPTEMBER 27, 2002


Title: MUSEUM LOWER LEVEL AREA A LIGHTING PLAN

Sheet No:

E203a


GENERAL NOTES

- COORDINATE EXACT LOCATION, QUANTITY AND STYLE OF OS AND OS DEVICES WITH ARCHITECT FOR CONTROL INTENT
- PROVIDE CLASS 2 WIRING AND CONDUIT FROM EVERY OS AND SL DEVICE, HOMERUNS BACK TO BMS SERVER CLOSETS
- CIRCUIT EXIT SIGNS TO NEAREST SPARE CIRCUIT BREAKER IN A LOW VOLTAGE EMERGENCY PANEL, UNSWITCHED
- TWO-TRACK SYSTEMS ARE USED FOR NORMAL AND EMERGENCY LIGHTING, ONE-TRACK FOR EACH ON TRACKS RUNNING NORTH-SOUTH, WIRE EMERGENCY CIRCUITS TO WEST-SIDE TRACK. ON TRACKS RUNNING EAST WEST, WIRE EMERGENCY CIRCUITS TO NORTH SIDE TRACK. EMERGENCY CIRCUITS HOME RUNS ARE DHXX, DLXX, SHXX, SLXX, MOUNT L27A FIXTURES PERMANENTLY TO EMERGENCY TRACK SIDE
- ON DXXX AND SXXX (DIMMERS AND SWITCHES) NEVER USE A NEUTRAL IN COMMON TO TWO OR MORE MODULES IN THE PANELS. ALL DXXX AND SXXX MUST HAVE DEDICATED NEUTRALS FROM THE LOAD(S) ALL THE WAY BACK TO THE MODULE

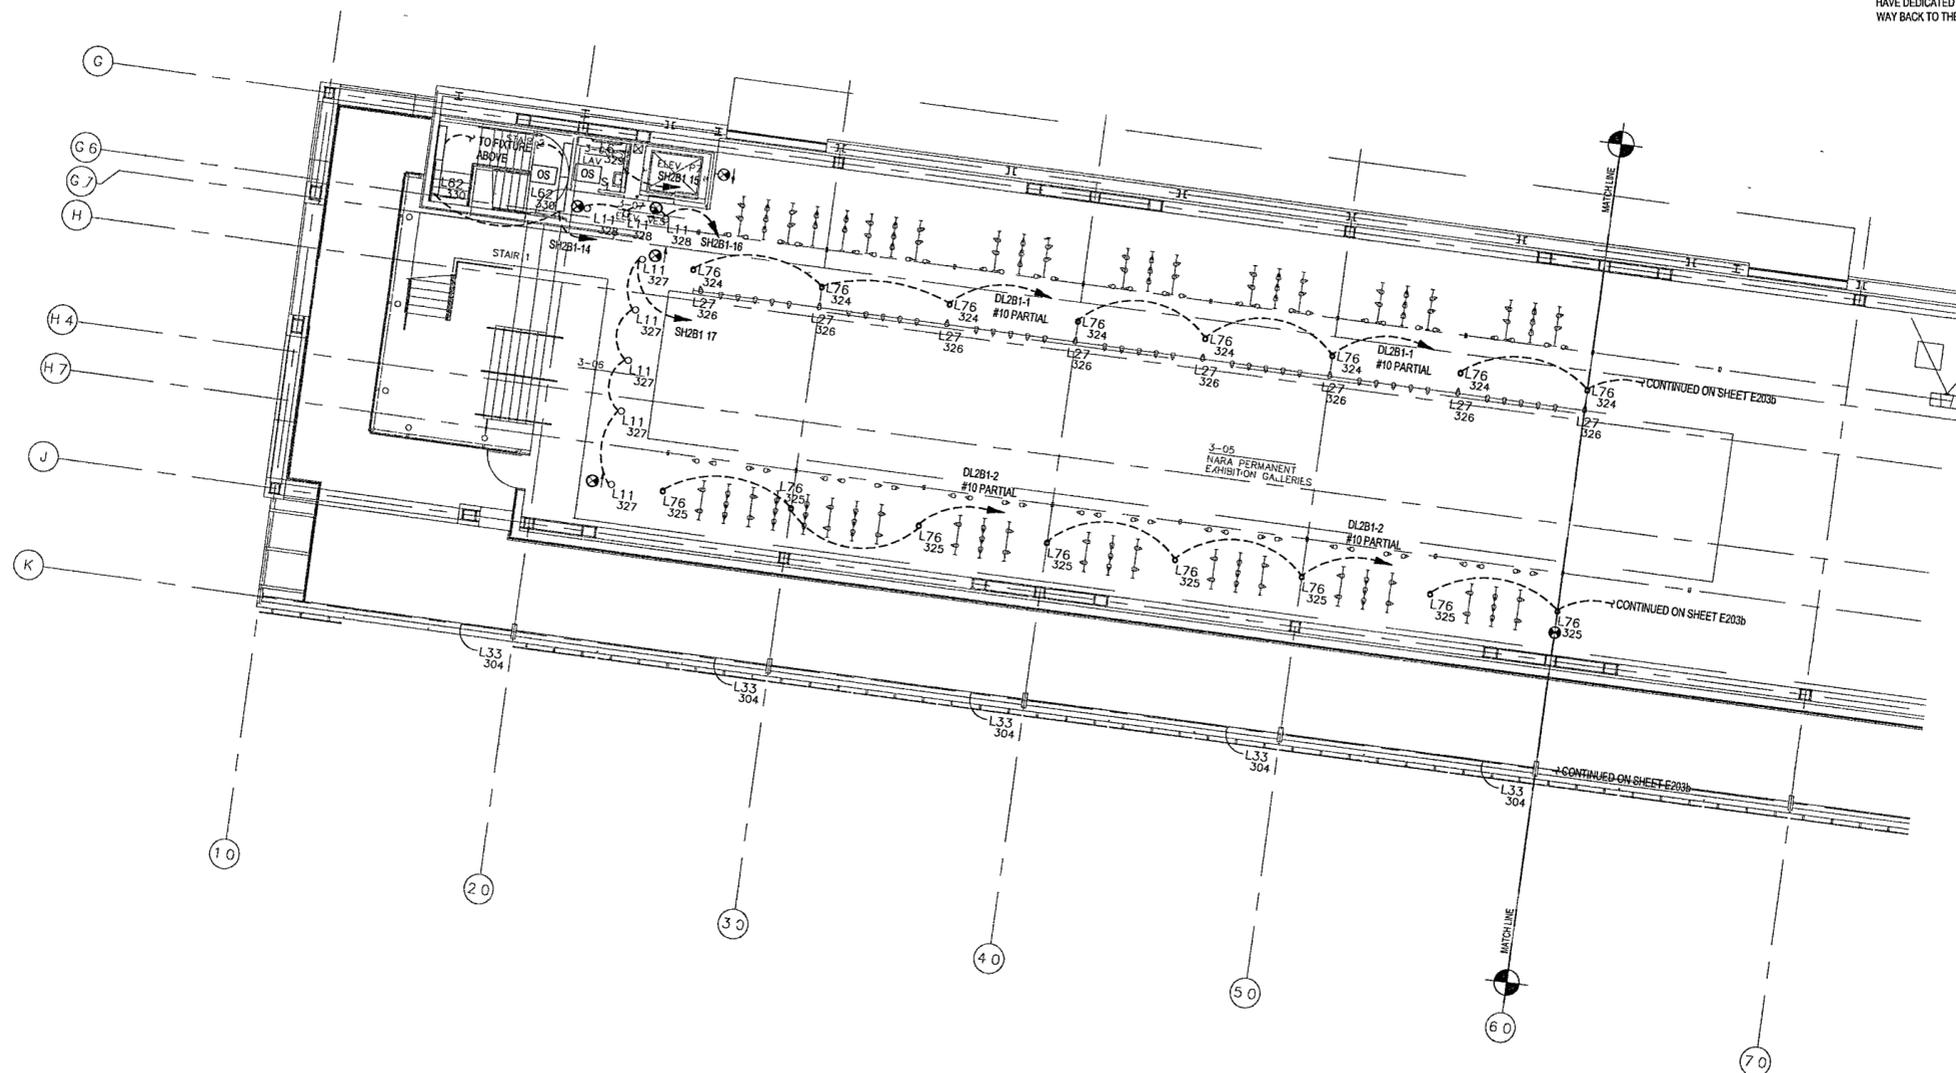

1 MUSEUM LOWER LEVEL AREA A LIGHTING PLAN

E203a | E203a 1/8" = 1'-0"

 

FOR OFFICIAL USE ONLY