

**WILLIAM J CLINTON
PRESIDENTIAL
CENTER**

LITTLE ROCK, ARKANSAS

Architect
POLSHEK PARTNERSHIP LLP
320 West 13th Street
New York, New York 10014
212.807.7171

Coordinating Architects
POLK STANLEY YEARY ARCHITECTS, Ltd
700 South Schiller Street
Little Rock, Arkansas 72201
501.378.0678

WITSELL EVANS RASCO
901 West Third Street
Little Rock, Arkansas 72201
501.374.5300

WOODS CARADINE ARCHITECTS
2200 South Main Street
Little Rock, Arkansas 72206
501.374.4060

Landscape Architects

HARGREAVES ASSOCIATES
118 Magazine Street
Cambridge, Massachusetts 02139
617.661.0070

LANDSCAPE ARCHITECTURE, Inc.
2320 Colonside Lane Suite 202
Little Rock, Arkansas 72202
501.374.5610

Structural Engineer
LESLIE E. ROBERTSON ASSOC. P.L.P.
90 Broad Street 4th Floor
New York, New York 10004
212.750.9000

MEP Engineers

FLACK + KURTZ Inc
475 Fifth Avenue
New York, New York 10017
212.532.9600

CROMWELL ARCHITECTS ENGINEERS
101 South Spring Street
Little Rock, Arkansas 72201
501.372.2900


Curianwall Consultant

R. A. HEINTGES ARCHITECTS
125 Fifth Avenue 9th Floor
New York, New York 10011
212.652.2968

Seal



100% Construction Documents	09/27/02
90% Progress Planning	06/20/02
100% Design Development	03/01/02
Issue	Date

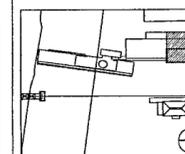

Job No: POLSHEK & PARTNERS ARCH. 9908

CROMWELL AE 99-114

Scale: 1/8" = 1'-0"

Date: SEPTEMBER 27, 2002


Title:

**THIRD LEVEL
AREA D
LIGHTING PLAN**

Sheet No:

E203d

FOR OFFICIAL USE ONLY

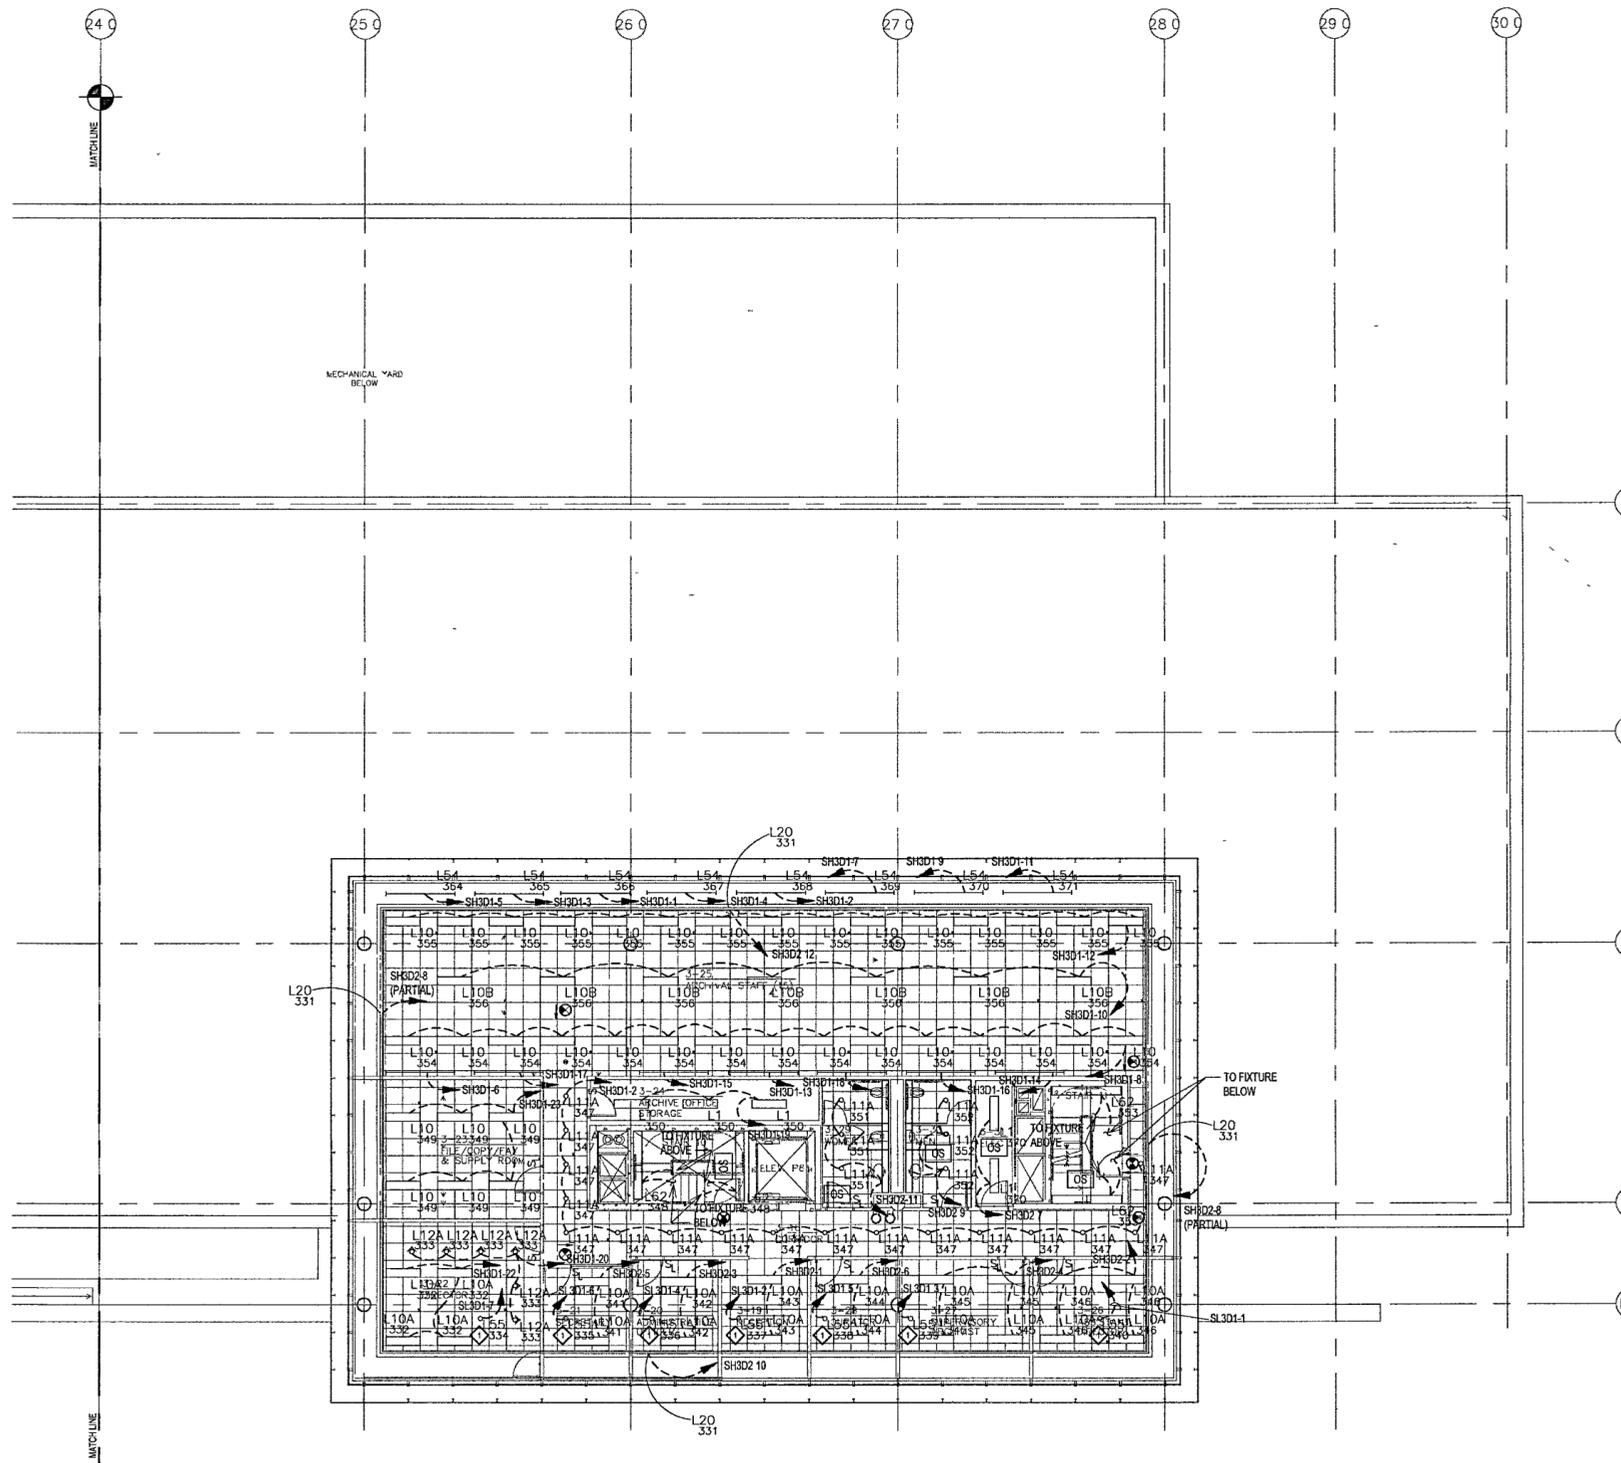

GENERAL NOTES

- COORDINATE EXACT LOCATION, QUANTITY AND STYLE OF S₁ AND [OS] DEVICES WITH ARCHITECT FOR CONTROL INTENT
- PROVIDE CLASS 2 WIRING AND CONDUIT FROM EVERY OS AND SL DEVICE, HOMERUNS BACK TO BMS SERVER CLOSETS
- CIRCUIT EXIT SIGNS TO NEAREST SPARE CIRCUIT BREAKER IN A LOW VOLTAGE EMERGENCY PANEL, UNSWITCHED
- TWO-TRACK SYSTEMS ARE USED FOR NORMAL AND EMERGENCY LIGHTING. ONE-TRACK FOR EACH ON TRACKS RUNNING NORTH SOUTH, WIRE EMERGENCY CIRCUITS TO WEST SIDE TRACK ON TRACKS RUNNING EAST-WEST, WIRE EMERGENCY CIRCUITS TO NORTH-SIDE TRACK. EMERGENCY CIRCUITS HOME RUNS ARE DXXXX, DLXXX, SHXXX, SLXXX. MOUNT L2/A FIXTURES PERMANENTLY TO EMERGENCY TRACK SIDE.
- ON DXXXX AND SXXXX (DIMMERS AND SWITCHES) NEVER USE A NEUTRAL IN COMMON TO TWO OR MORE MODULES IN THE PANELS. ALL DXXXX AND SXXXX MUST HAVE DEDICATED NEUTRALS FROM THE LOAD(S) ALL THE WAY BACK TO THE MODULE

KEYED NOTES

- FOR EACH L55 FIXTURE, PROVIDE A RECEPTACLE IN ADDITION TO OTHER RECEPTACLES IN THE SPACE. CIRCUIT TO A SWITCHING ZONE AS SHOWN, TO INCLUDE THE FIXTURE IN THE BMS. COORDINATE EXACT LOCATION WITH ARCHITECT

1 THIRD LEVEL AREA D LIGHTING PLAN
E203d E203d 1/8" = 1'-0"
0 4 8 16 24
NORTH

