


GENERAL NOTES

- COORDINATE EXACT LOCATION, QUANTITY AND STYLE OF S₁ AND OS₁ DEVICES WITH ARCHITECT FOR CONTROL INTENT
- PROVIDE CLASS 2 WIRING AND CONDUIT FROM EVERY OS AND SL DEVICE, HOMERUNS BACK TO BMS SERVER CLOSETS
- CIRCUIT EXIT SIGNS TO NEAREST SPARE CIRCUIT BREAKER IN A LOW VOLTAGE EMERGENCY PANEL, UNSWITCHED
- TWO-TRACK SYSTEMS ARE USED FOR NORMAL AND EMERGENCY LIGHTING, ONE TRACK FOR EACH ON TRACKS RUNNING NORTH-SOUTH, WIRE EMERGENCY CIRCUITS TO WEST-SIDE TRACK. ON TRACKS RUNNING EAST WEST, WIRE EMERGENCY CIRCUITS TO NORTH-SIDE TRACK. EMERGENCY CIRCUITS HOME RUNS ARE DXXXX, DXXXX, SHXXX, SLXXX. MOUNT L27A FIXTURES PERMANENTLY TO EMERGENCY TRACK SIDE
- ON DXXXX AND SXXXX (DIMMERS AND SWITCHES) NEVER USE A NEUTRAL IN COMMON TO TWO OR MORE MODULES IN THE PANELS. ALL DXXXX AND SXXXX MUST HAVE DEDICATED NEUTRALS FROM THE LOAD(S) ALL THE WAY BACK TO THE MODULE

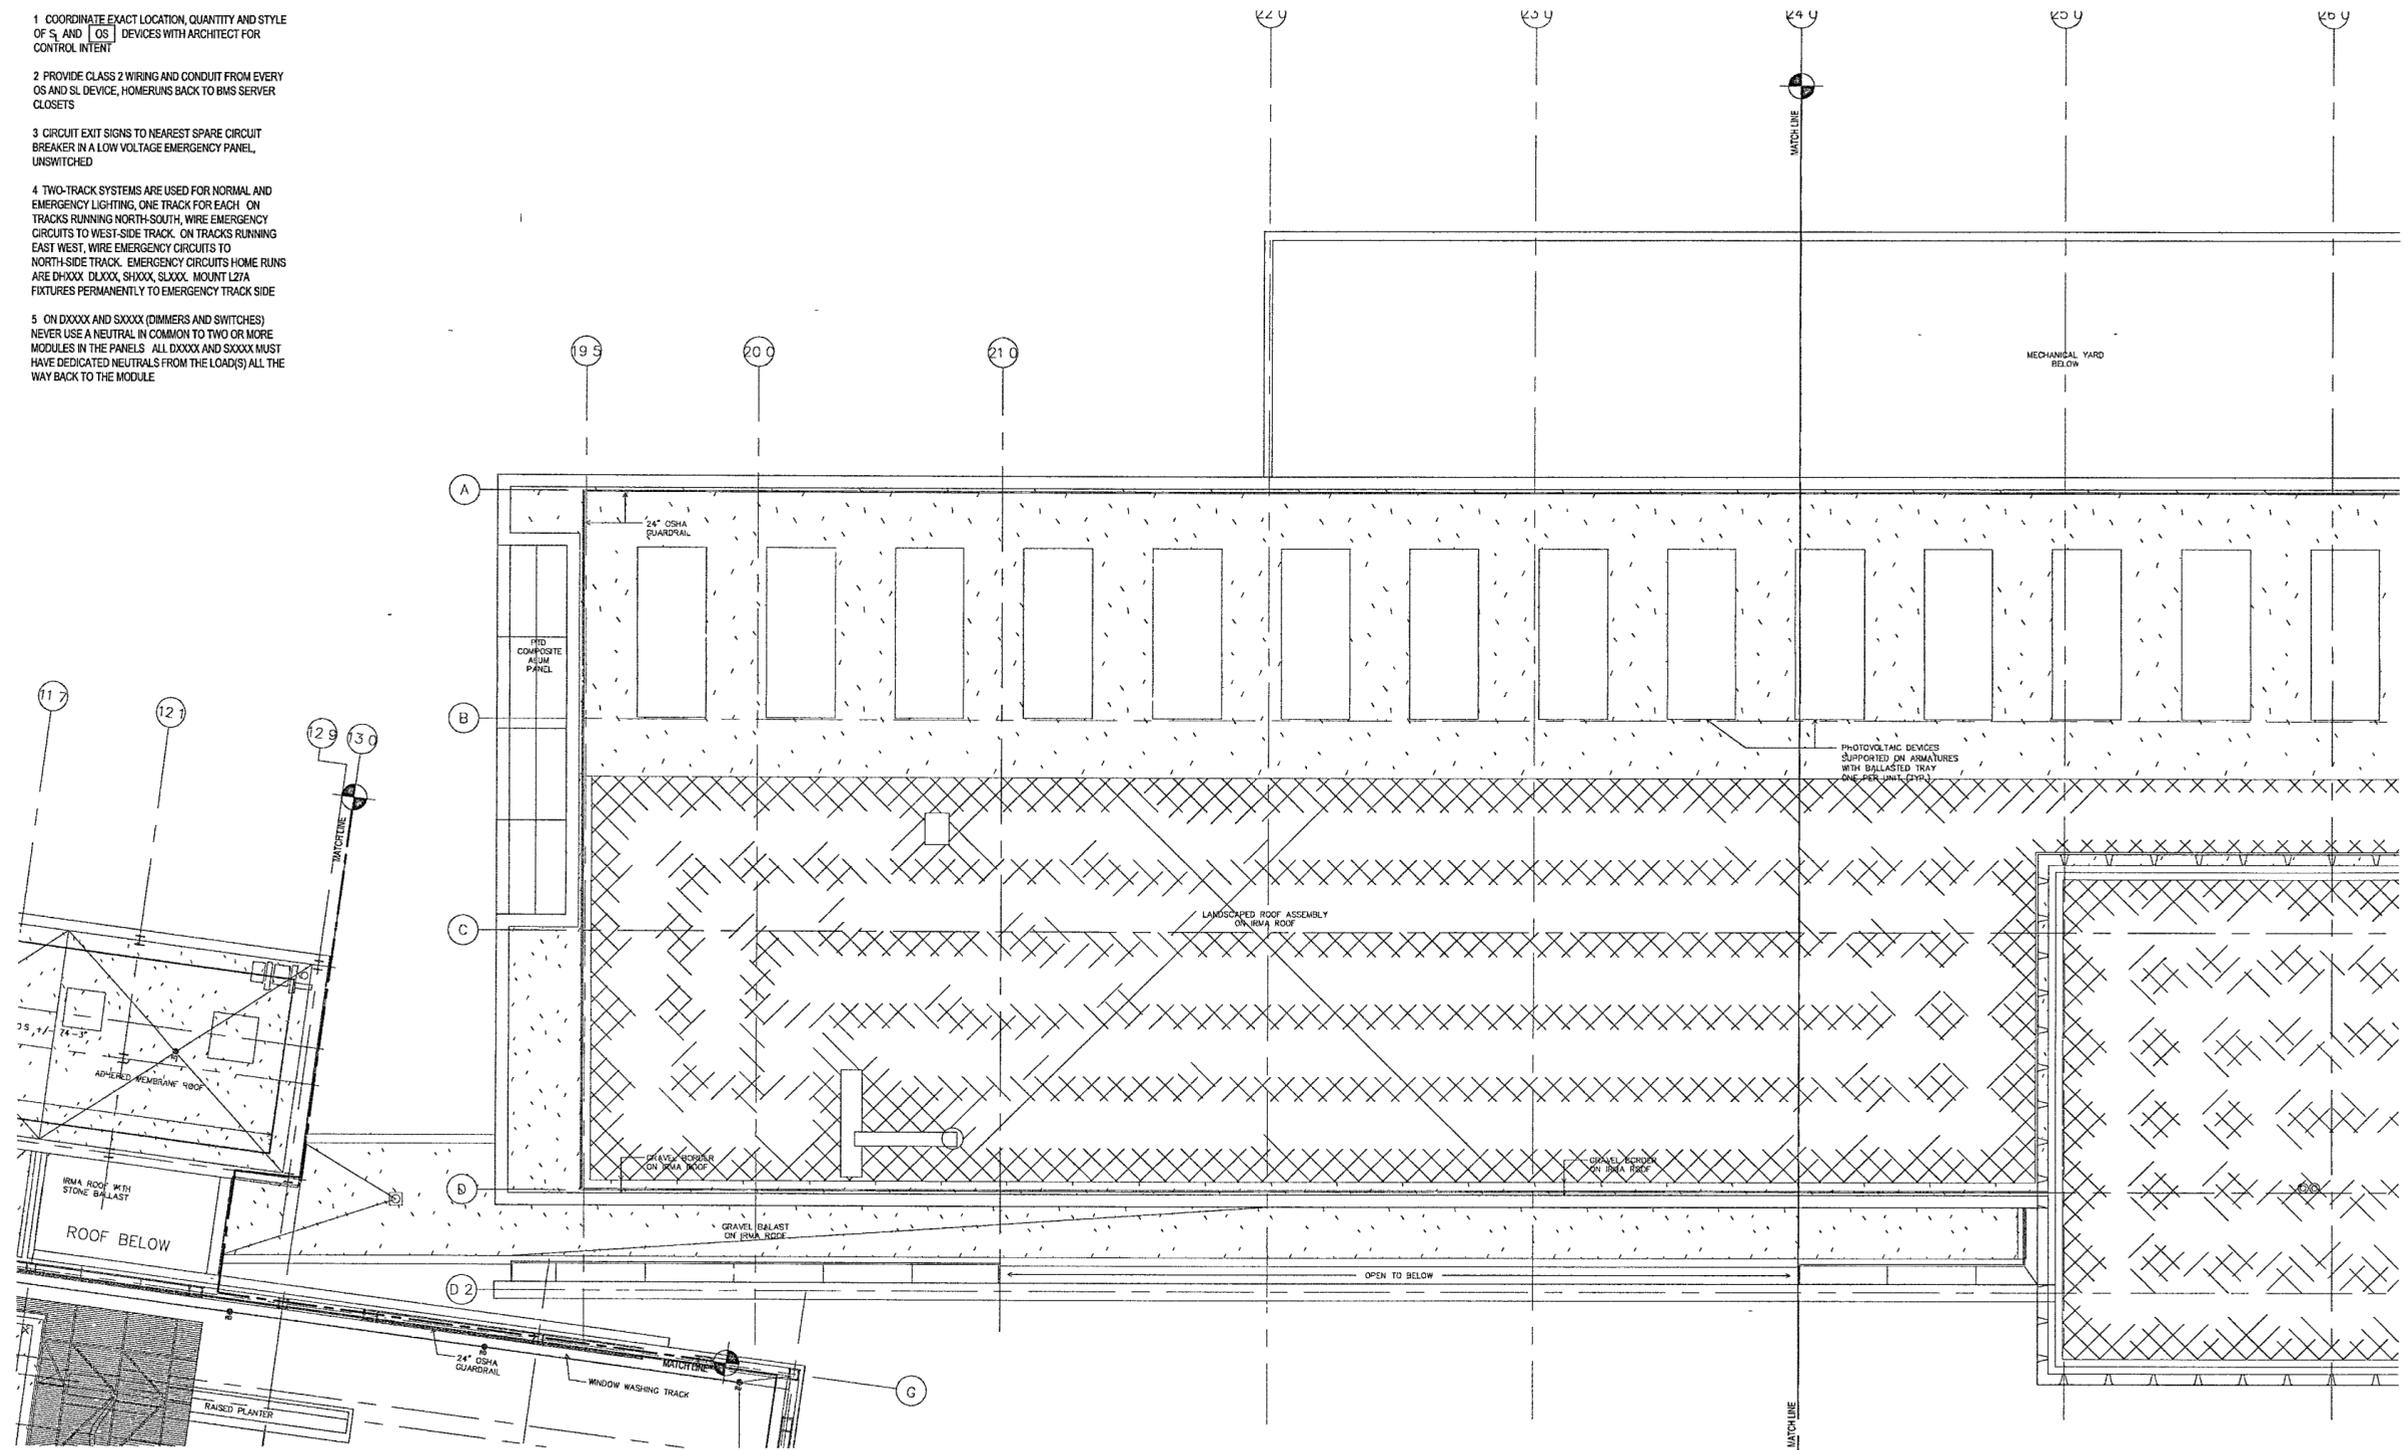

1 ROOF AREA C LIGHTING PLAN
 E206c | E206c 1/8" = 1'-0"
 0 4 8 16 24
 NORTH

**WILLIAM J CLINTON
 PRESIDENTIAL
 CENTER**

LITTLE ROCK, ARKANSAS
 Architect
 POLSHEK PARTNERSHIP LLP
 320 West 13th Street
 New York, New York 10014
 212.807.7171

Coordinating Architects
 POLK STANLEY YEARY ARCHITECTS Ltd
 700 South Saltillo Street
 Little Rock, Arkansas 72201
 501.378.0878

WITSELL EVANS RASCO
 901 West Third Street
 Little Rock, Arkansas 72201
 501.374.5300

WOODS CARADINE ARCHITECTS
 2200 South Main Street
 Little Rock, Arkansas 72206
 501.374.4060

Landscape Architects
 HARGREAVES ASSOCIATES
 118 Magazine Street
 Cambridge, Massachusetts 02139
 617.661.0070


LANDSCAPE ARCHITECTURE, Inc.
 2300 Cottondale Lane Suite 202
 Little Rock, Arkansas 72202
 501.374.5610

Structural Engineer
 LESLIE E. ROBERTSON ASSOC., PLLP
 30 Broad Street, 4th Floor
 New York, New York 10004
 212.750.9000


MEP Engineers
 FLACK + KURTZ Inc.
 475 Fifth Avenue
 New York, New York 10017
 212.532.9600

CROMWELL ARCHITECTS ENGINEERS
 101 South Spring Street
 Little Rock, Arkansas 72201
 501.372.2900

Curtilwall Consultant
 R. A. HEINTGES ARCHITECTS
 126 Fifth Avenue 9th Floor
 New York, New York 10011
 212.652.2966

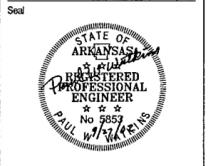

100% Construction Documents	09/27/02
90% Progress Printing	08/30/02
100% Design Development	03/01/02
Issue	Date

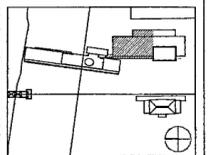

Job No. POLSHEK & PARTNERS ARCH. 9908
 CROMWELL AE 89-114
 Scale 1/8" = 1'-0"
 Date SEPTEMBER 27, 2002

**ROOF
 AREA C
 LIGHTING PLAN**

Sheet No. **E206c**



FOR OFFICIAL USE ONLY