

**WILLIAM J CLINTON
PRESIDENTIAL
CENTER**

LITTLE ROCK, ARKANSAS

Architect
POLSHKE PARTNERSHIP LLP
320 West 13th Street
New York, New York 10014
212.807.7171

Coordinating Architects
POLK STANLEY YEARY ARCHITECTS, Ltd
700 South Schaller Street
Little Rock, Arkansas 72201
501.378.0878

WITSELL EVANS RASCO
901 West Third Street
Little Rock, Arkansas 72201
501.374.5300

WOODS CARADINE ARCHITECTS
2200 South Main Street
Little Rock, Arkansas 72206
501.374.4060

Landscape Architects
HARGREAVES ASSOCIATES
118 Magazine Street
Cambridge, Massachusetts 02139
617.661.0070


LANDSCAPE ARCHITECTURE, Inc.
2300 Cottondale Lane Suite 202
Little Rock, Arkansas 72202
501.374.5910

Structural Engineer
LESLIE E. ROBERTSON ASSOC. R.L.P.
30 Broad Street, 47th Floor
New York, New York 10004
212.750.9000


MEP Engineers
FLACK + KURTZ, Inc.
475 5th Avenue
New York, New York 10017
212.532.9600

CROMWELL ARCHITECTS ENGINEERS
101 South Spring Street
Little Rock, Arkansas 72201
501.372.2900

Curtilaw Consultant
R. A. HEINTGES ARCHITECTS
126 5th Avenue, 9th Floor
New York, New York 10011
212.652.2966

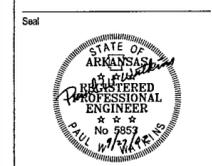

Issue	Date
100% Construction Documents	09/27/02
50% Progress Printing	08/09/02
100% Design Development	03/01/02

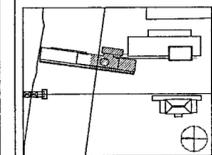


Job No. POLSHKE & PARTNERS ARCH 9908
CROMWELL AE 99-114

Scale 1/8" = 1'-0"
Date SEPTEMBER 27, 2002


**BASEMENT LEVEL
AREA B
FIRE ALARM
PLAN**

Sheet No. **FA100b**

- KEYED NOTES**
- ◇ REMOTE FIRE ALARM PANEL TO BE INSTALLED AS NEEDED BY CONTRACTOR. NUMBER TO BE ESTABLISHED WITH SHOP DRAWINGS
 - ◇ KITCHEN HOOD SUPPRESSION SYSTEM
 - ◇ 3 NACZONE SHALL MATCH 3 HOUR OCCUPANCY SEPARATION WHICH MAY SHIFT SLIGHTLY TO THE SOUTH COORDINATE WITH ARCHITECT PRIOR TO INSTALLATION
 - ◇ ZONE ISOLATION VALVE

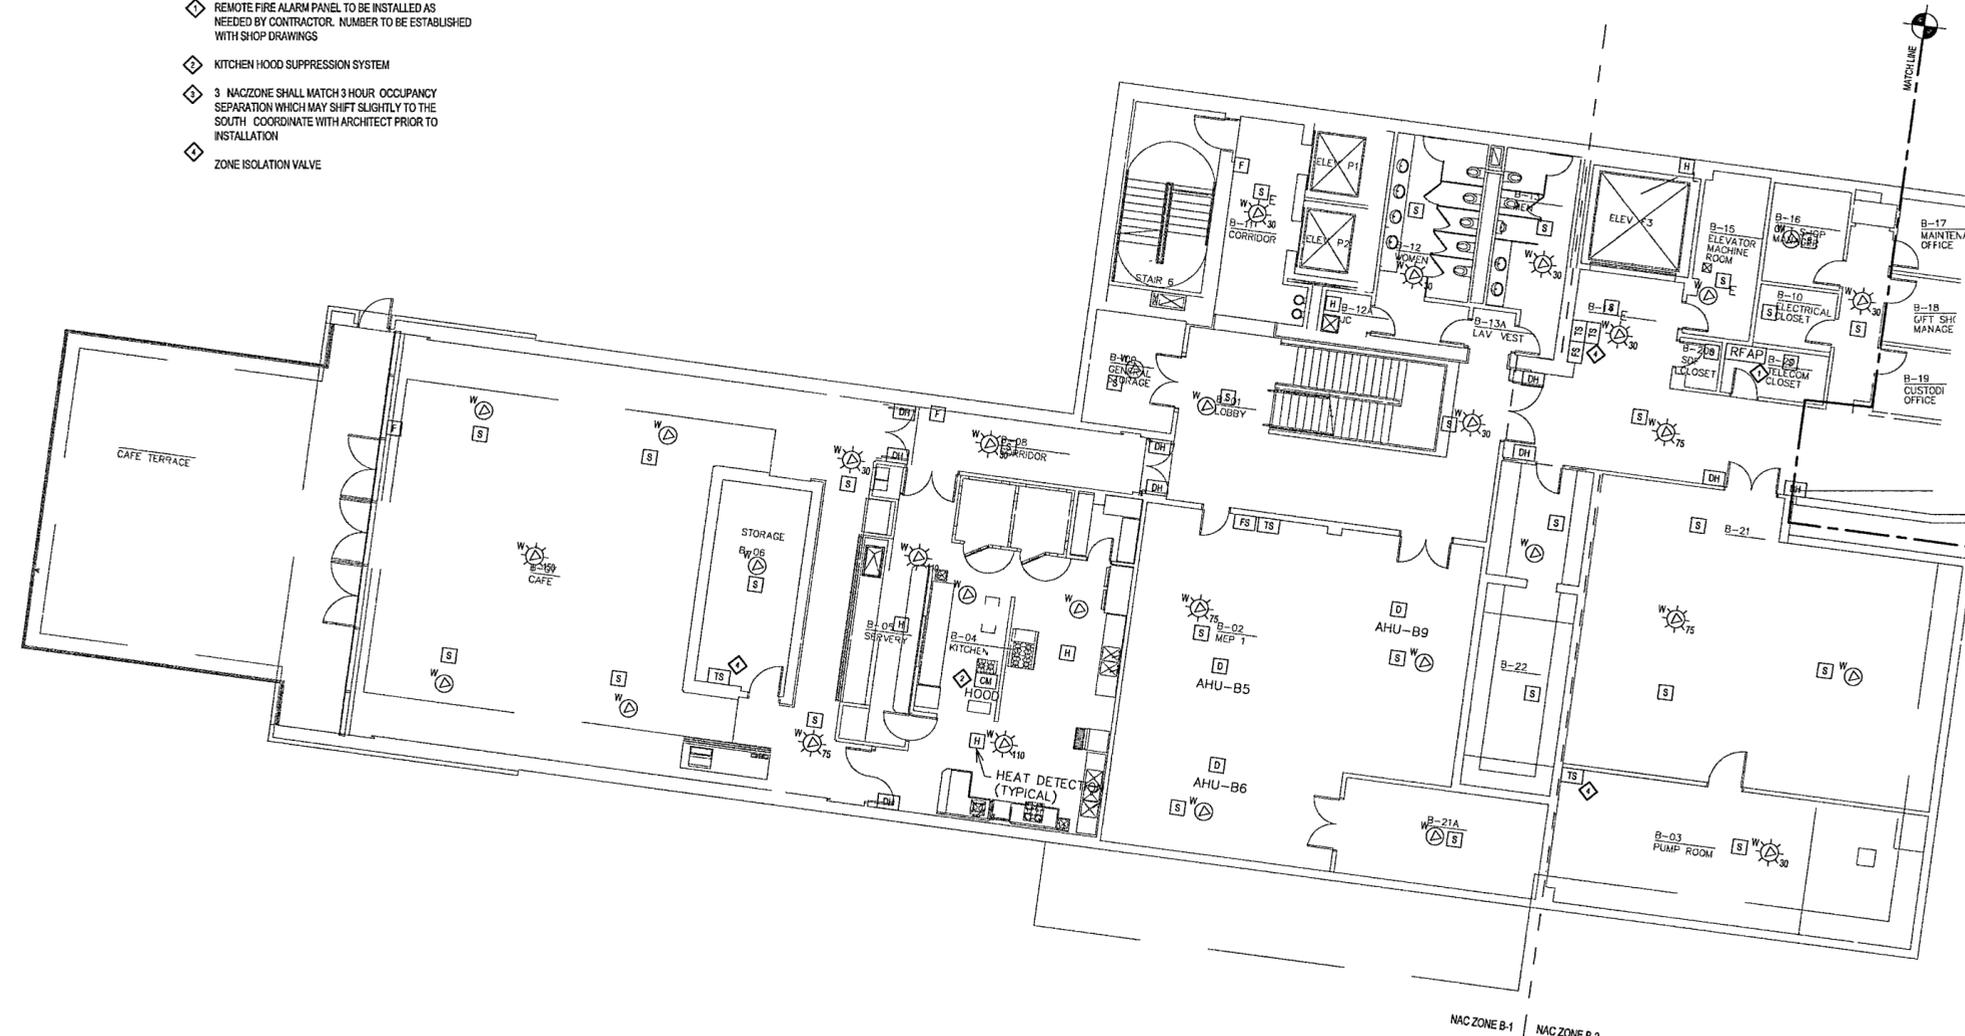

1 BASEMENT LEVEL AREA B FIRE ALARM PLAN
FA100b | FA100d 1/8" = 1'-0"

 

FOR OFFICIAL USE ONLY