

**WILLIAM J. CLINTON
PRESIDENTIAL
CENTER**

LITTLE ROCK, ARKANSAS

Architect
POLSHEK PARTNERSHIP LLP
320 West 13th Street
New York, New York 10014
212.807.7171

Coordinating Architects
POLK STANLEY YEARY ARCHITECTS, Ltd
700 South Saline Street
Little Rock, Arkansas 72201
501.378.0878

WITSELL EVANS RASCO
901 West Third Street
Little Rock, Arkansas 72201
501.374.5300

WOODS CARADINE ARCHITECTS
2200 South Main Street
Little Rock, Arkansas 72206
501.374.4060

Landscape Architects
HARGREAVES ASSOCIATES
118 Magazine Street
Cambridge, Massachusetts 02139
617.861.0070


LANDSCAPE ARCHITECTURE, Inc.
2300 Cottondale Lane Suite 202
Little Rock, Arkansas 72202
501.374.5610

Structural Engineer
LESLIE E. ROBERTSON ASSOC. R.L.P.
30 Broad Street, 4th Floor
New York, New York 10004
212.750.9000


MEP Engineers
FLACK + KURTZ Inc.
475 Fifth Avenue
New York, New York 10017
212.532.9600

CROMWELL ARCHITECTS ENGINEERS
101 South Spring Street
Little Rock, Arkansas 72201
501.372.2900

Curtainwall Consultant
R. A. HEINTGES ARCHITECTS
126 Fifth Avenue, 9th Floor
New York, New York 10011
212.652.2966

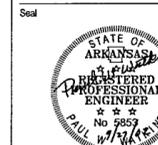

Issue	Date
100% Construction Documents	09/27/02
90% Progress Printing	08/30/02
100% Design Development	03/01/02

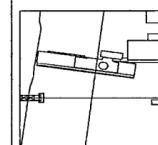

Job No: POLSHEK & PARTNERS ARCH 9908
CROMWELL AE 99-114

Scale: 1/8" = 1'-0"

Date: SEPTEMBER 27, 2002


**BASEMENT LEVEL
AREA D FIRE ALARM
PLAN**

Sheet No:

FA100d



FOR OFFICIAL USE ONLY

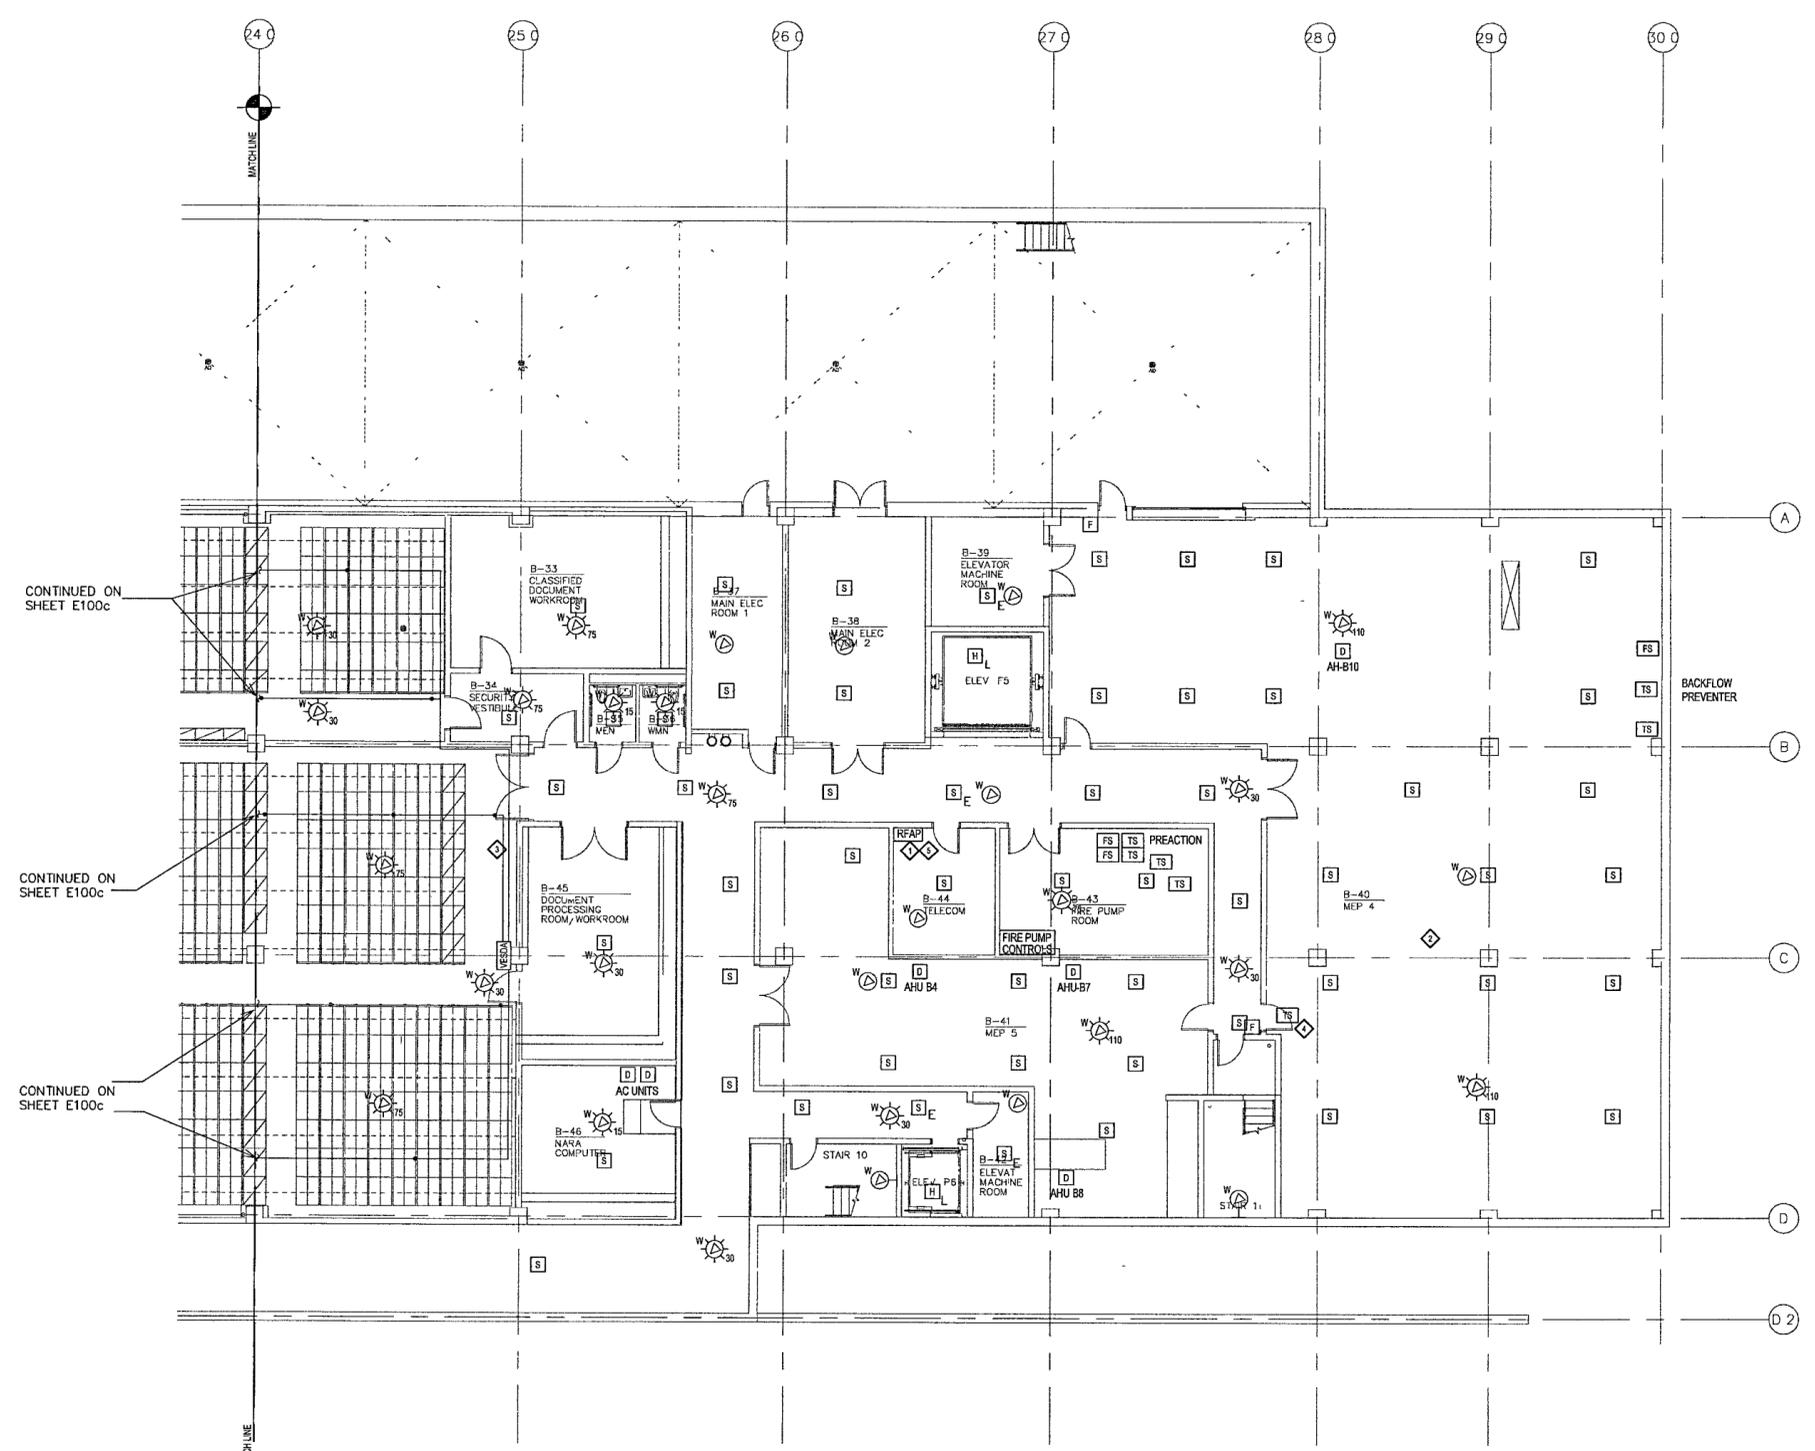

- KEYED NOTES**
- ◆ REMOVE FIRE ALARM PANEL(S) AS NEEDED BY INSTALLING CONTRACTOR.
 - ◆ SMOKE DETECTORS HAVE A REDUCED AREA OF COVERAGE TO COMPENSATE FOR WAFFLE CEILING CONFIGURATION.
 - ◆ ARCHIVE STORAGE AREAS UTILIZE A VESDA DETECTION SYSTEM WITH REDUCED SPACING AND GREATER SENSITIVITY OVER CONVENTIONAL SPOT DETECTORS TO ACCOUNT FOR POCKETS WITH WAFFLE CEILING CONFIGURATION.
 - ◆ SEE SHEET FAS00 FOR ADDITIONAL VESDA SYSTEM INFORMATION.
 - ◆ ISOLATION VALVE
 - ◆ REMOTE POWER SUPPLY FOR VESDA DETECTORS

1 BASEMENT LEVEL AREA D FIRE ALARM PLAN
FA100d | FA100d 1/8" = 1'-0"



CONTINUED ON SHEET E100c

MATCHLINE