

**WILLIAM J CLINTON  
PRESIDENTIAL  
CENTER**

LITTLE ROCK, ARKANSAS

Architect  
POLSHEK PARTNERSHIP LLP  
320 West 139 Street  
New York, New York 10014  
212 807 7171

Coordinating Architects  
POLK STANLEY YEARY ARCHITECTS, Ltd  
700 South Schiller Street  
Little Rock, Arkansas 72201  
501 378 0878

WITSELL EVANS HASCO  
901 West Third Street  
Little Rock, Arkansas 72201  
501 374 5300

WOODS CARADINE ARCHITECTS  
2200 South Main Street  
Little Rock, Arkansas 72206  
501 374 4060

Landscape Architects  
HARGREAVES ASSOCIATES  
118 Magazine Street  
Cambridge, Massachusetts 02139  
617.651.0070

LANDSCAPE ARCHITECTURE, Inc.  
2300 Cotondale Lane Suite 202  
Little Rock, Arkansas 72202  
501 374 5810

Structural Engineer  
LESLIE E ROBERTSON ASSOC RLLP  
30 Broad Street 47th Floor  
New York, New York 10004  
212 591 9000


MEP Engineers  
FLACK + KURTZ Inc.  
475 Fifth Avenue  
New York, New York 10017  
212 532.9600

CROMWELL ARCHITECTS ENGINEERS  
101 South Spring Street  
Little Rock, Arkansas 72201  
501 372.2500

Curtainwall Consultant  
R. A. HEINTGES ARCHITECTS  
128 Fifth Avenue, 9th Floor  
New York, New York 10011  
212.632.2956



Revision	Date
100% Construction Documents	09/27/02
90% Progress Printing	08/30/02
100% Design Development	03/01/02
Issue	Date

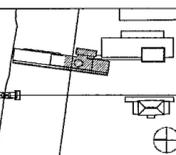

Job No POLSHEK & PARTNERS ARCH 9908

CROMWELL AE 99-114

Scale 1/8" = 1'-0"

Date SEPTEMBER 27 2002


Title **GROUND LEVEL  
AREA B FIRE ALARM  
PLAN**

Sheet No

**FA101b**



**FOR OFFICIAL USE ONLY**

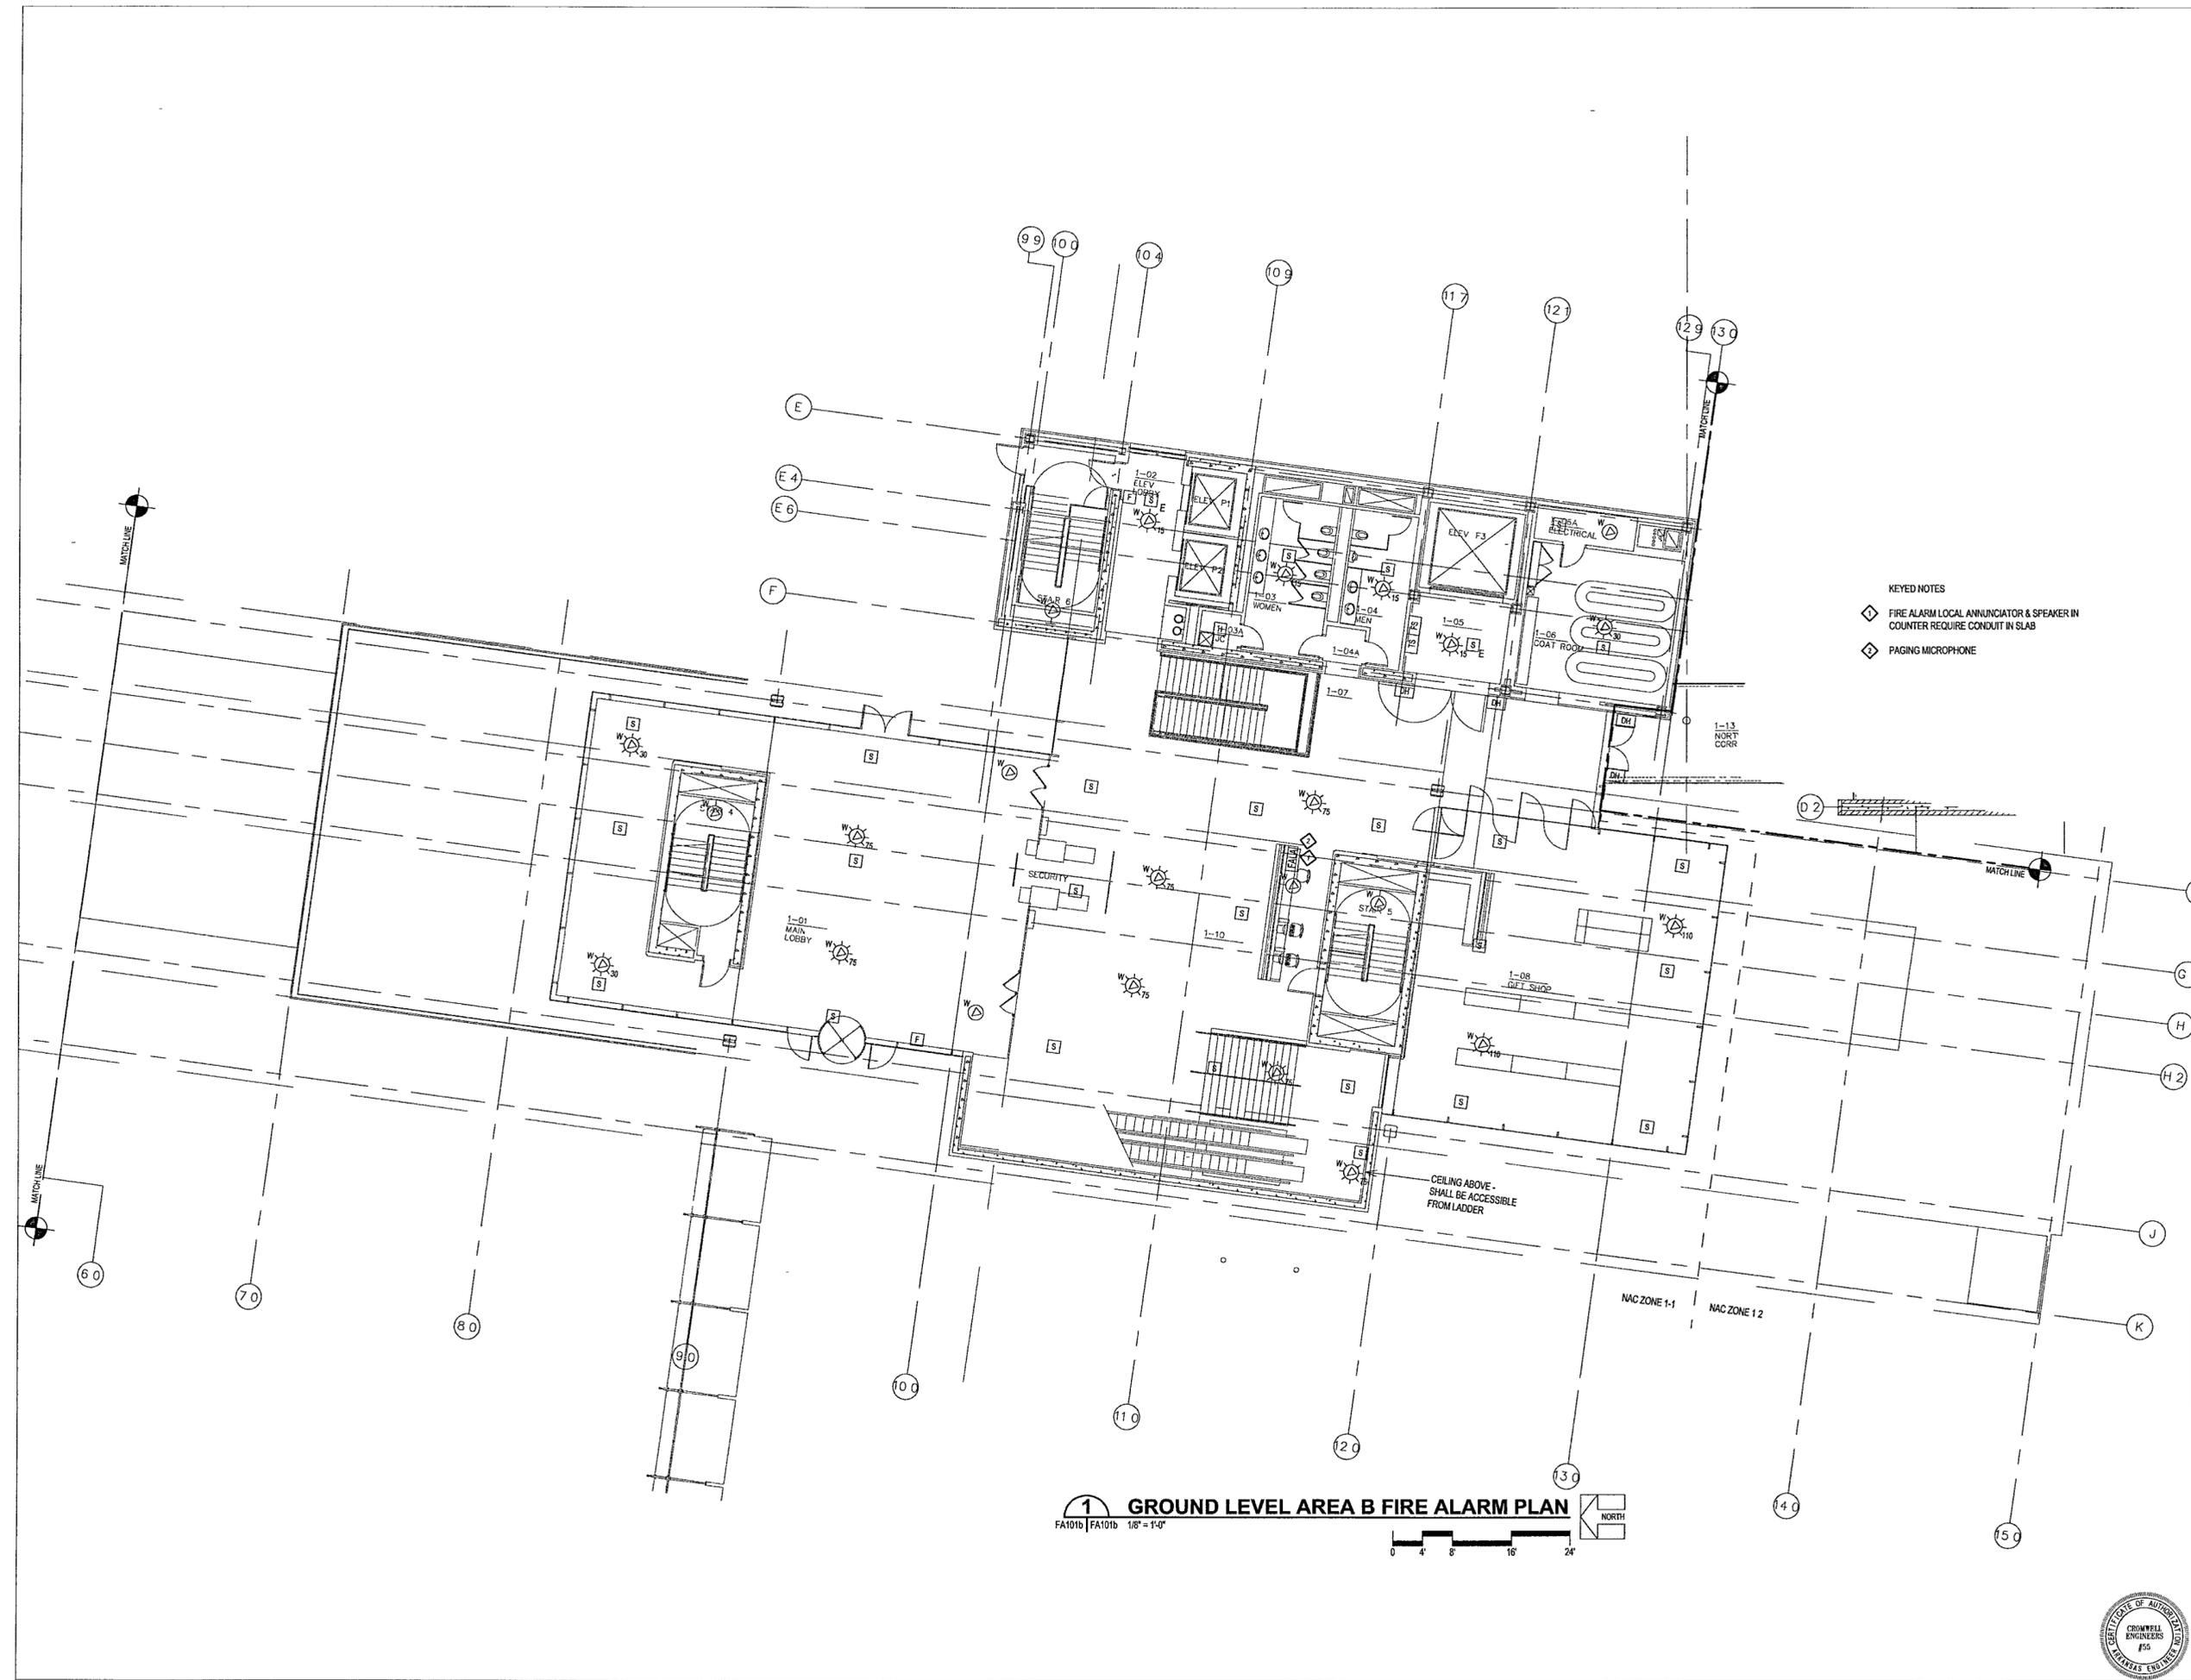

**1 GROUND LEVEL AREA B FIRE ALARM PLAN**  
FA101b | FA101b 1/8" = 1'-0"



19