

**WILLIAM J CLINTON  
PRESIDENTIAL  
CENTER**

LITTLE ROCK ARKANSAS

Architect  
POLSHEK PARTNERSHIP LLP  
320 West 13th Street  
New York, New York 10014  
212.807.7171

Coordinating Architects  
POLK STANLEY YEARY ARCHITECTS Ltd  
700 South Schiller Street  
Little Rock, Arkansas 72201  
501.378.0873

WITSELL EVANS RASCO  
901 West Third Street  
Little Rock, Arkansas 72201  
501.374.5300

WOODS CARADINE ARCHITECTS  
2200 South Main Street  
Little Rock, Arkansas 72206  
501.374.4060

Landscape Architects  
HARGREAVES ASSOCIATES  
118 Magazine Street  
Cambridge, Massachusetts 02139  
617.661.0070

LANDSCAPE ARCHITECTURE, Inc.  
2300 Cottondale Lane Suite 202  
Little Rock, Arkansas 72202  
501.374.9610


Structural Engineer  
LESLIE E. ROBERTSON ASSOC. RLP  
30 Broad Street, 4th Floor  
New York, New York 10004  
212.759.9000

MEP Engineers  
FLACK + KURTZ Inc.  
475 Fifth Avenue  
New York, New York 10017  
212.532.9600


CROMWELL ARCHITECTS ENGINEERS  
101 South Spring Street  
Little Rock, Arkansas 72201  
501.372.2900

Urbanwall Consultant  
R. A. HEINTGES ARCHITECTS  
126 Fifth Avenue, 9th Floor  
New York, New York 10011  
212.632.2966

- KEYED NOTES**
- ◆ FIRE ALARM LOCAL ANNUNCIATOR IN CONSOLE
  - ◆ PAGING MICROPHONE
  - ◆ DEVICES SHALL STAY OUTSIDE OF ELECTRICALLY CLASSIFIED ZONE/AREA OF PAINT VAPORS
  - ◆ ARCHIVE STORAGE AREAS UTILIZE A VESDA DETECTION SYSTEM WITH REDUCED SPACING AND GREATER SENSITIVITY OVER CONVENTIONAL SPOT DETECTORS TO ACCOUNT FOR POCKETS OF WAFFLE CEILING CONFIGURATION
- SEE SHEET FA501 FOR ADDITIONAL VESDA SYSTEM INFORMATION

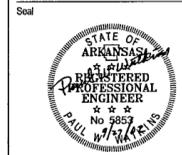

Issue	Date
100% Construction Documents	09/27/02
90% Progress Printing	08/30/02
100% Design Development	03/01/02

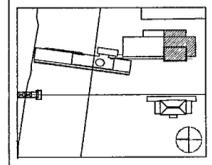


Job No: POLSHEK & PARTNERS ARCH 0908  
CROMWELL AE 99-114

Scale: 1/8" = 1'-0"


Date: SEPTEMBER 27 2002

Title: **GROUND LEVEL  
AREA D FIRE ALARM  
PLAN**

 Sheet No: **FA101d**



**FOR OFFICIAL USE ONLY**

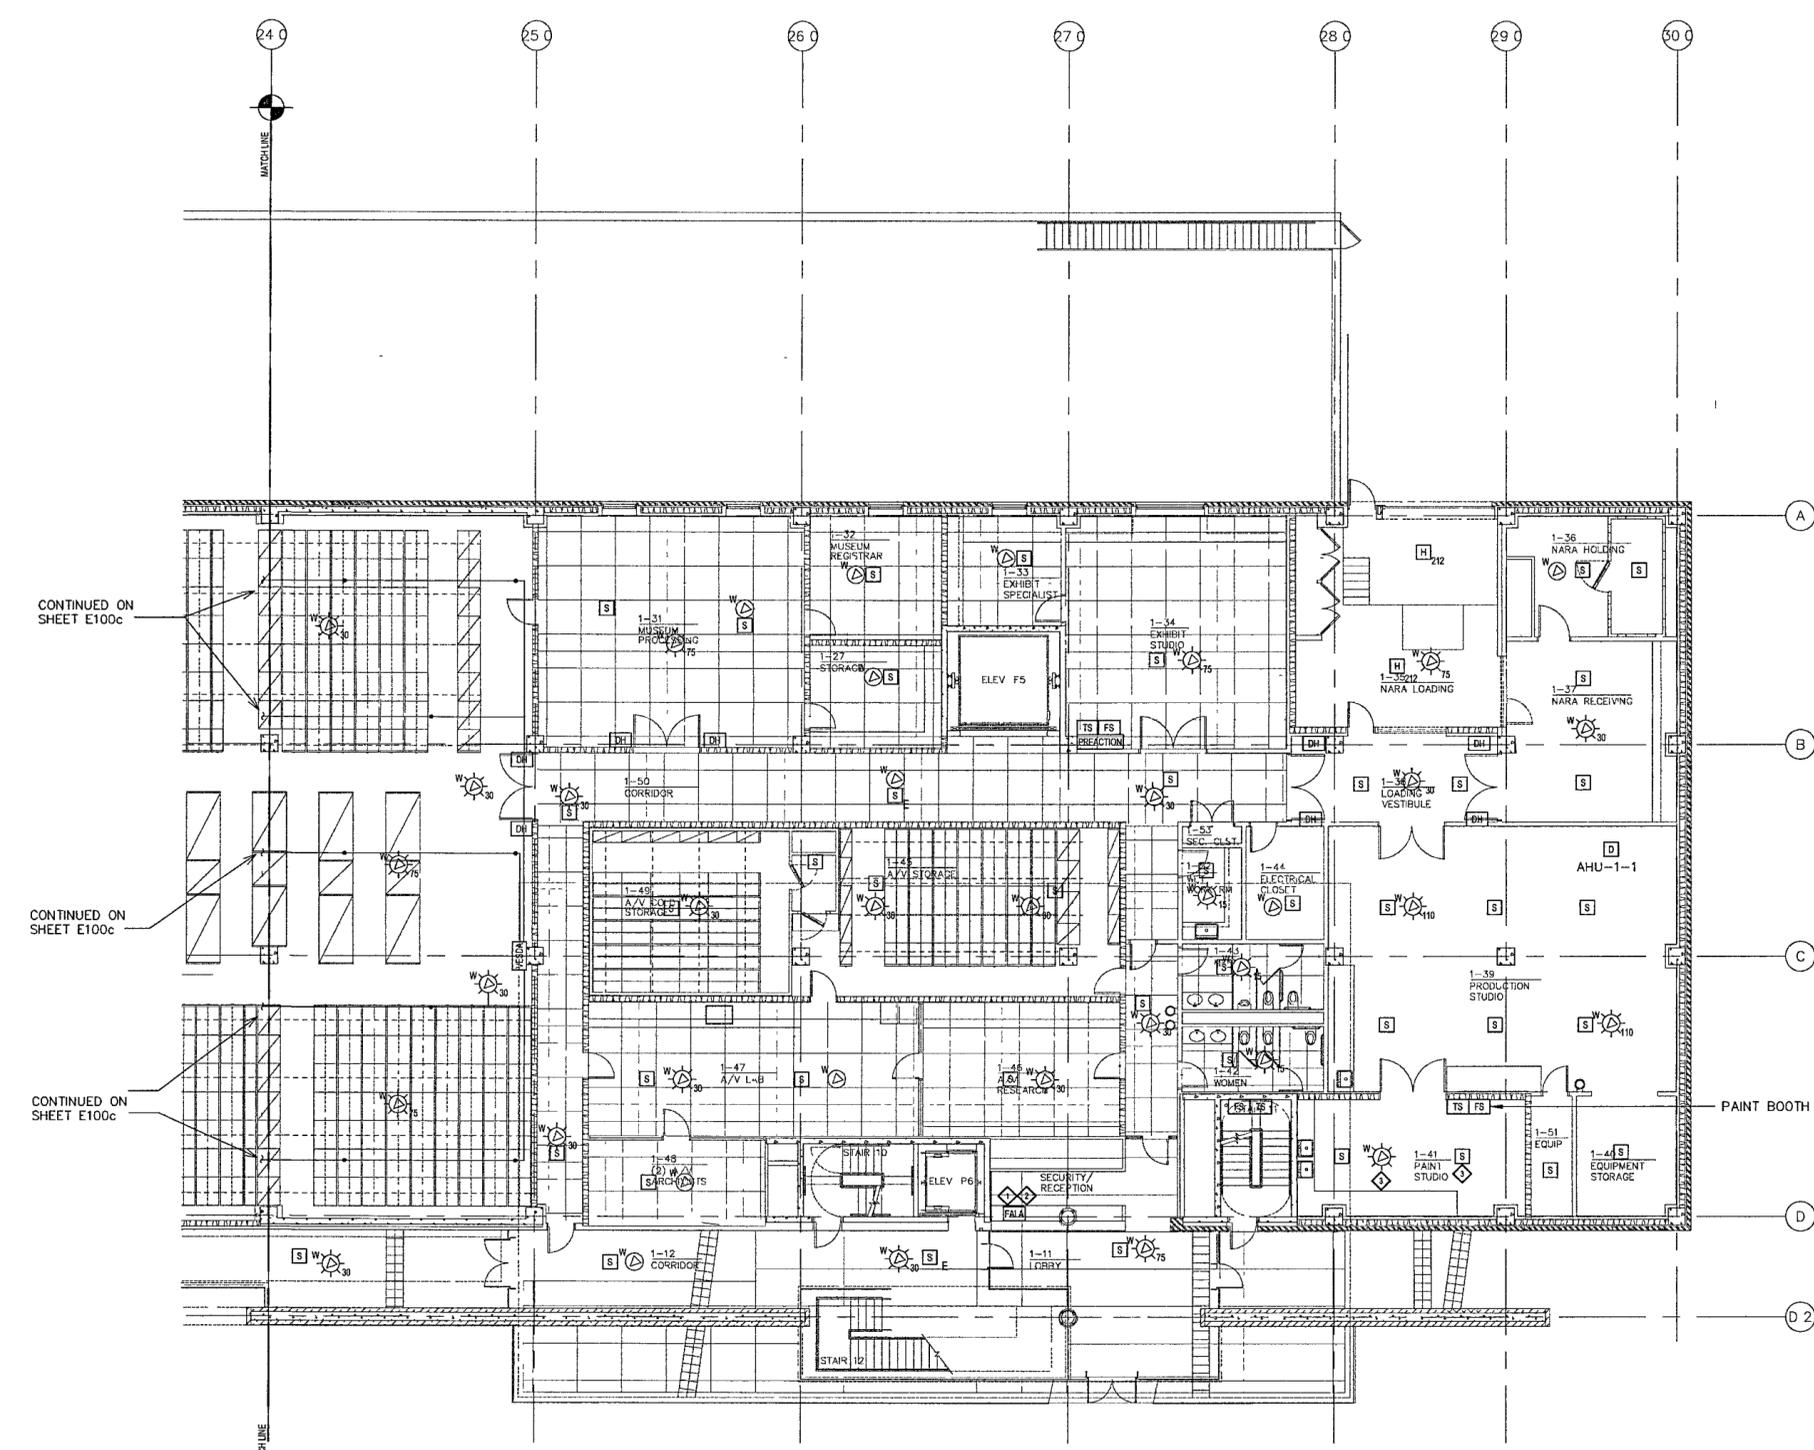

**1 GROUND LEVEL AREA D FIRE ALARM PLAN**  
FA101d FA101d 1/8" = 1'-0"  
NORTH  
0 4' 8' 16' 24'

CONTINUED ON SHEET E100c