

**WILLIAM J CLINTON
PRESIDENTIAL
CENTER**

LITTLE ROCK, ARKANSAS

Architect

POLSHEK PARTNERSHIP LLP
320 West 13th Street
New York, New York 10014
212.807.7171

Coordinating Architects

POLK STANLEY YEARY ARCHITECTS Ltd
701 South Schiller Street
Little Rock, Arkansas 72201
501.378.0878

WITSELL EVANS RASCO
901 West Third Street
Little Rock, Arkansas 72201
501.374.5300

WOODS CARADINE ARCHITECTS
2200 South Main Street
Little Rock, Arkansas 72206
501.374.4000

Landscape Architects

HARGREAVES ASSOCIATES
118 Magazine Street
Cambridge Massachusetts 02139
617.661.0070

LANDSCAPE ARCHITECTURE, Inc.
2300 Cottontale Lane Suite 202
Little Rock Arkansas 72202
501.374.5810

Structural Engineer

LESLIE E. ROBERTSON ASSOC. RLLP
30 Broad Street, 4th Floor
New York, New York 10004-
212.750.9000

MEP Engineers

FLACK + KURTZ Inc.
475 Fifth Avenue
New York, New York 10017
212.532.9600

CROMWELL ARCHITECTS ENGINEERS

101 South Spring Street
Little Rock, Arkansas 72201
501.372.2300


Curtainwall Consultant

R. A. HEINTGES ARCHITECTS
128 Fifth Avenue 9th Floor
New York, New York 10011
212.632.2866

Seal



Issue	Date
100% Construction Documents	09/27/02
90% Progress Printing	08/30/02
100% Design Development	03/01/02

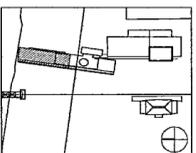

Job No. POLSHEK & PARTNERS ARCH 9908
CROMWELL AE 89-114

Scale 1/8" = 1'-0"

Date SEPTEMBER 27, 2002


Title **SECOND LEVEL
AREA A
FIRE ALARM PLAN**

Sheet No.

FA102a



FOR OFFICIAL USE ONLY

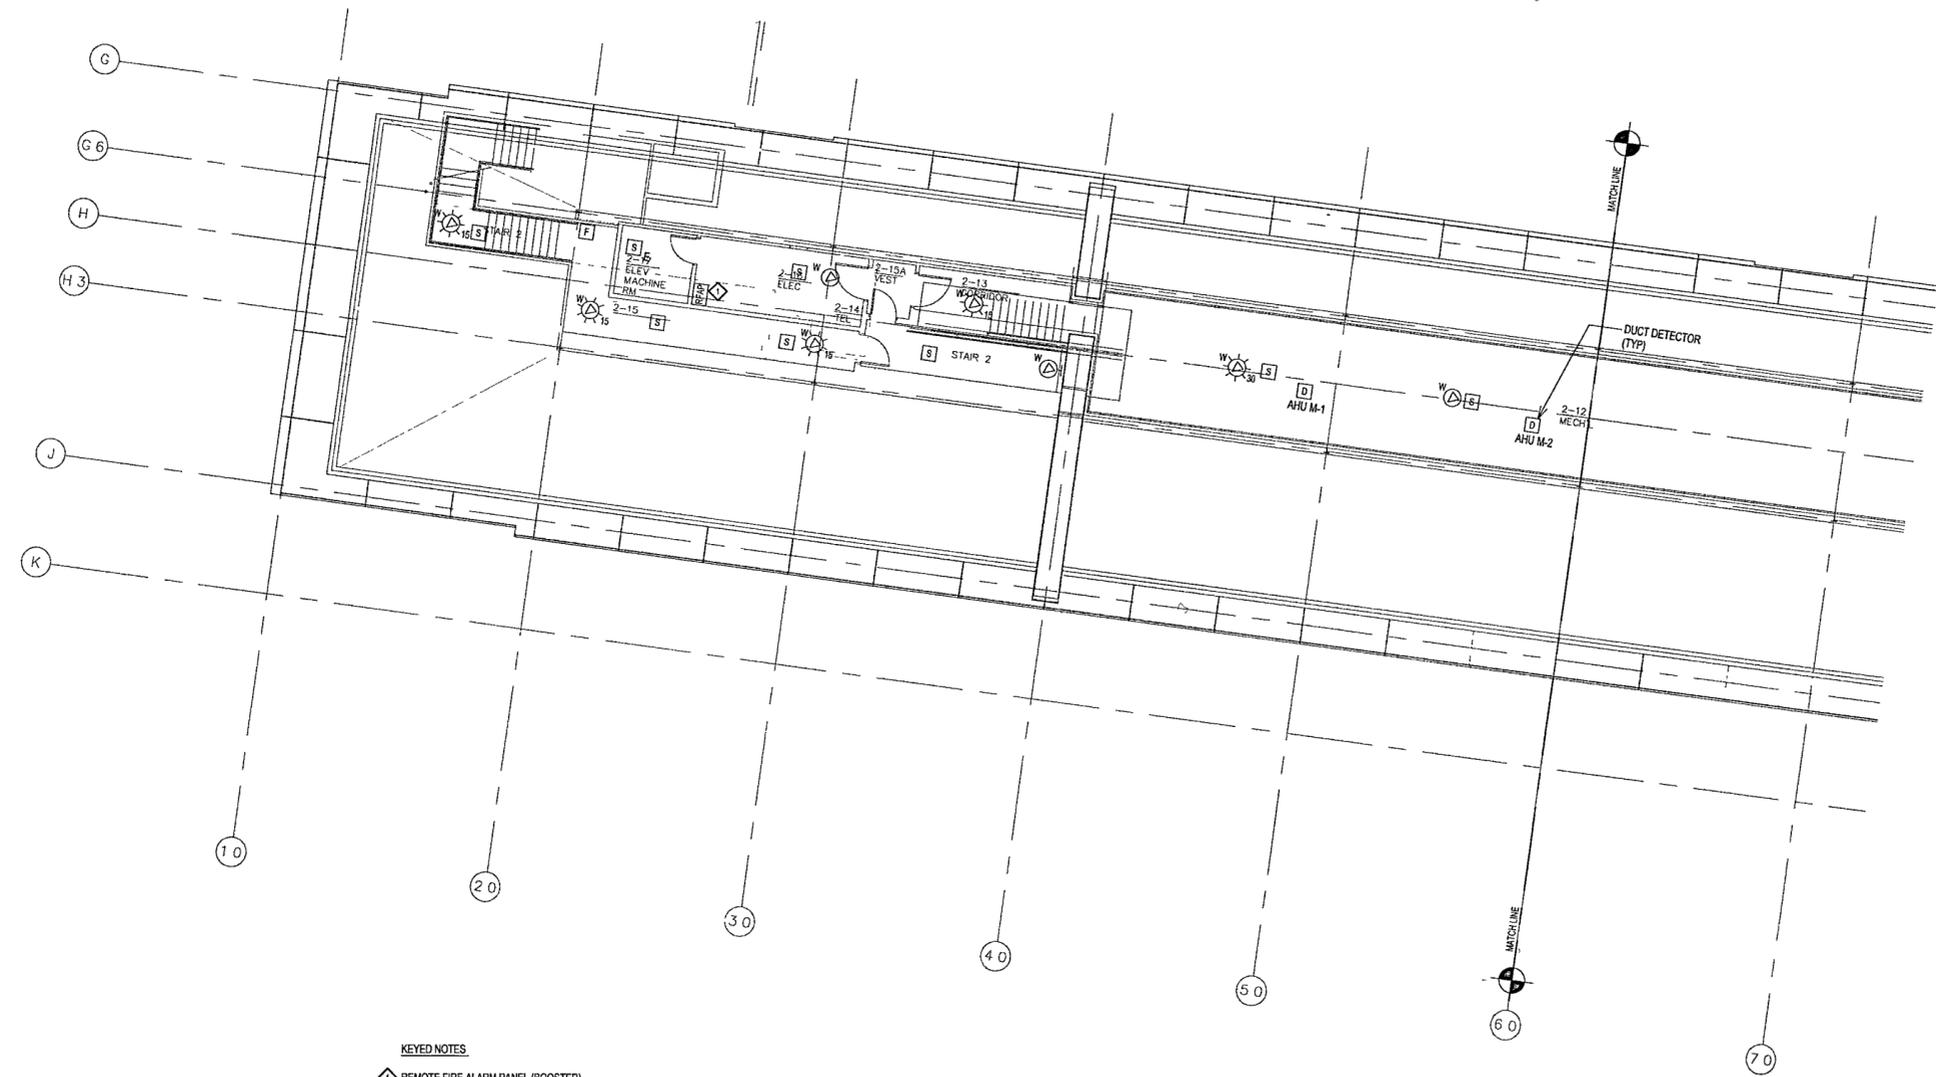

KEYED NOTES
◊ REMOTE FIRE ALARM PANEL (BOOSTER)
AS NEEDED BY CONTRACTOR.

1 SECOND LEVEL AREA A FIRE ALARM PLAN
FA102a | FA102a 1/8" = 1'-0"
0 4' 8' 16' 24'
NORTH

12-20