

**WILLIAM J CLINTON
PRESIDENTIAL
CENTER**

LITTLE ROCK, ARKANSAS

Architect
POLSHKE PARTNERSHIP LLP
320 West 13th Street
New York, New York 10014
212.607.7171

Coordinating Architects
POLK STANLEY YEARY ARCHITECTS, Ltd
700 South Schiller Street
Little Rock, Arkansas 72201
501.378.0878

WITSELL EVANS RASCO
901 West Third Street
Little Rock, Arkansas 72201
501.374.5300

WOODS CARADINE ARCHITECTS
2200 South Main Street
Little Rock, Arkansas 72206
501.374.4060

Landscape Architects
HARGREAVES ASSOCIATES
118 Magazine Street
Cambridge, Massachusetts 02139
617.661.0070


LANDSCAPE ARCHITECTURE, Inc.
2300 Cottondale Lane Suite 202
Little Rock, Arkansas 72202
501.374.5610

Structural Engineer
LESLIE E. ROBERTSON ASSOC. R.L.P.
30 Broad Street, 4th Floor
New York, New York 10004
212.750.9300


MEP Engineers
FLACK + KURTZ, Inc.
475 Fifth Avenue
New York, New York 10017
212.532.8600

CROMWELL ARCHITECTS ENGINEERS
101 South Spring Street
Little Rock, Arkansas 72201
501.372.2900

Curtilwall Consultant
R. A. HEINTGES ARCHITECTS
128 Fifth Avenue, 9th Floor
New York, New York 10011
212.652.2966

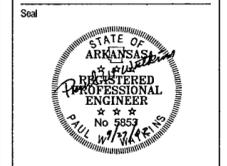

Issue	Date
100% Construction Documents	09/27/02
90% Progress Printing	09/30/02
100% Design Development	03/14/02

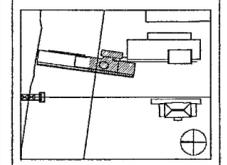

Job No. POLSHKE & PARTNERS ARCH 9808
CROMWELL AE 99-114



Scale: 1/8" = 1'-0"

Date: SEPTEMBER 27, 2002

Title: **SECOND LEVEL
AREA B
FIRE ALARM PLAN**

Sheet No.

 FA102b

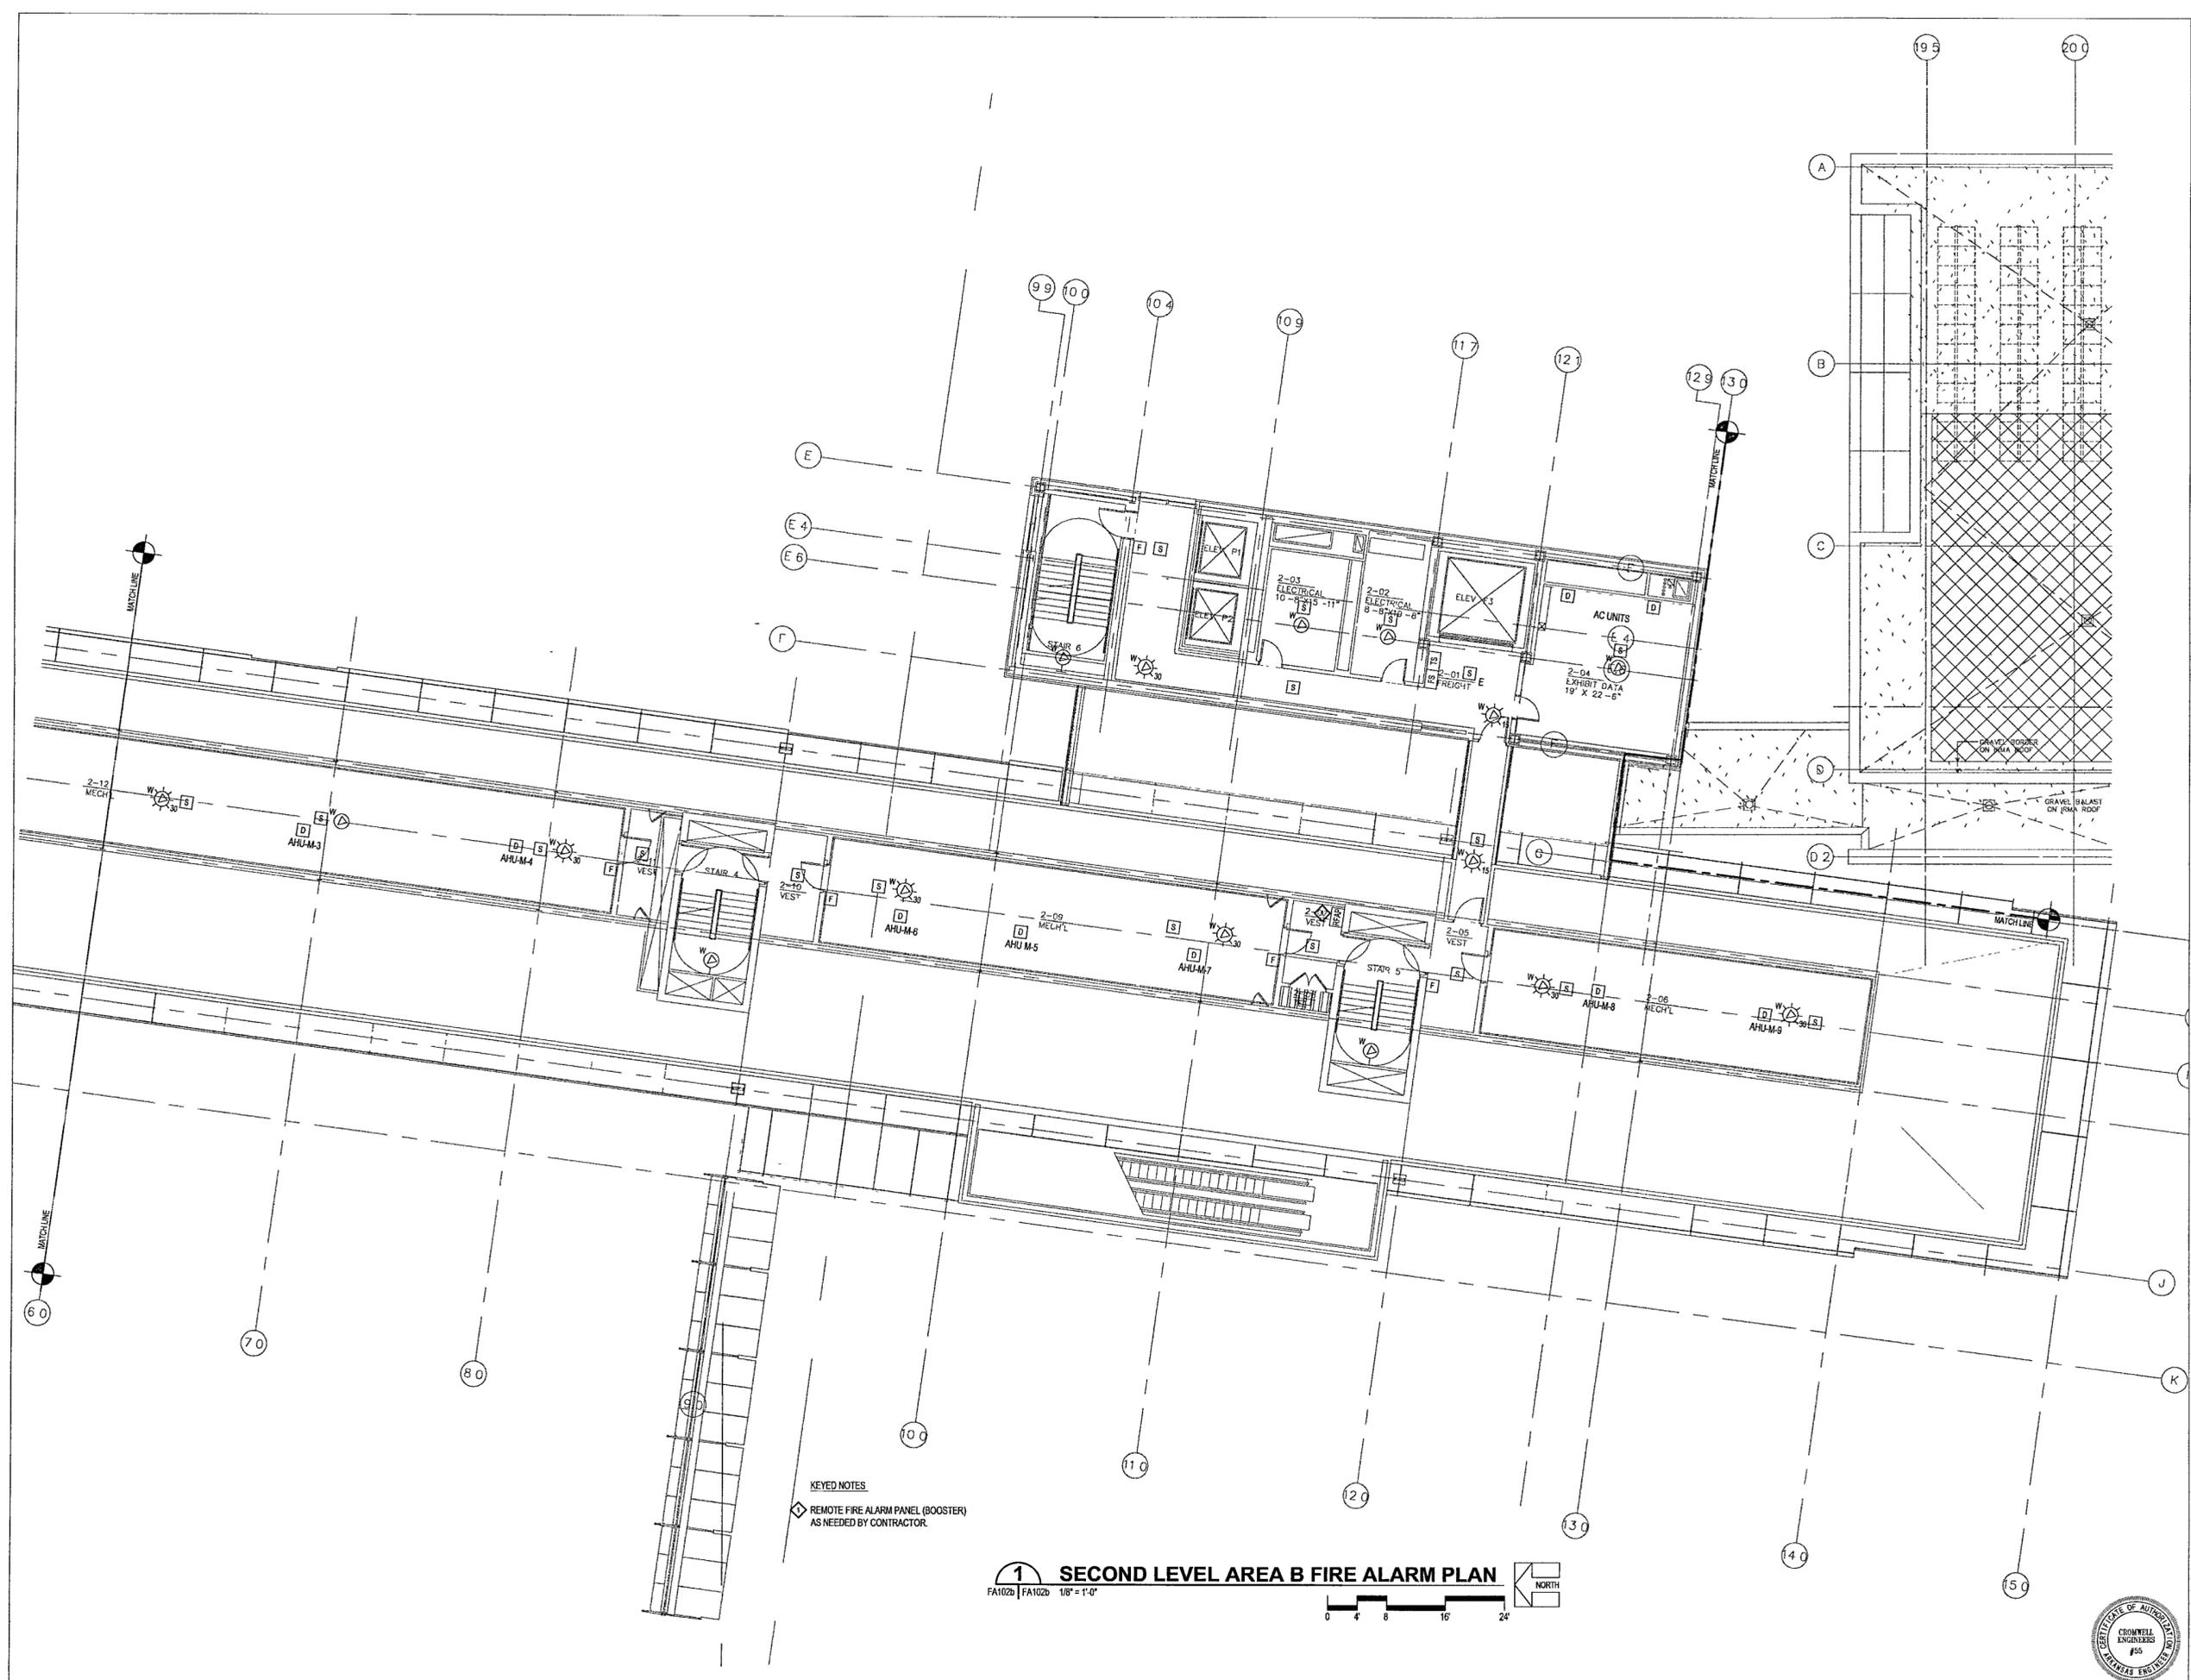

KEYED NOTES
 ◆ REMOTE FIRE ALARM PANEL (BOOSTER)
 AS NEEDED BY CONTRACTOR.

1 SECOND LEVEL AREA B FIRE ALARM PLAN
 FA102b | FA102b 1/8" = 1'-0"

