

**WILLIAM J CLINTON  
PRESIDENTIAL  
CENTER**

LITTLE ROCK, ARKANSAS

Architect  
POLSHEK PARTNERSHIP LLP  
320 West 13th Street  
New York, New York 10014  
212.807.7171

Coordinating Architects  
POLK STANLEY YEARY ARCHITECTS, Ltd  
700 South Schiller Street  
Little Rock, Arkansas 72201  
501.378.0878

WITSELL EVANS RASCO  
801 West Third Street  
Little Rock, Arkansas 72201  
501.374.5300

WOODS CARADINE ARCHITECTS  
2200 South Main Street  
Little Rock, Arkansas 72206  
501.374.4060

Landscape Architects  
HARGREAVES ASSOCIATES  
118 Moquette Street  
Cambridge, Massachusetts 02139  
617.661.0070

LANDSCAPE ARCHITECTURE, Inc.  
2300 Cottondale Lane Suite 202  
Little Rock, Arkansas 72202  
501.374.5810

Structural Engineer  
LESLIE E. ROBERTSON ASSOC. R.L.P.  
30 Broad Street, 4th Floor  
New York, New York 10004  
212.750.9000


MEP Engineers  
FLACK + KURTZ Inc.  
475 Fifth Avenue  
New York, New York 10017  
212.532.9600

CROMWELL ARCHITECTS ENGINEERS  
101 South Spring Street  
Little Rock, Arkansas 72201  
501.372.2900

Curtilwall Consultant  
R. A. HEINTGES ARCHITECTS  
126 Fifth Avenue 9th Floor  
New York, New York 10011  
212.652.2996



Issue	Date
100% Construction Documents	09/27/02
90% Progress Permitting	09/30/02
100% Design Development	03/11/02

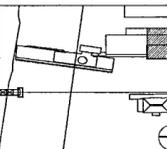

Job No: POLSHEK & PARTNERS ARCH. 9908  
CROMWELL AE 99-114

Scale: 1/8" = 1'-0"

Date: SEPTEMBER 27, 2002


Title: **SECOND LEVEL &  
ARCHIVE ROOF  
AREA D  
FIRE ALARM PLAN**

Sheet No:

**FA102d**



**FOR OFFICIAL USE ONLY**

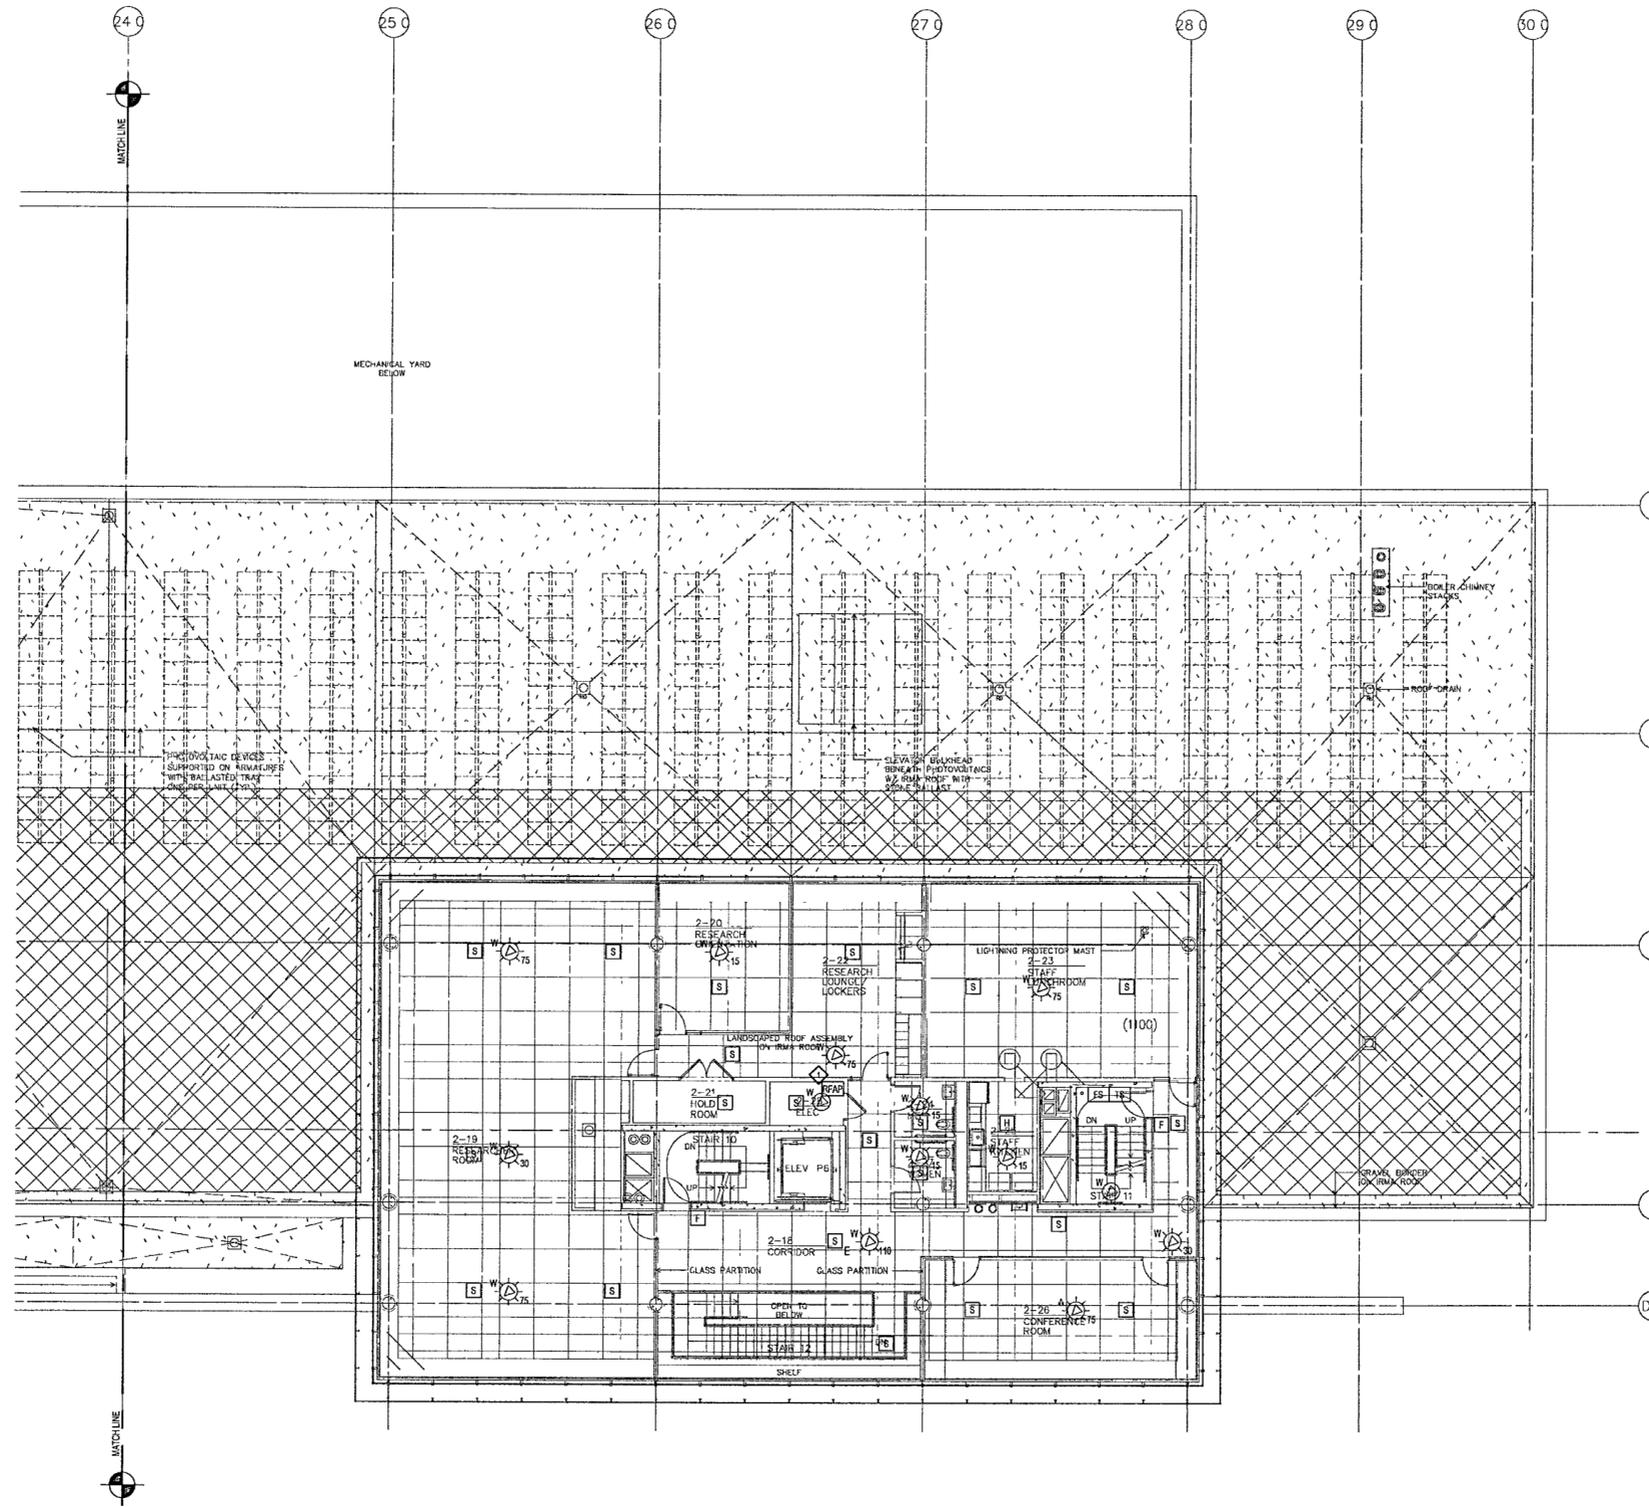

**KEYED NOTES**  
◊ REMOTE FIRE ALARM PANEL (BOOSTER)  
AS NEEDED BY CONTRACTOR.

**1 SECOND LEVEL & ARCHIVE ROOF AREA D FIRE ALARM PLAN**  
FA102d | FA102d 1/8" = 1'-0"



1246