

**WILLIAM J CLINTON
PRESIDENTIAL
CENTER**

LITTLE ROCK, ARKANSAS

Architect

POLSHEK PARTNERSHIP LLP
320 West 13th Street
New York, New York 10014
212.807.7171

Coordinating Architects

POLK STANLEY YEARY ARCHITECTS Ltd
700 South Schiller Street
Little Rock, Arkansas 72201
501.378.0878

WITSELL EVANS RASCO
801 West Third Street
Little Rock, Arkansas 72201
501.374.6300

WOODS CARADINE ARCHITECTS
2200 South Main Street
Little Rock, Arkansas 72206
501.374.4060

Landscape Architects

HARGREAVES ASSOCIATES
118 Magazine Street
Cambridge, Massachusetts 02139
617.661.0070

LANDSCAPE ARCHITECTURE, Inc.
2300 Coltondale Lane Suite 202
Little Rock, Arkansas 72202
501.374.5610

Structural Engineer

LESLIE E. ROBERTSON ASSOC. RLLP
30 Broad Street 47th Floor
New York, New York 10004
212.750.9000

MEP Engineers

FLACK + KURTZ Inc.
475 Fifth Avenue
New York, New York 10017
212.532.9600

CROMWELL ARCHITECTS ENGINEERS

101 South Spring Street
Little Rock, Arkansas 72201
501.372.2900


Curianwall Consultant

R. A. HEITGES ARCHITECTS
128 Fifth Avenue 9th Floor
New York, New York 10011
212.652.2966

Seal



Issue	Date
100% Construction Documents	09/27/02
90% Progress Printing	08/20/02
100% Design Development	03/01/02

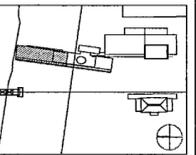

Job No: POLSHEK & PARTNERS ARCH 9908
CROMWELL AE 99-114

Scale: 1/8" = 1'-0"

Date: SEPTEMBER 27 2002


Title: **MUSEUM
LOWER LEVEL AREA A
FIRE ALARM PLAN**

Sheet No:

FA103a



FOR OFFICIAL USE ONLY

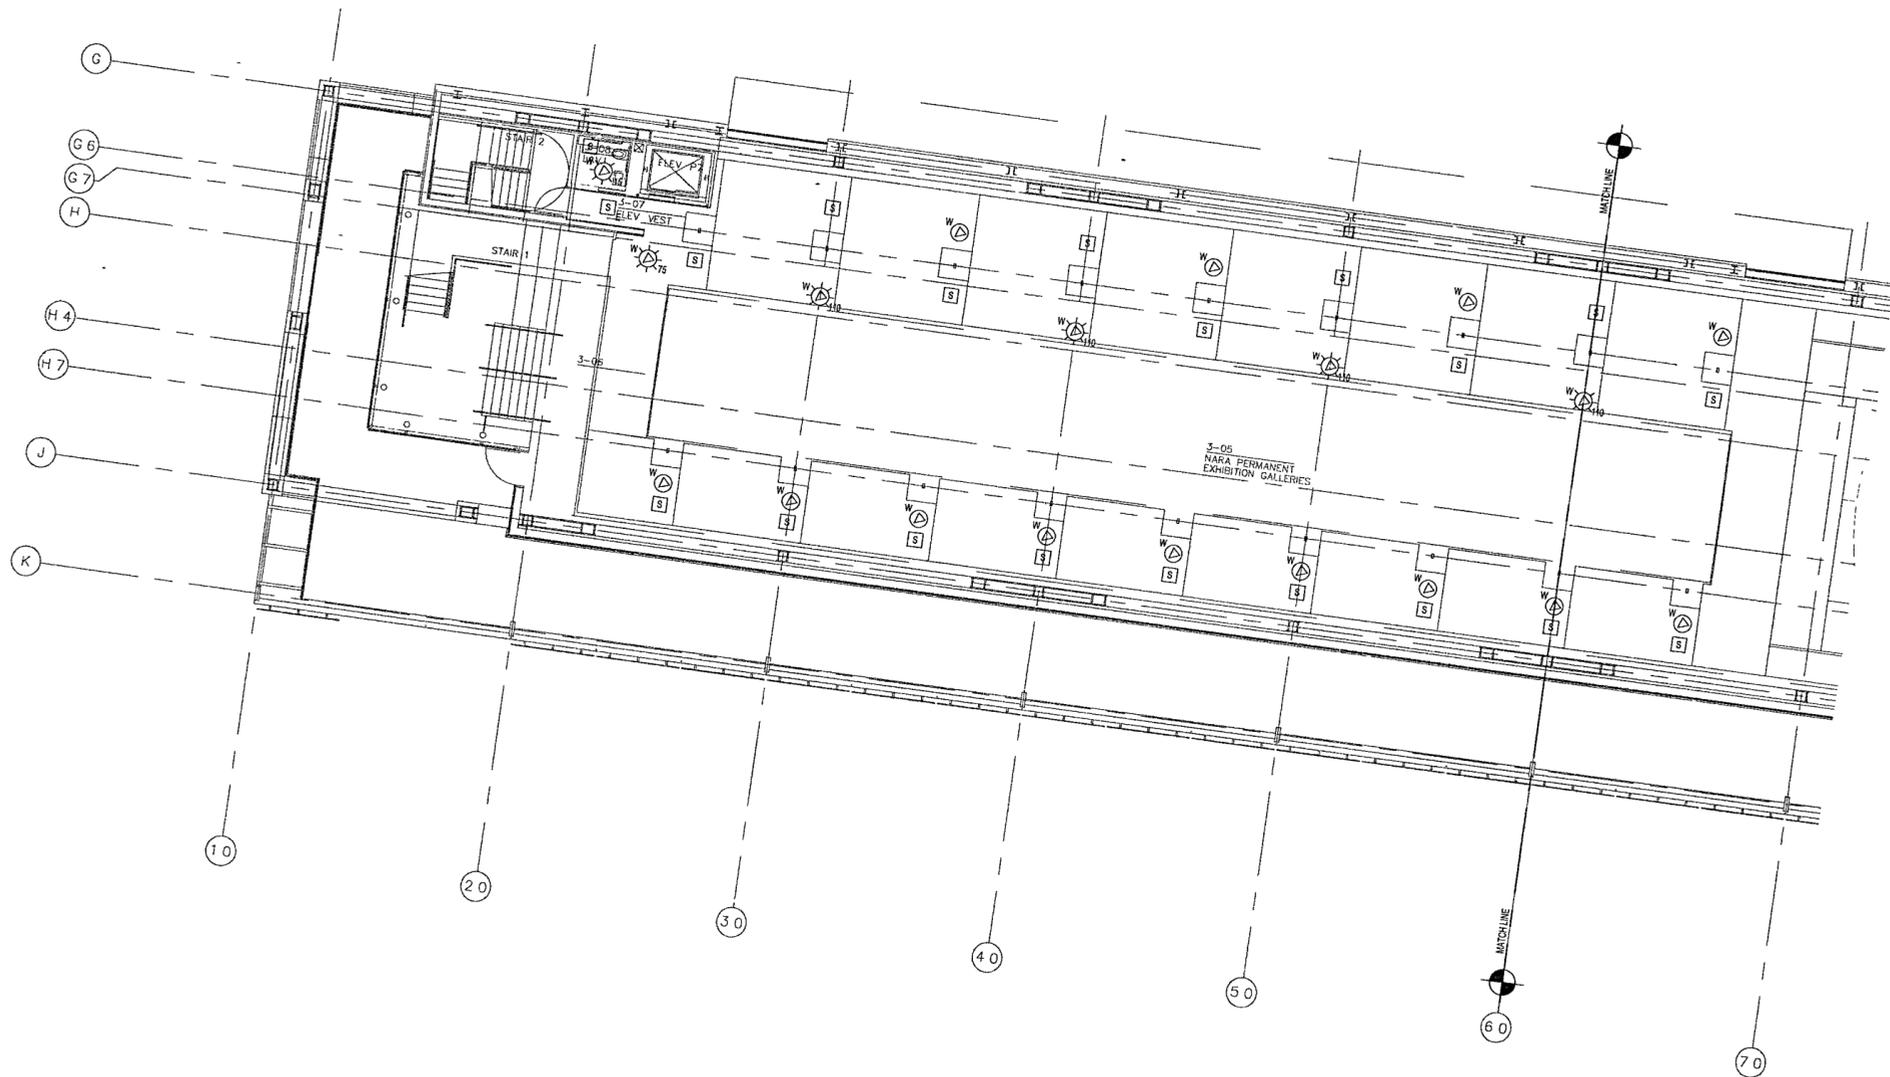

1 MUSEUM LOWER LEVEL AREA A FIRE ALARM PLAN
FA103a | FA103a 1/8" = 1'-0"
0 4' 8' 16' 24'
NORTH

125B