

**WILLIAM J. CLINTON
PRESIDENTIAL
CENTER**

LITTLE ROCK, ARKANSAS

Architect
POLSHEK PARTNERSHIP LLP
320 West 13th Street
New York, New York 10014
212.807.7171

Coordinating Architects
POLK STANLEY YEARY ARCHITECTS, Ltd
700 South Sculler Street
Little Rock, Arkansas 72201
501.378.0878

WITSELL EVANS RASCO
501 West Third Street
Little Rock, Arkansas 72201
501.374.5300

WOODS CARADINE ARCHITECTS
2200 South Main Street
Little Rock, Arkansas 72206
501.374.4060

Landscape Architects
HARGREAVES ASSOCIATES
118 Magazine Street
Cambridge, Massachusetts 02139
617.661.0070


LANDSCAPE ARCHITECTURE, Inc.
2300 Cotuit Lane Suite 202
Little Rock, Arkansas 72202
501.374.9910

Structural Engineer
LESLIE E. ROBERTSON ASSOC. RLLP
30 Broad Street 4th Floor
New York, New York 10004
212.750.9000


MEP Engineers
FLACK + KURTZ Inc.
475 Fifth Avenue
New York, New York 10017
212.532.9600

CROMMELL ARCHITECTS ENGINEERS
101 South Spring Street
Little Rock, Arkansas 72201
501.372.2900

Curatorial Consultant
R. A. HEINTGES ARCHITECTS
126 Fifth Avenue, 9th Floor
New York, New York 10011
212.652.2966

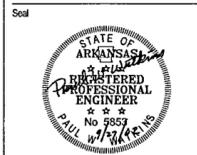

Issue	Date
100% Construction Documents	09/27/02
90% Progress Printing	09/30/02
100% Design Development	03/16/02

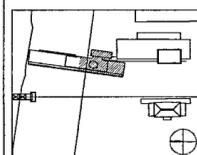

Job No. POLSHEK & PARTNERS ARCH. 9908
CROMMELL AE 99-114
Scale: 1/8" = 1'-0"
Date: SEPTEMBER 27, 2002


Title: **MUSEUM
LOWER LEVEL AREA B
FIRE ALARM PLAN**

Sheet No.

FA103b



FOR OFFICIAL USE ONLY

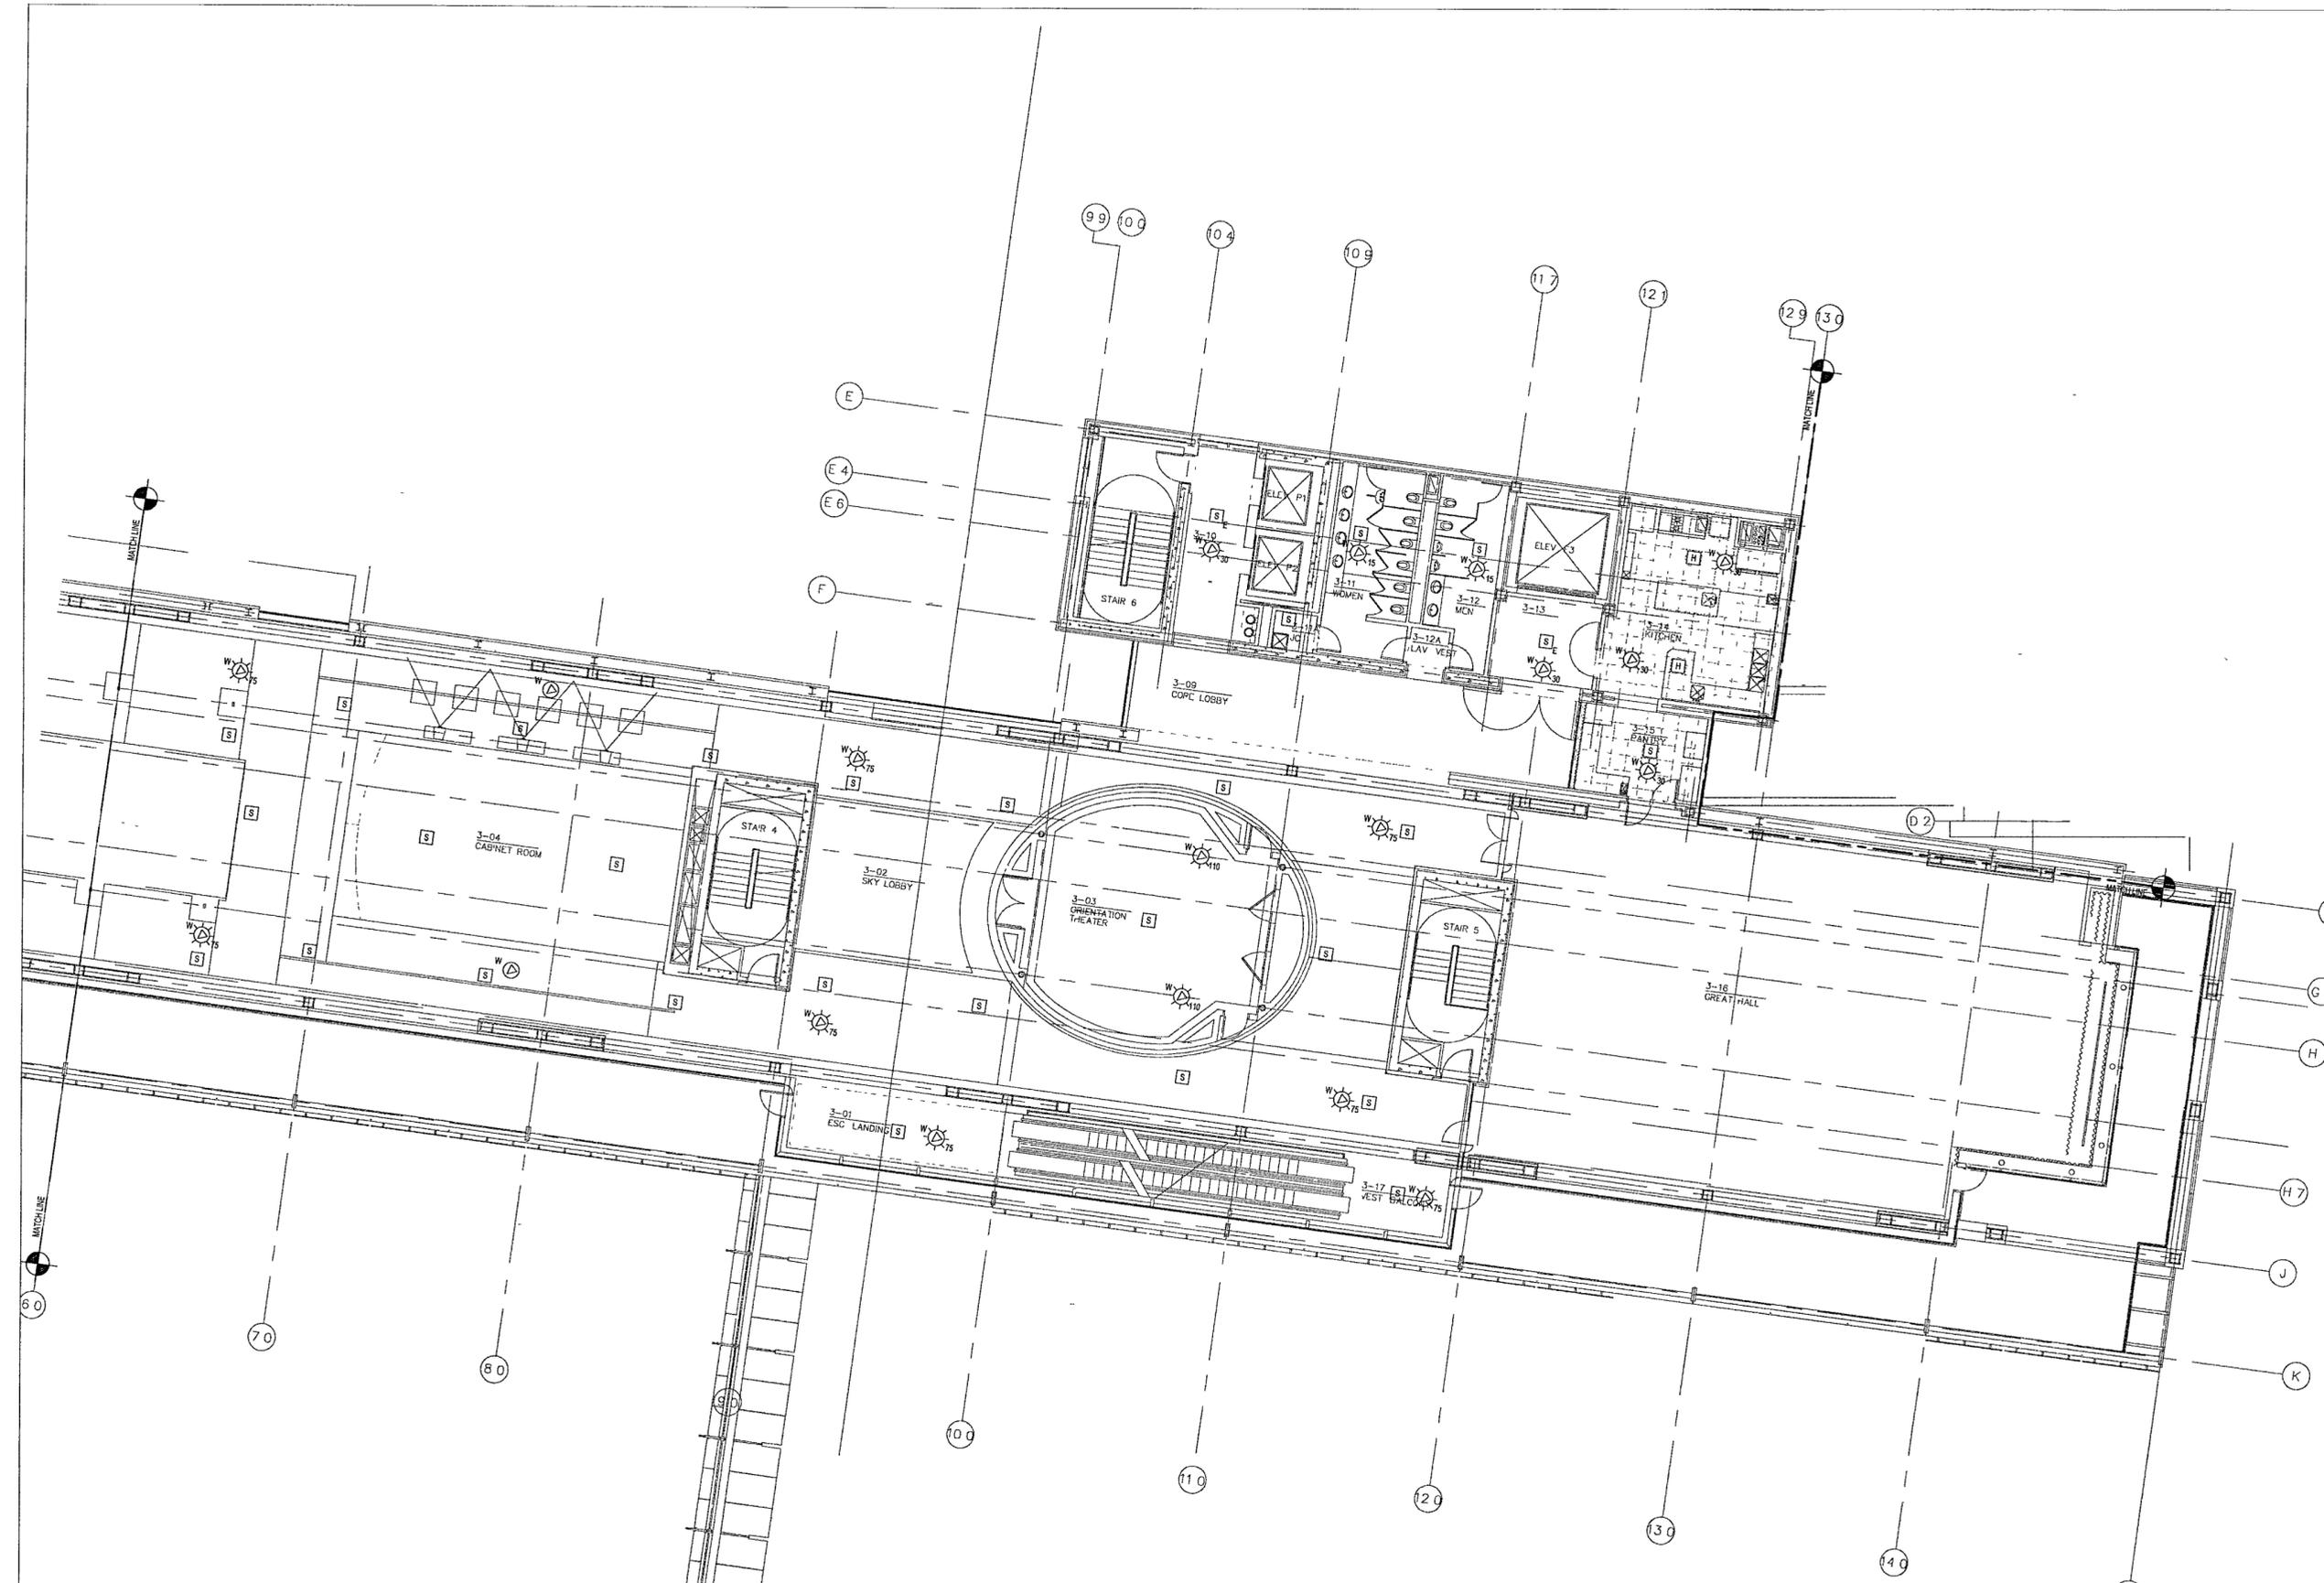

1 MUSEUM LOWER LEVEL AREA B FIRE ALARM PLAN
FA103b | FA103c | 1/8" = 1'-0" | NORTH



10/2/05