

**WILLIAM J CLINTON  
PRESIDENTIAL  
CENTER**

LITTLE ROCK, ARKANSAS

Architect

POLSHEK PARTNERSHIP LLP  
320 West 13th Street  
New York, New York 10014  
212.607.7171

Coordinating Architects

POLK STANLEY YEARY ARCHITECTS, Ltd  
700 South Schiller Street  
Little Rock, Arkansas 72201  
501.378.0878

WITSELL EVANS RASCO  
901 West Third Street  
Little Rock, Arkansas 72201  
501.374.5300

WOODS GARADINE ARCHITECTS  
2200 South Main Street  
Little Rock, Arkansas 72206  
501.374.4060

Landscape Architects

HARGREAVES ASSOCIATES  
118 Magazine Street  
Cambridge, Massachusetts 02139  
617.661.6070

LANDSCAPE ARCHITECTURE Inc.  
2300 Cottondale Lane Suite 202  
Little Rock, Arkansas 72202  
501.374.5810

Structural Engineer

LESLIE E. ROBERTSON ASSOC. RLLP  
30 Broad Street 47th Floor  
New York, New York 10004  
212.750.9000

MEP Engineers

FLACK + KURTZ Inc.  
475 Fifth Avenue  
New York, New York 10017  
212.532.9600

CROMWELL ARCHITECTS ENGINEERS

101 South Spring Street  
Little Rock, Arkansas 72201  
501.372.2900


Curator/Architect

R. A. HEINTGES ARCHITECTS  
125 Fifth Avenue 9th Floor  
New York, New York 10011  
212.632.2966

Seal



100% Construction Documents	09/27/02
90% Progress Printing	08/30/02
100% Design Development	03/01/02
Issue	Date

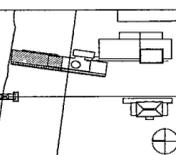

Job No. POLSHEK & PARTNERS ARCH 9906  
CROMWELL AE 99-114


Scale 1/8" = 1'-0"

Date SEPTEMBER 27, 2002


Title **MUSEUM  
UPPER LEVEL AREA A  
FIRE ALARM PLAN**

Sheet No.

 **FA104a**



**FOR OFFICIAL USE ONLY**

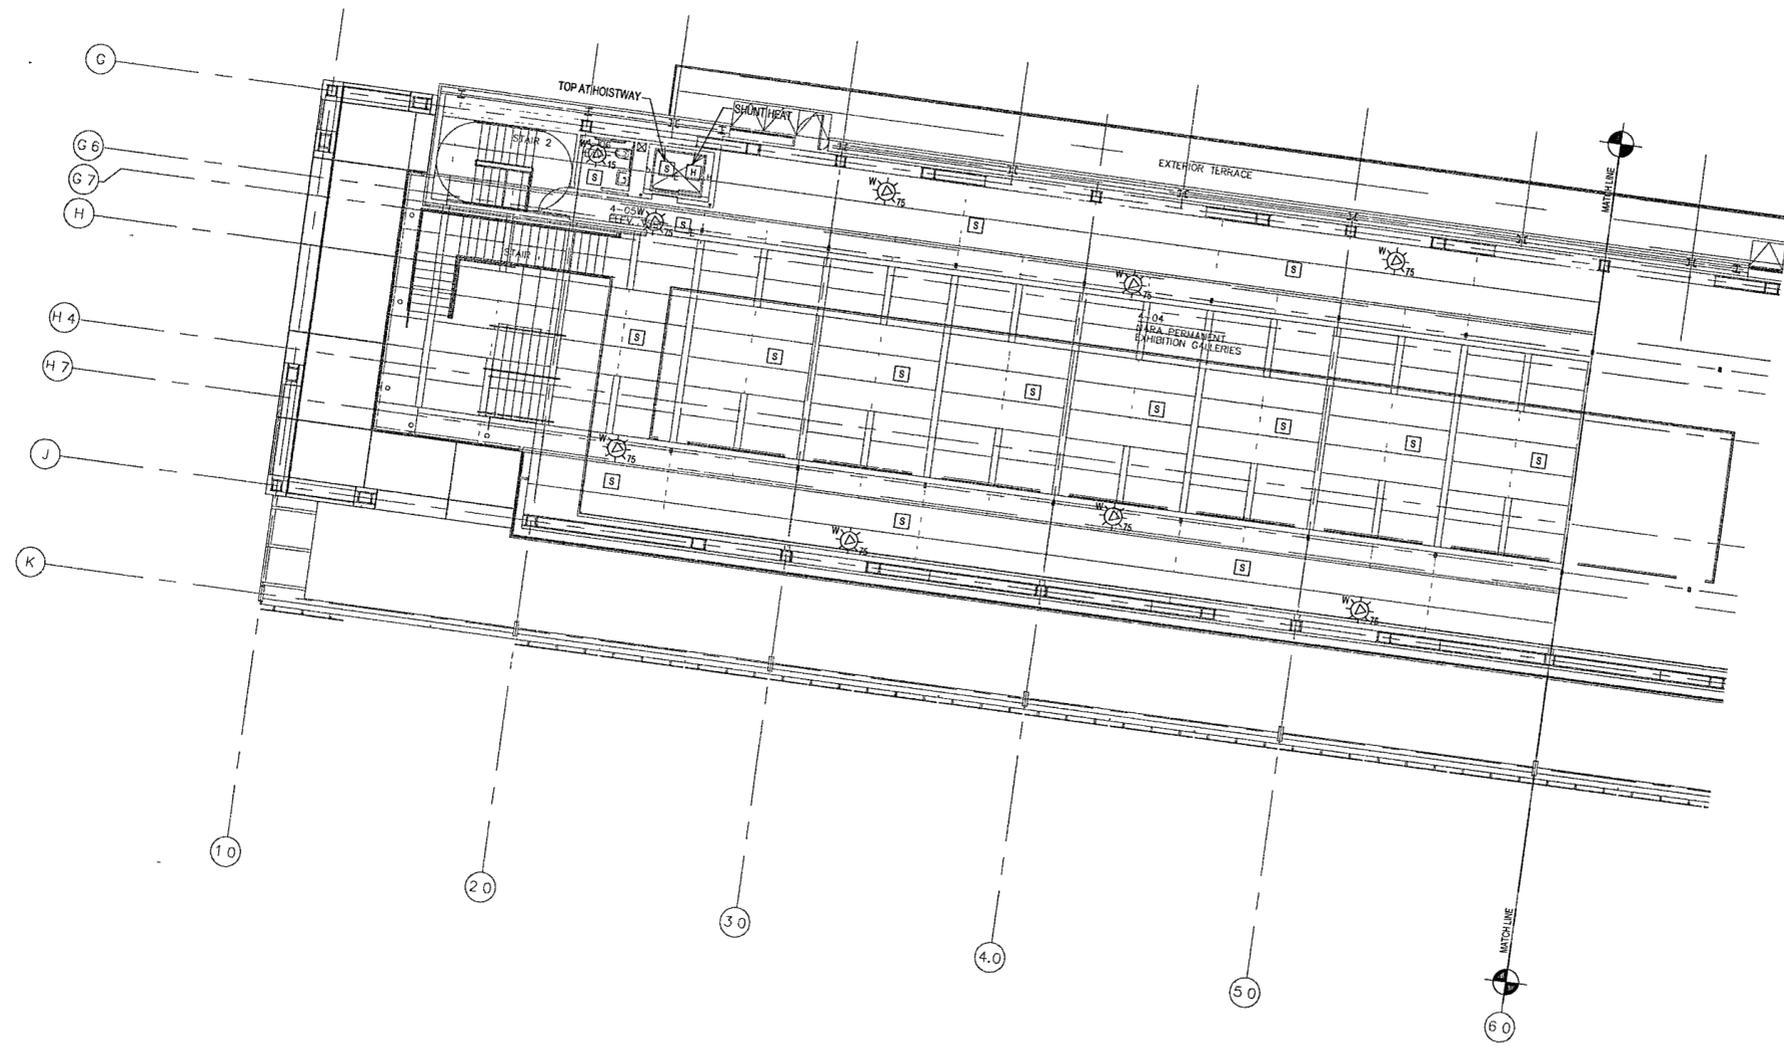

**1 MUSEUM UPPER LEVEL AREA A FIRE ALARM PLAN**  
FA104a | FA104a 1/8" = 1'-0"  
0 4' 8' 16' 24'