

**WILLIAM J CLINTON
PRESIDENTIAL
CENTER**

LITTLE ROCK, ARKANSAS

Architect
POLLSHEK PARTNERSHIP LLP
320 West 13th Street
New York, New York 10014
212.807.7171

Coordinating Architects
POLK STANLEY YEARY ARCHITECTS Ltd
700 South Saltillo Street
Little Rock, Arkansas 72201
501.378.0878

WITSELL EVANS RASCO
801 West Third Street
Little Rock, Arkansas 72201
501.374.5300

WOODS CARADINE ARCHITECTS
2200 South Main Street
Little Rock, Arkansas 72206
501.374.4060

Landscape Architects
HARGREAVES ASSOCIATES
118 Magazine Street
Cambridge, Massachusetts 02139
617.661.0070


LANDSCAPE ARCHITECTURE Inc.
2300 Cottondale Lane Suite 202
Little Rock, Arkansas 72202
501.374.5510

Structural Engineer
LESLIE E. ROBERTSON ASSOC. RLP
30 Broad Street, 4th Floor
New York, New York 10004
212.750.9000


MEP Engineers
FLACK + KURTZ Inc.
475 Fifth Avenue
New York, New York 10017
212.532.9600

CROMWELL ARCHITECTS ENGINEERS
101 South Spring Street
Little Rock, Arkansas 72201
501.372.2900

Cursewall Consultant
R. A. HEINTGES ARCHITECTS
126 Fifth Avenue, 9th Floor
New York, New York 10011
212.852.2996

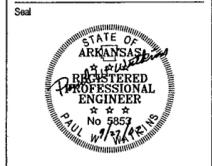

	Date
100% Construction Documents	09/27/02
90% Progress Printing	09/24/02
100% Design Development Issues	03/01/02

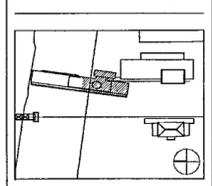

Job No: POLSHEK & PARTNERS ARCH 9908
CROMWELL AE 99-114

Scale: 1/8" = 1'-0"


Date: SEPTEMBER 27, 2002

Title: MUSEUM
UPPER LEVEL AREA B
FIRE ALARM PLAN

Sheet No. FA104b



FOR OFFICIAL USE ONLY

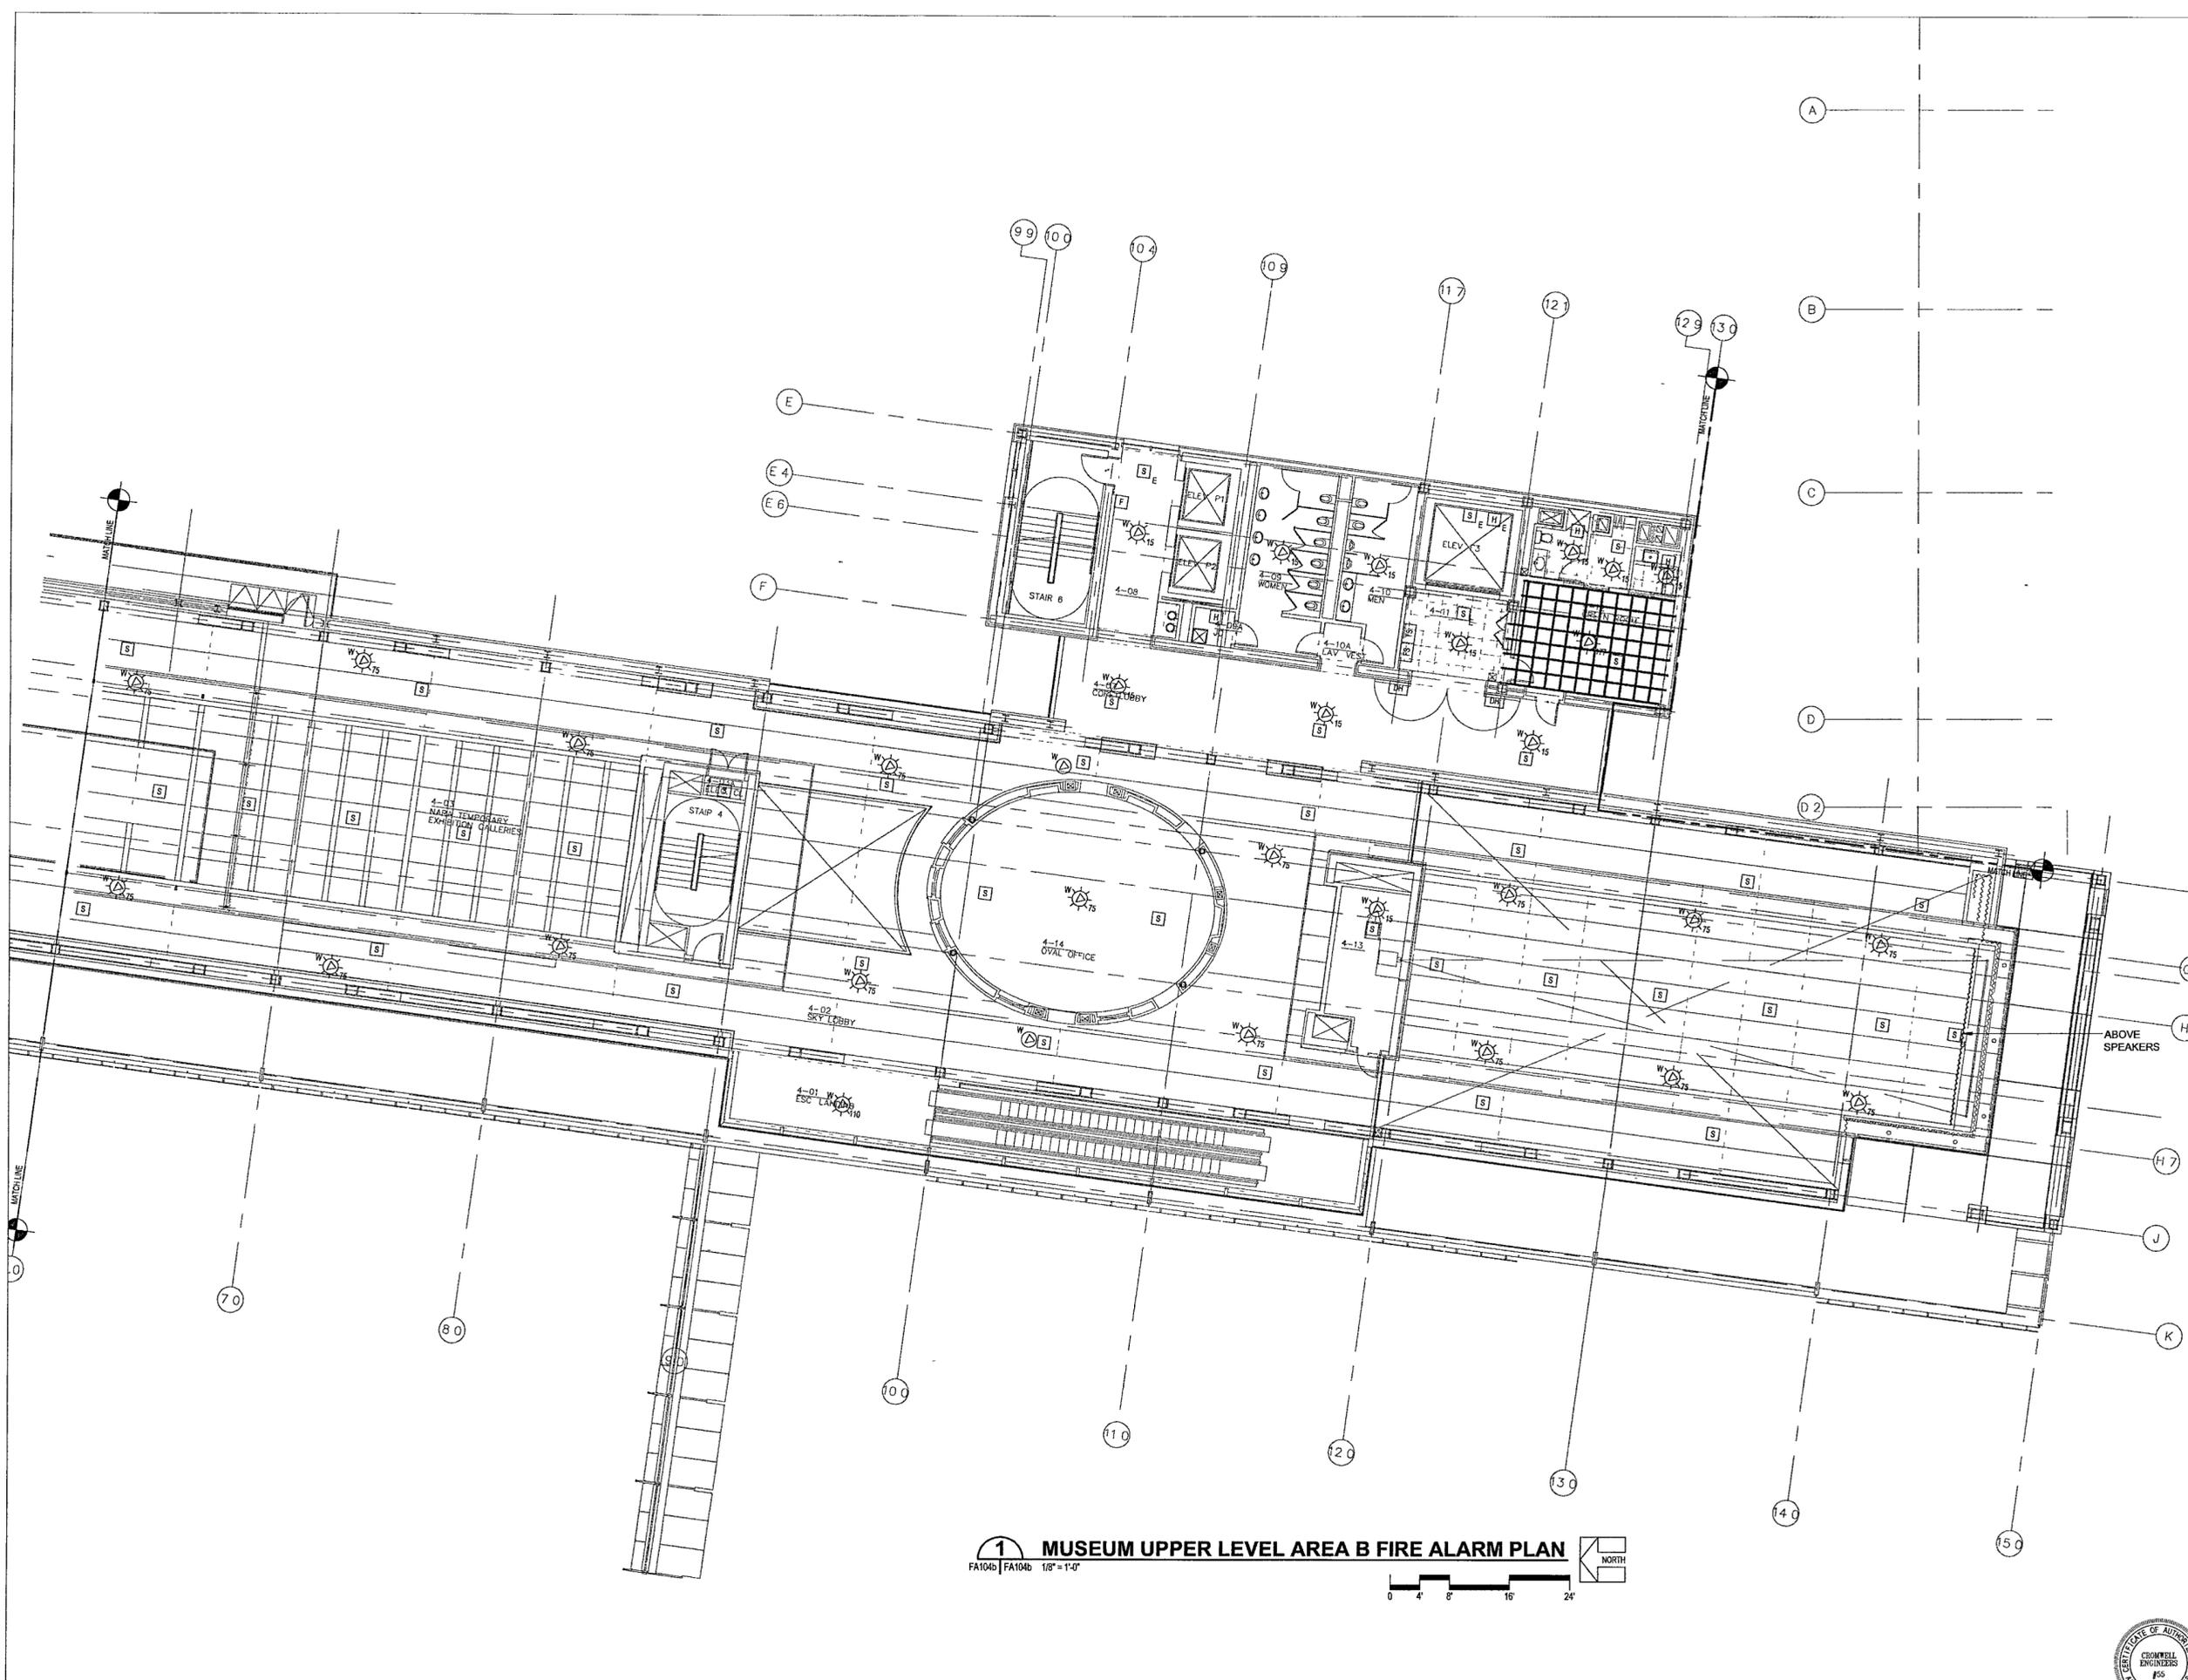

1 MUSEUM UPPER LEVEL AREA B FIRE ALARM PLAN
FA104b | FA104b 1/8" = 1'-0"