

**WILLIAM J CLINTON
PRESIDENTIAL
CENTER**

LITTLE ROCK, ARKANSAS

Architect

POLSHEK PARTNERSHIP LLP
320 West 13th Street
New York, New York 10014
212.637.7171

Coordinating Architects

POLK STANLEY YEARY ARCHITECTS, Ltd.
700 South Schiller Street
Little Rock, Arkansas 72201
501.378.0878

WITSELL EVANS RASCO
901 West Third Street
Little Rock, Arkansas 72201
501.374.5300

WOODS CARADINE ARCHITECTS
2200 South Main Street
Little Rock, Arkansas 72206
501.374.4060

Landscape Architects

HARGREAVES ASSOCIATES
118 Magazine Street
Cambridge, Massachusetts 02139
617.661.0070

LANDSCAPE ARCHITECTURE, Inc.
2300 Cotondale Lane Suite 202
Little Rock, Arkansas 72202
501.374.6810

Structural Engineer

LESLIE E. ROBERTSON ASSOC. RLLP
30 Broad Street 47th Floor
New York, New York 10004
212.750.9000

MEP Engineers

FLACK + KURTZ Inc.
475 Fifth Avenue
New York, New York 10017
212.532.9600

CROWMELL ARCHITECTS ENGINEERS

101 South Spring Street
Little Rock, Arkansas 72201
501.372.2900


Curator Consultant

R. A. HEINTGES ARCHITECTS
126 Fifth Avenue, 8th Floor
New York, New York 10011
212.652-2966

Seal



Issue	Date
100% Construction Documents	09/27/02
90% Progress Piling	08/30/02
100% Design Development	03/01/02

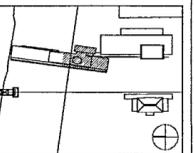

Job No: POLSHEK & PARTNERS AROH 9906

CROWMELL AE 99-114

Scale: 1/8" = 1'-0"

Date: SEPTEMBER 27 2002

Title: EXECUTIVE LEVEL & ROOF AREA B FIRE ALARM PLAN

Sheet No: FA105b

FOR OFFICIAL USE ONLY

FA105b


Sheet No

FA105b



2 MECHANICAL ROOM FIRE ALARM PLAN

FA105b | FA105b 1/8" = 1'-0"

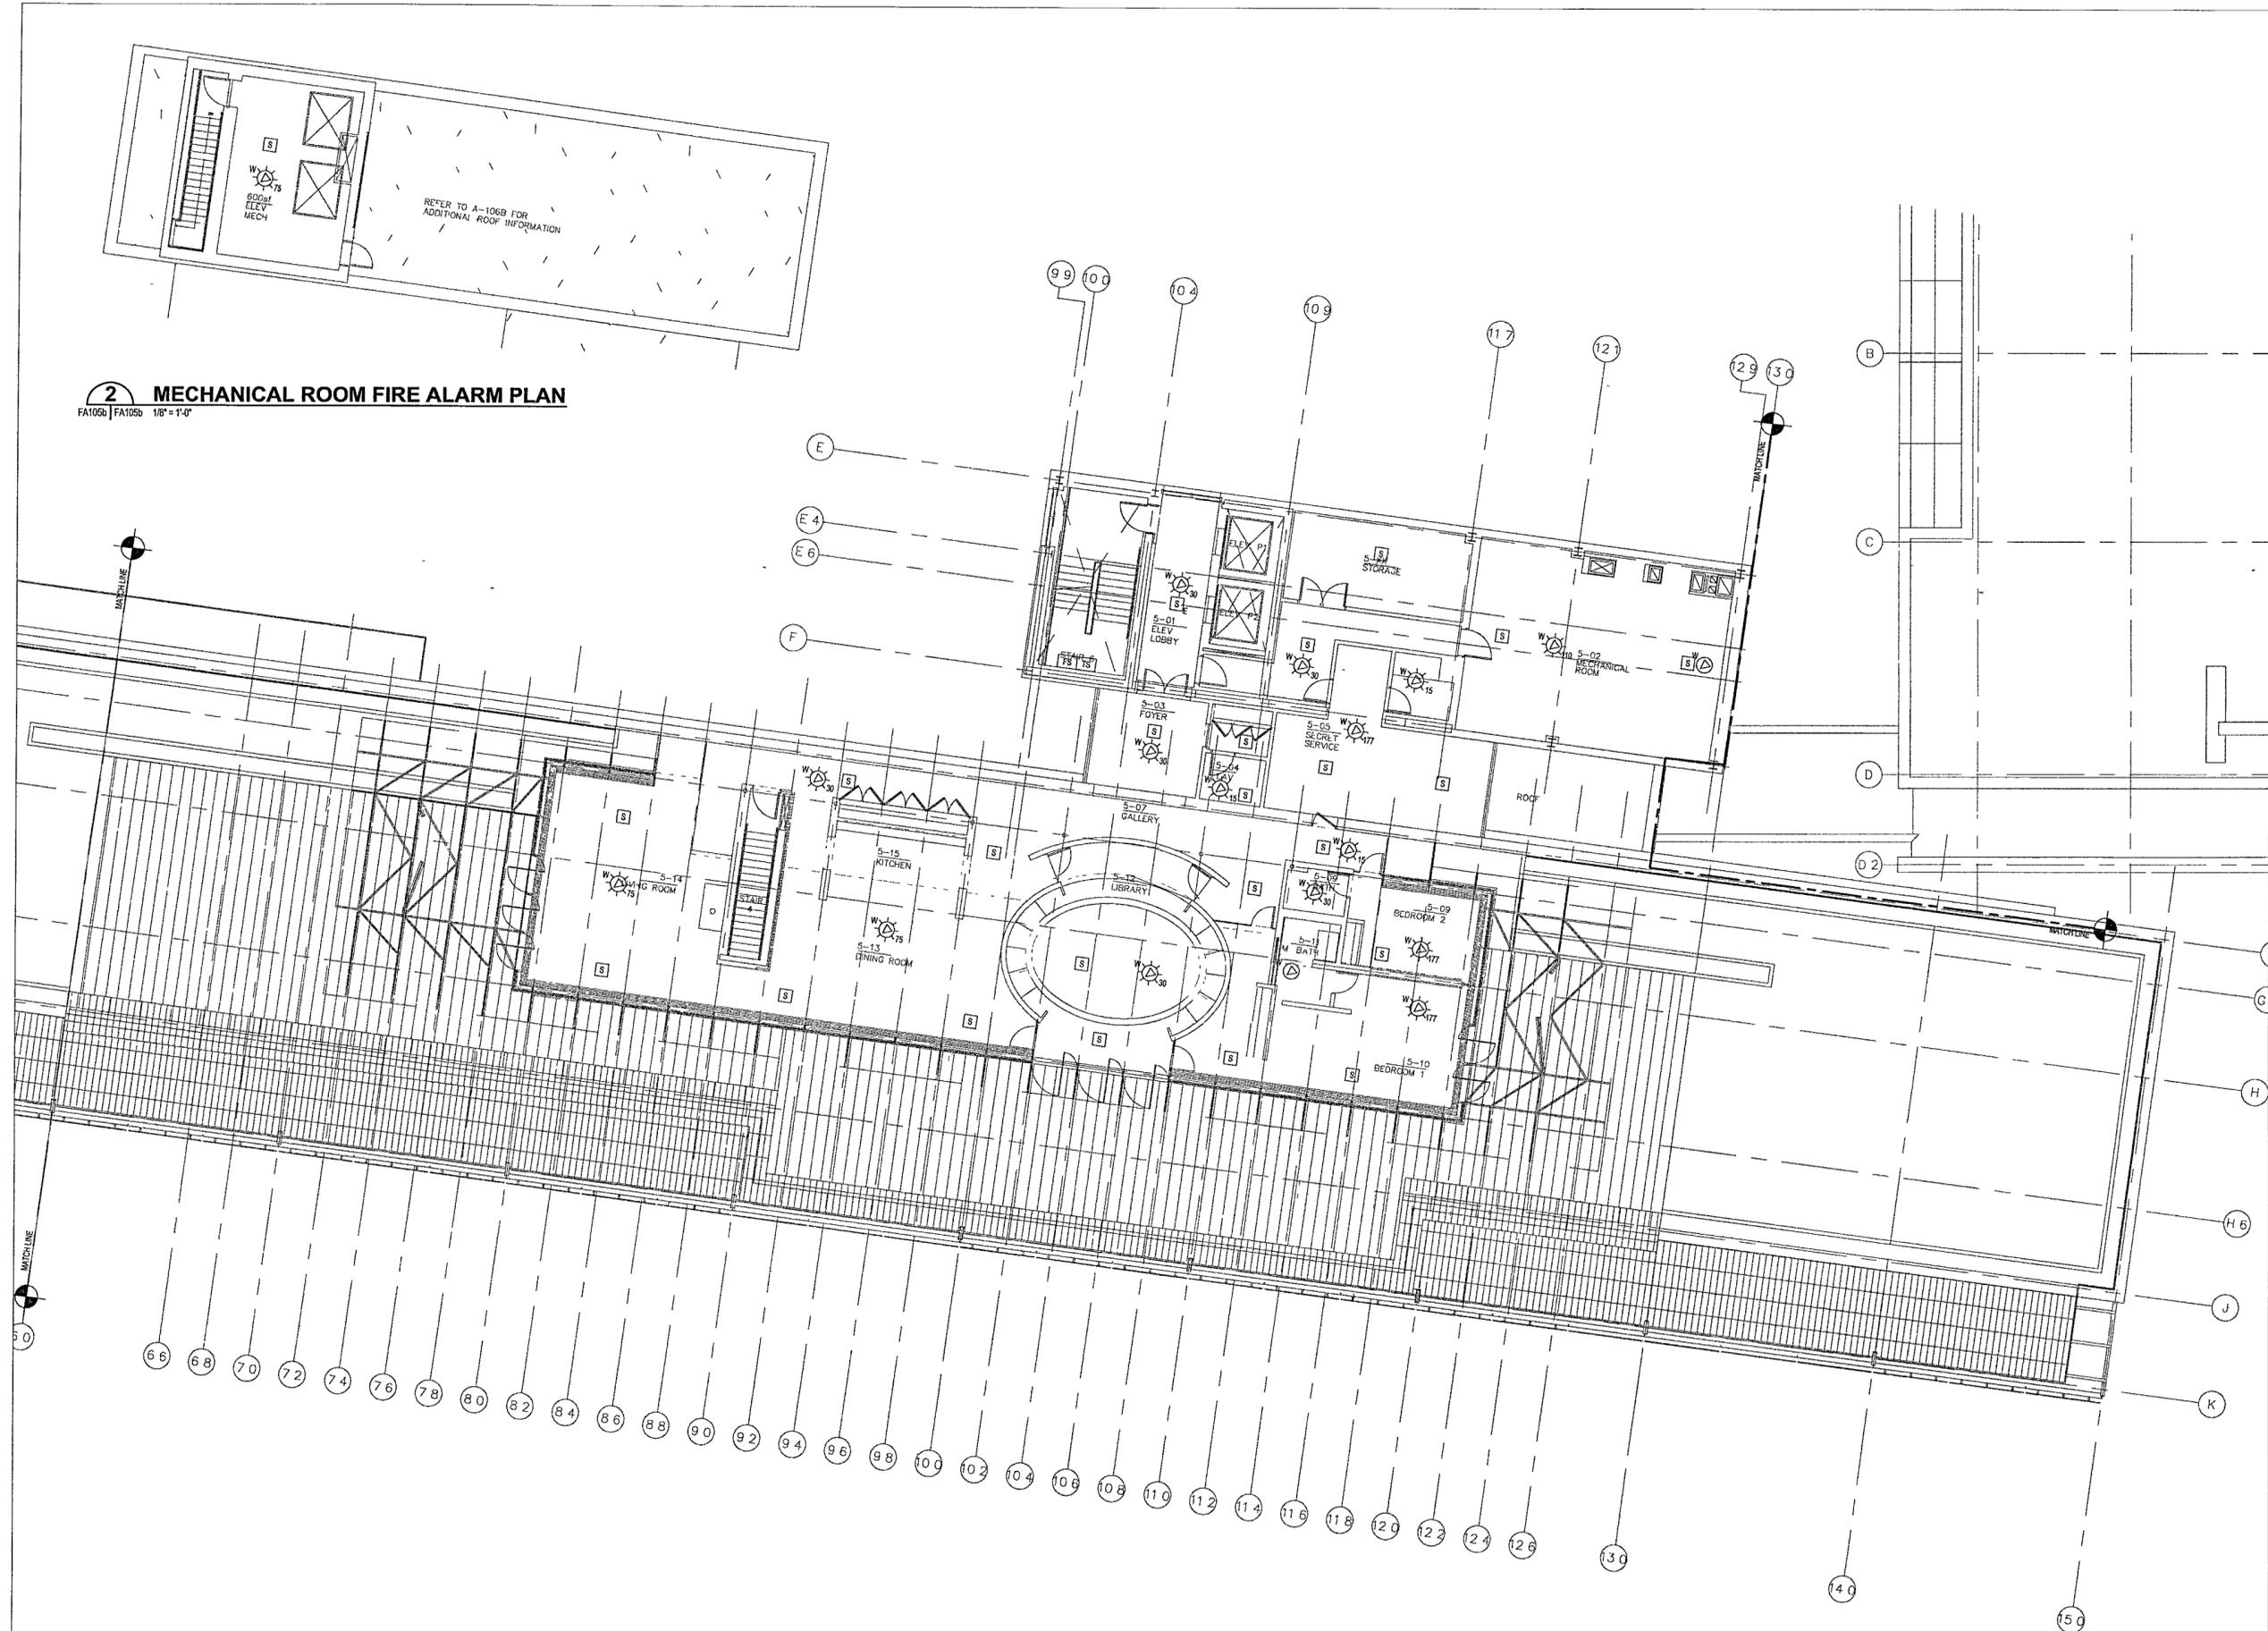

1 EXECUTIVE LEVEL & ROOF AREA B FIRE ALARM PLAN

FA105b | FA105b 1/8" = 1'-0"

