

**WILLIAM J CLINTON
PRESIDENTIAL
CENTER**

LITTLE ROCK, ARKANSAS

Architect
POLSHEK PARTNERSHIP LLP
320 West 13th Street
New York, New York 10014
212.807.7171

Coordinating Architects
POLK STANLEY YEARY ARCHITECTS Ltd
700 South Schaller Street
Little Rock, Arkansas 72201
501.378.0878

WITSELL EVANS RASCO
901 West Third Street
Little Rock, Arkansas 72201
501.374.5300

WOODS CARADINE ARCHITECTS
2200 South Main Street
Little Rock, Arkansas 72206
501.374.4060

Landscape Architects
HARGREAVES ASSOCIATES
118 Magazine Street
Cambridge, Massachusetts 02139
617.691.0070

LANDSCAPE ARCHITECTURE, Inc.
2300 Cotfordale Lane Suite 202
Little Rock, Arkansas 72202
501.374.5610

Structural Engineer
LESLIE E. ROBERTSON ASSOC. RLP
80 Broad Street, 47th Floor
New York, New York 10004
212.750.9000


MEP Engineers
FLACK + KURTZ Inc
475 Fifth Avenue
New York, New York 10017
212.532.9600

CROMMELL ARCHITECTS ENGINEERS
101 South Spring Street
Little Rock, Arkansas 72201
501.372.2900

Curtainwall Consultant
R. A. HEINTGES ARCHITECTS
126 Fifth Avenue 9th Floor
New York, New York 10011
212.652.2965



100% Construction Documents	09/27/02
90% Progress Printing	09/09/02
100% Design Development	03/01/02
Issue	Date

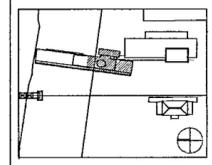

Job No POLSHEK & PARTNERS ARCH 0908
CROMMELL AE 99-114

Scale 1/8" = 1'-0"

Date SEPTEMBER 27, 2002


Title **MUSEUM
BASEMENT LEVEL
FIRE PROTECTION
PARTIAL PLAN**

Sheet No

F100b



FOR OFFICIAL USE ONLY

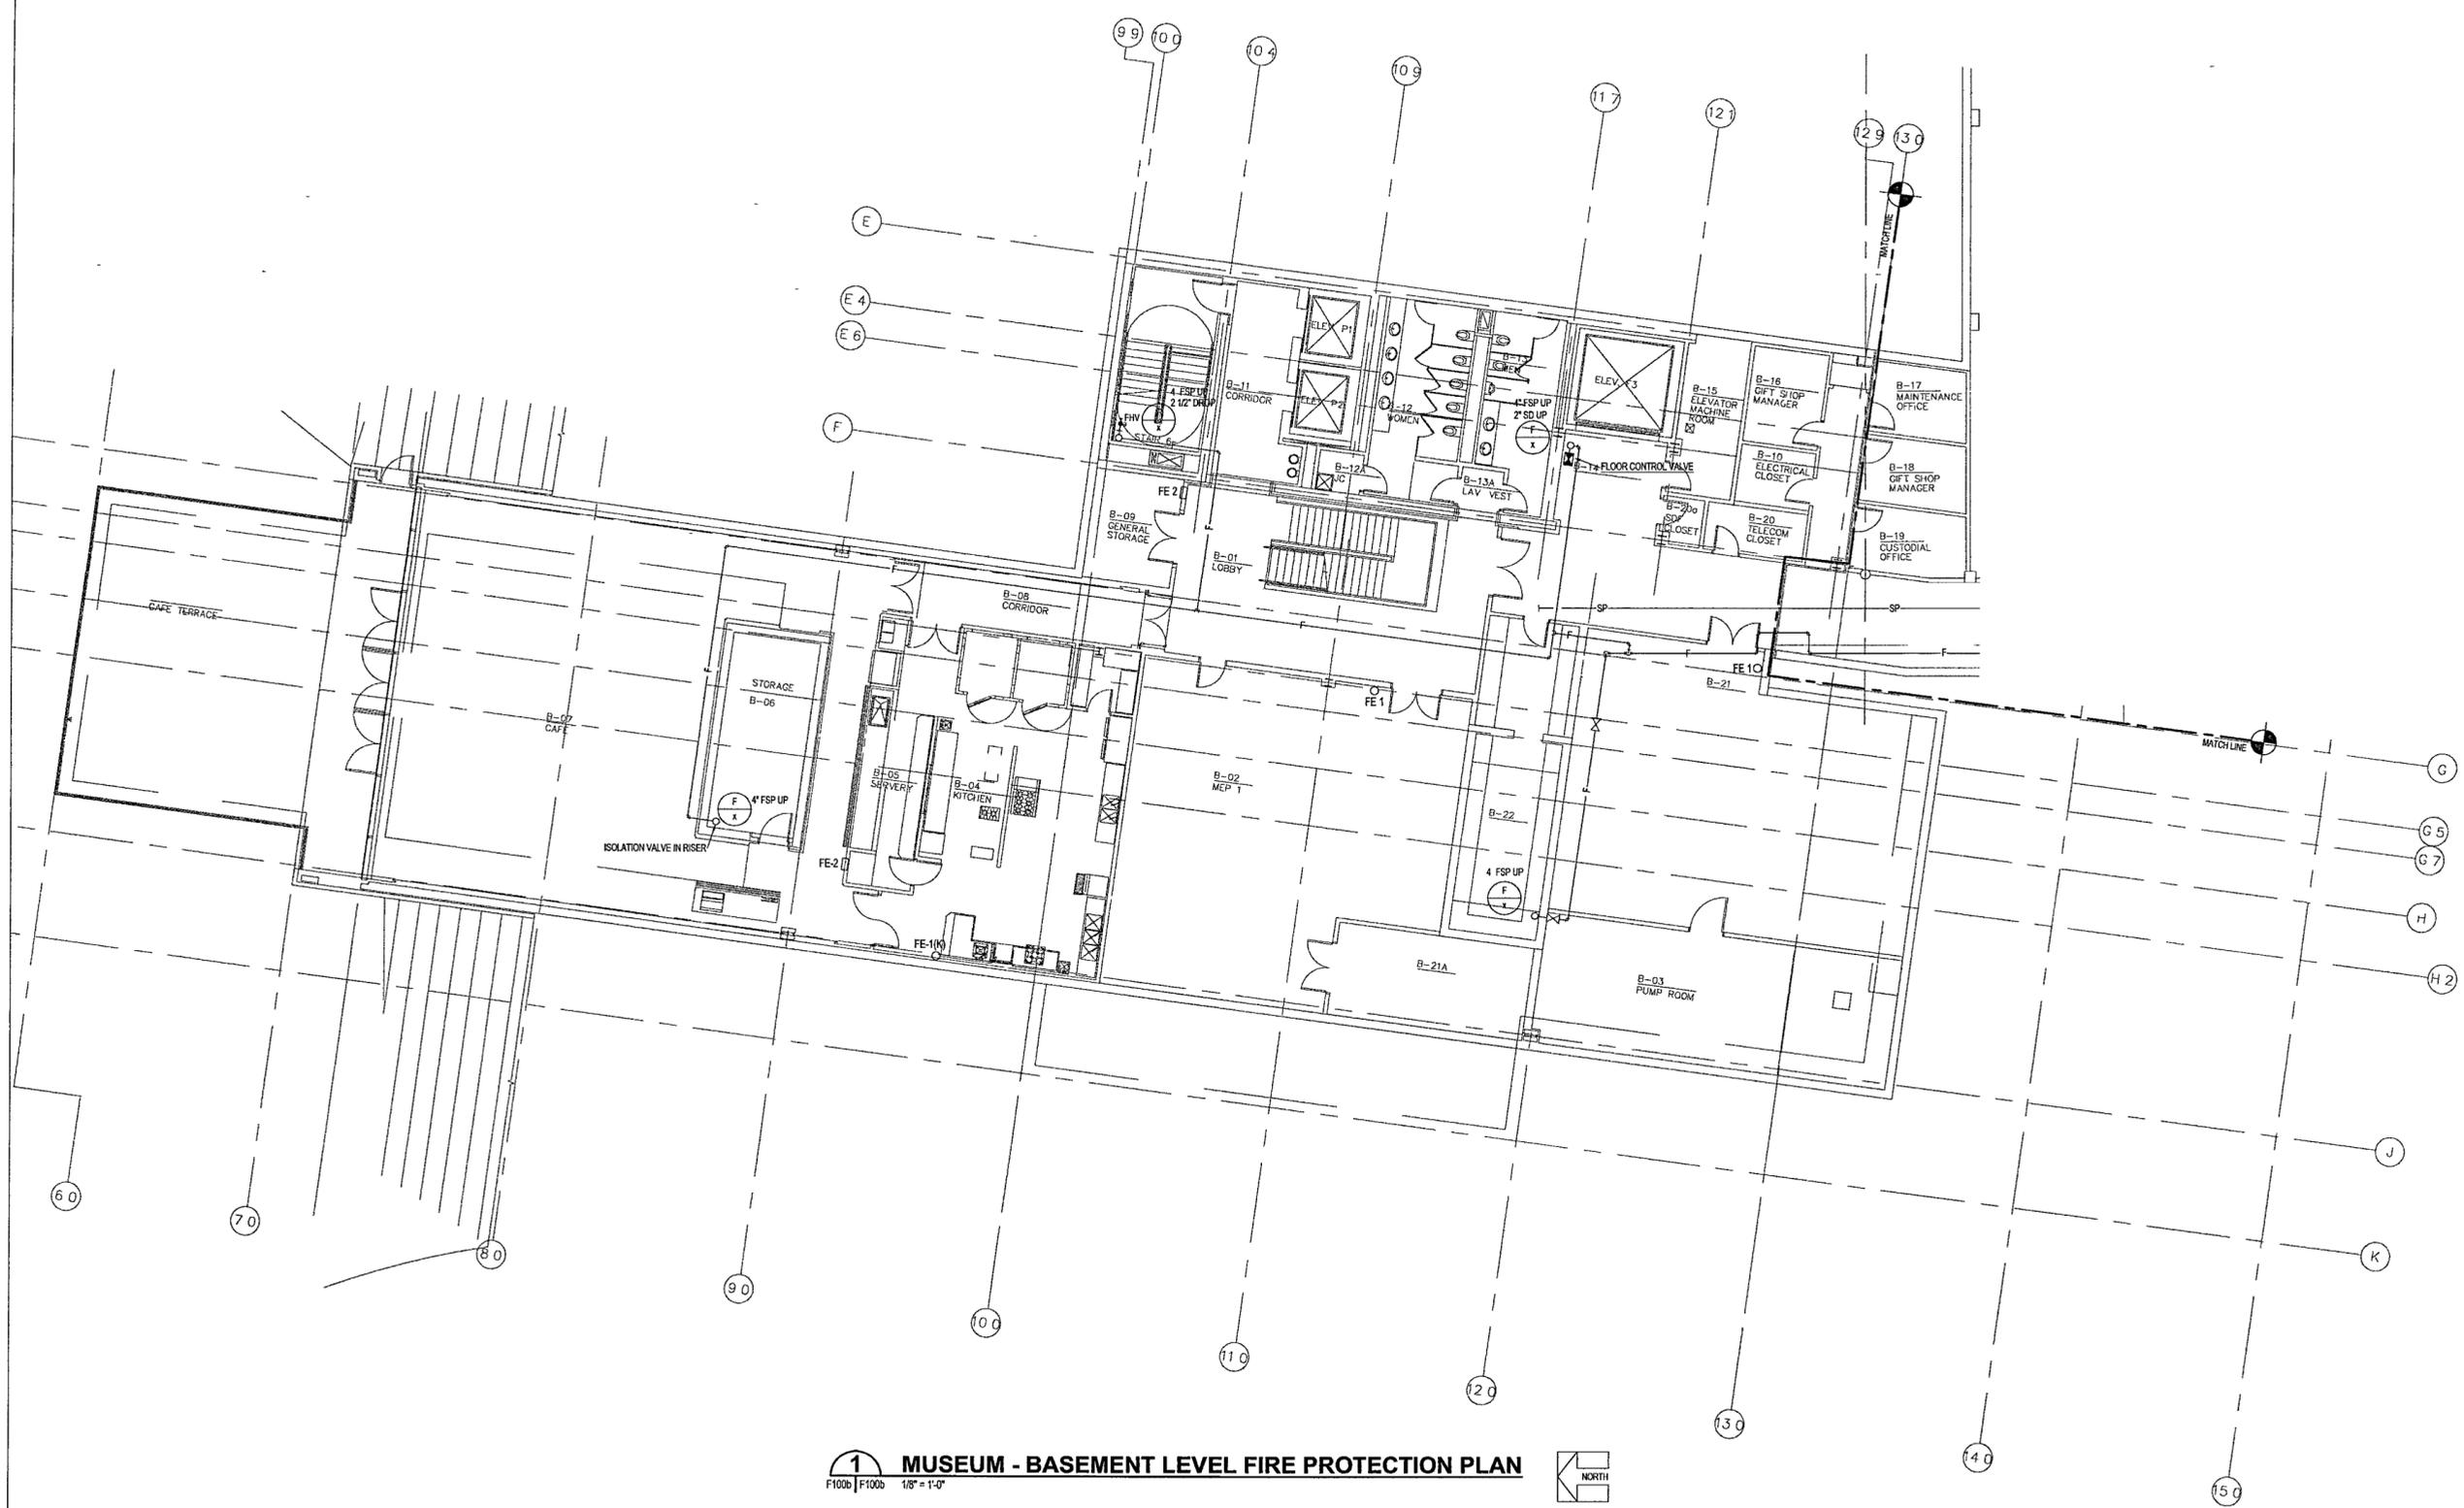

1 MUSEUM - BASEMENT LEVEL FIRE PROTECTION PLAN
F100b | F100b 1/8" = 1'-0" NORTH

1049b