

**WILLIAM J. CLINTON
PRESIDENTIAL
CENTER**

LITTLE ROCK, ARKANSAS

Architect
POLSHKE PARTNERSHIP LLP
320 West 13th Street
New York, New York 10014
212.697.7171

Coordinating Architects
POLK STANLEY YEARY ARCHITECTS, LM
700 South Schuler Street
Little Rock, Arkansas 72201
501.378.0878

WITSELL EVANS RASCO
901 West Third Street
Little Rock, Arkansas 72201
501.374.5300

WOODS CARADINE ARCHITECTS
2200 South Main Street
Little Rock, Arkansas 72206
501.374.4069

Landscape Architects
HARGREAVES ASSOCIATES
118 Magazine Street
Cambridge, Massachusetts 02139
617.661.0070

LANDSCAPE ARCHITECTURE Inc.
2300 Cottondale Lane Suite 202
Little Rock, Arkansas 72202
501.374.5610

Structural Engineer
LESLIE E. ROBERTSON ASSOC. RLP
30 Broad Street, 47th Floor
New York, New York 10004
212.759.9000


MEP Engineers
FLACK + KURTZ Inc.
475 Fifth Avenue
New York, New York 10017
212.532.9600

CROMWELL ARCHITECTS ENGINEERS
101 South Spring Street
Little Rock, Arkansas 72201
501.372.2900

Curtainwall Consultant
R. A. HEINTGES ARCHITECTS
126 Fifth Avenue, 9th Floor
New York, New York 10011
212.692.2966



| 100% Construction Documents | 09/27/02 |
|-----------------------------|----------|
| 90% Progress Printing | 09/30/02 |
| 100% Design Development | 03/14/02 |
| Issue | Date |

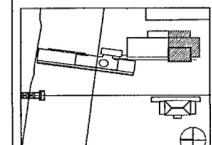

Job No. POLSHEK & PARTNERS ARCH 9908
CROMWELL AE 99-114

Scale 1/8" = 1'-0"

Date SEPTEMBER 27, 2002


Title ARCHIVES
BASEMENT LEVEL
FIRE PROTECTION
PARTIAL PLAN

Sheet No.

F100d



FOR OFFICIAL USE ONLY

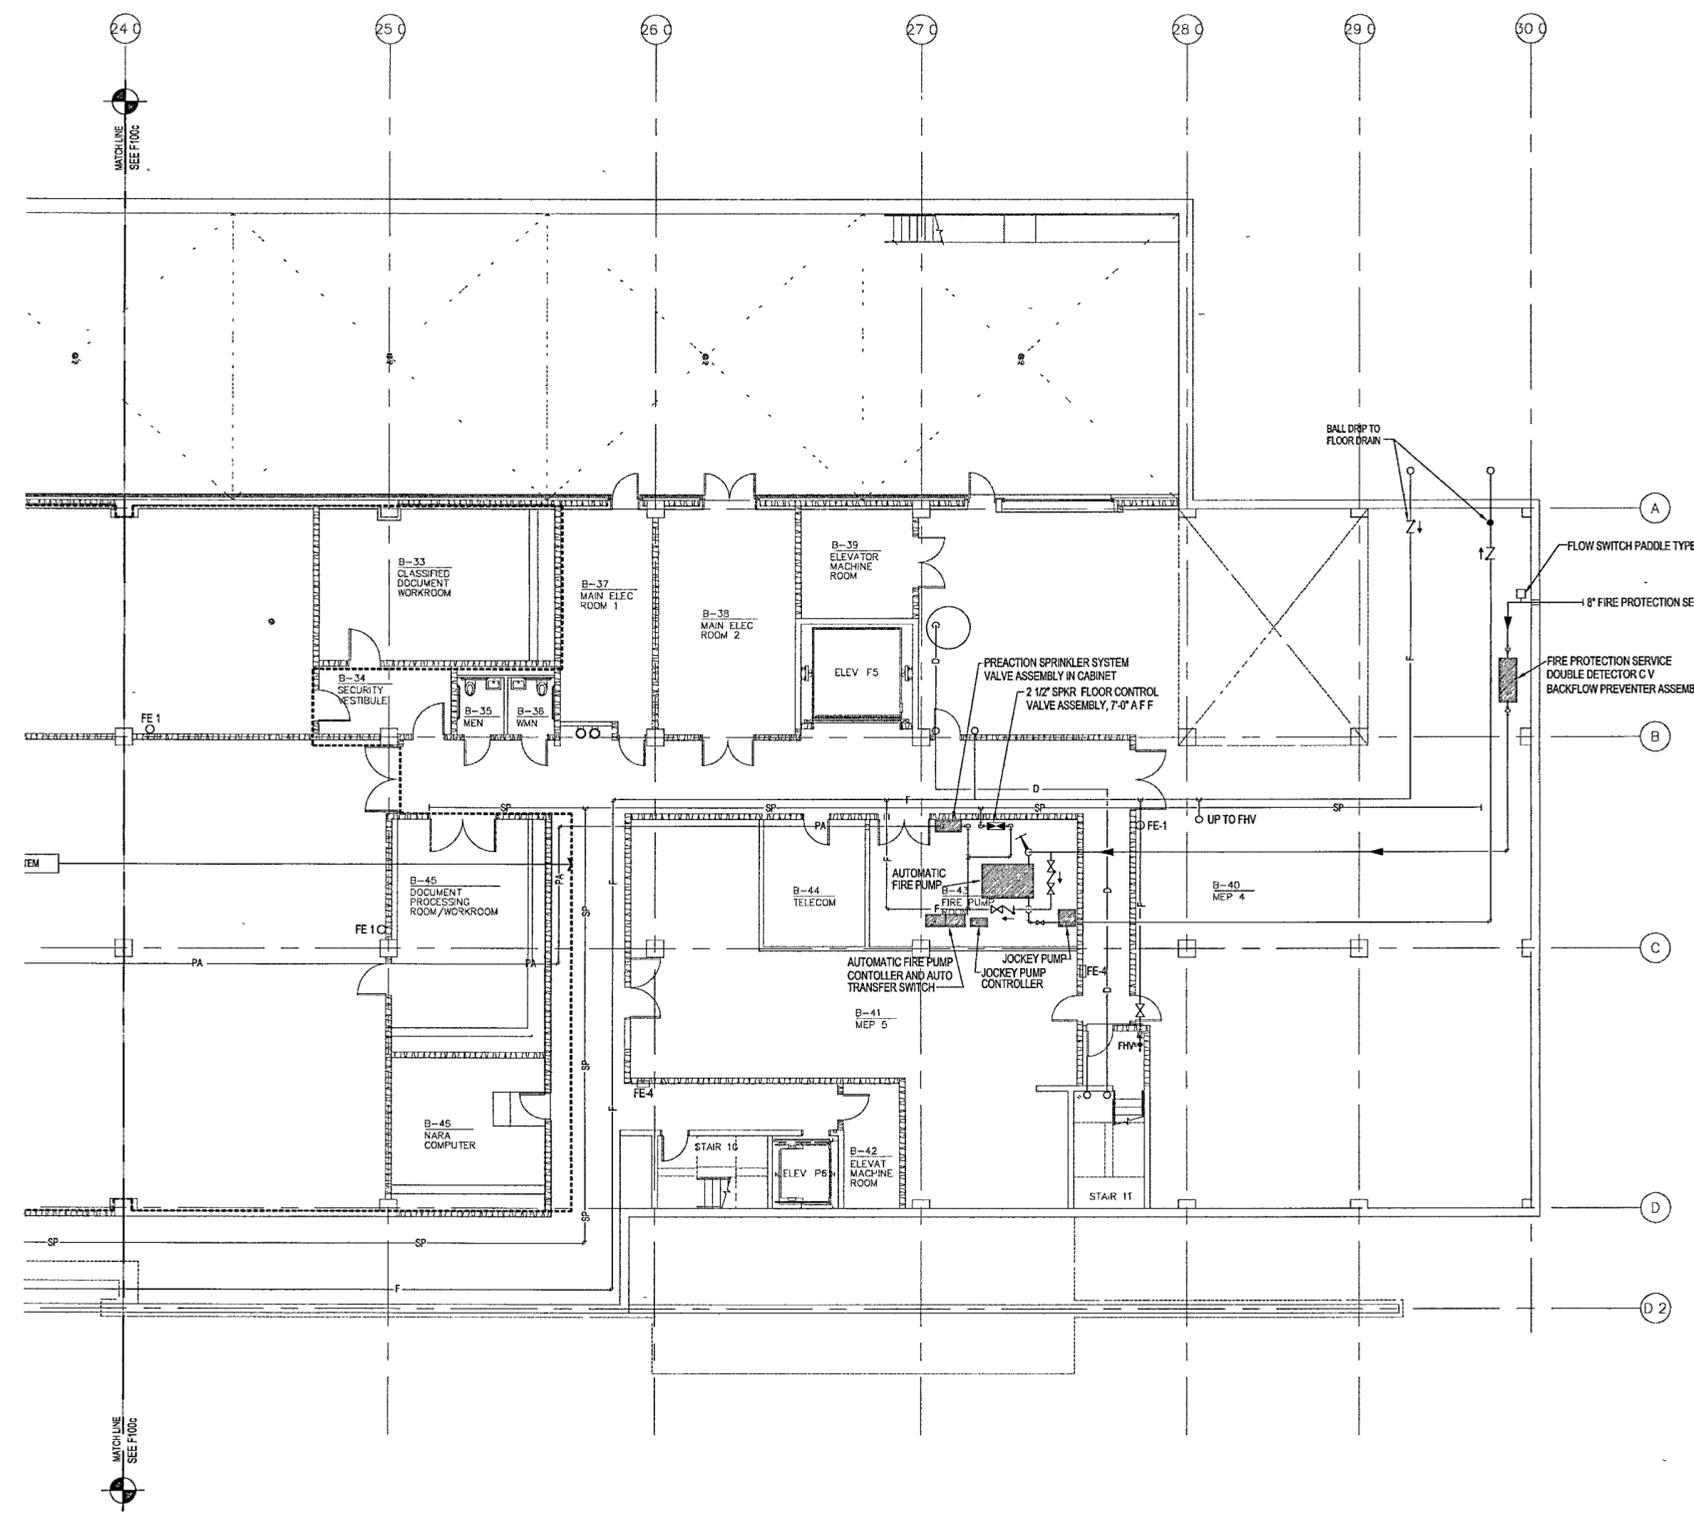

1 ARCHIVES - BASEMENT LEVEL FIRE PROTECTION PLAN
F100d | F100d 1/8" = 1'-0"



10/1