

**WILLIAM J. CLINTON  
PRESIDENTIAL  
CENTER**

LITTLE ROCK ARKANSAS

Architect  
POLSHKE PARTNERSHIP LLP  
320 West 13th Street  
New York, New York 10014  
212.807.7171

Coordinating Architects  
POLK STANLEY YEARY ARCHITECTS, Ltd  
700 South Scholar Street  
Little Rock, Arkansas 72201  
501.378.0878

WITSELL EVANS RASCO  
901 West Third Street  
Little Rock, Arkansas 72201  
501.374.5300

WOODS CARADINE ARCHITECTS  
2200 South Main Street  
Little Rock, Arkansas 72206  
501.374.4060

Landscape Architects  
HARGREAVES ASSOCIATES  
118 Magazine Street  
Cambridge Massachusetts 02139  
617.661.0070

LANDSCAPE ARCHITECTURE, Inc  
2300 Cottondale Lane Suite 202  
Little Rock, Arkansas 72202  
501.374.5610

Structural Engineer  
LESLIE E. ROBERTSON ASSOC. RLP  
30 Broad Street 47th Floor  
New York, New York 10004  
212.750.9000


MEP Engineers  
FLACK + KURTZ Inc.  
475 5th Avenue  
New York, New York 10017  
212.532.9600

CROMWELL ARCHITECTS ENGINEERS  
101 South Spring Street  
Little Rock, Arkansas 72201  
501.372.2900

Curtilwall Consultant  
R. A. HEINTGES ARCHITECTS  
126 5th Avenue 9th Floor  
New York, New York 10011  
212.692.2965



Issue	Date
100% Construction Documents	09/27/02
50% Progress Printing	08/30/02
100% Design Development	03/01/02

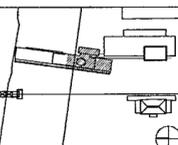

Job No POLSHEK & PARTNERS ARCH 9908


Scale 1/8" = 1'-0"

Date SEPTEMBER 27 2002

Title MUSEUM GROUND LEVEL FIRE PROTECTION PARTIAL PLAN

Sheet No. F101b

FOR OFFICIAL USE ONLY

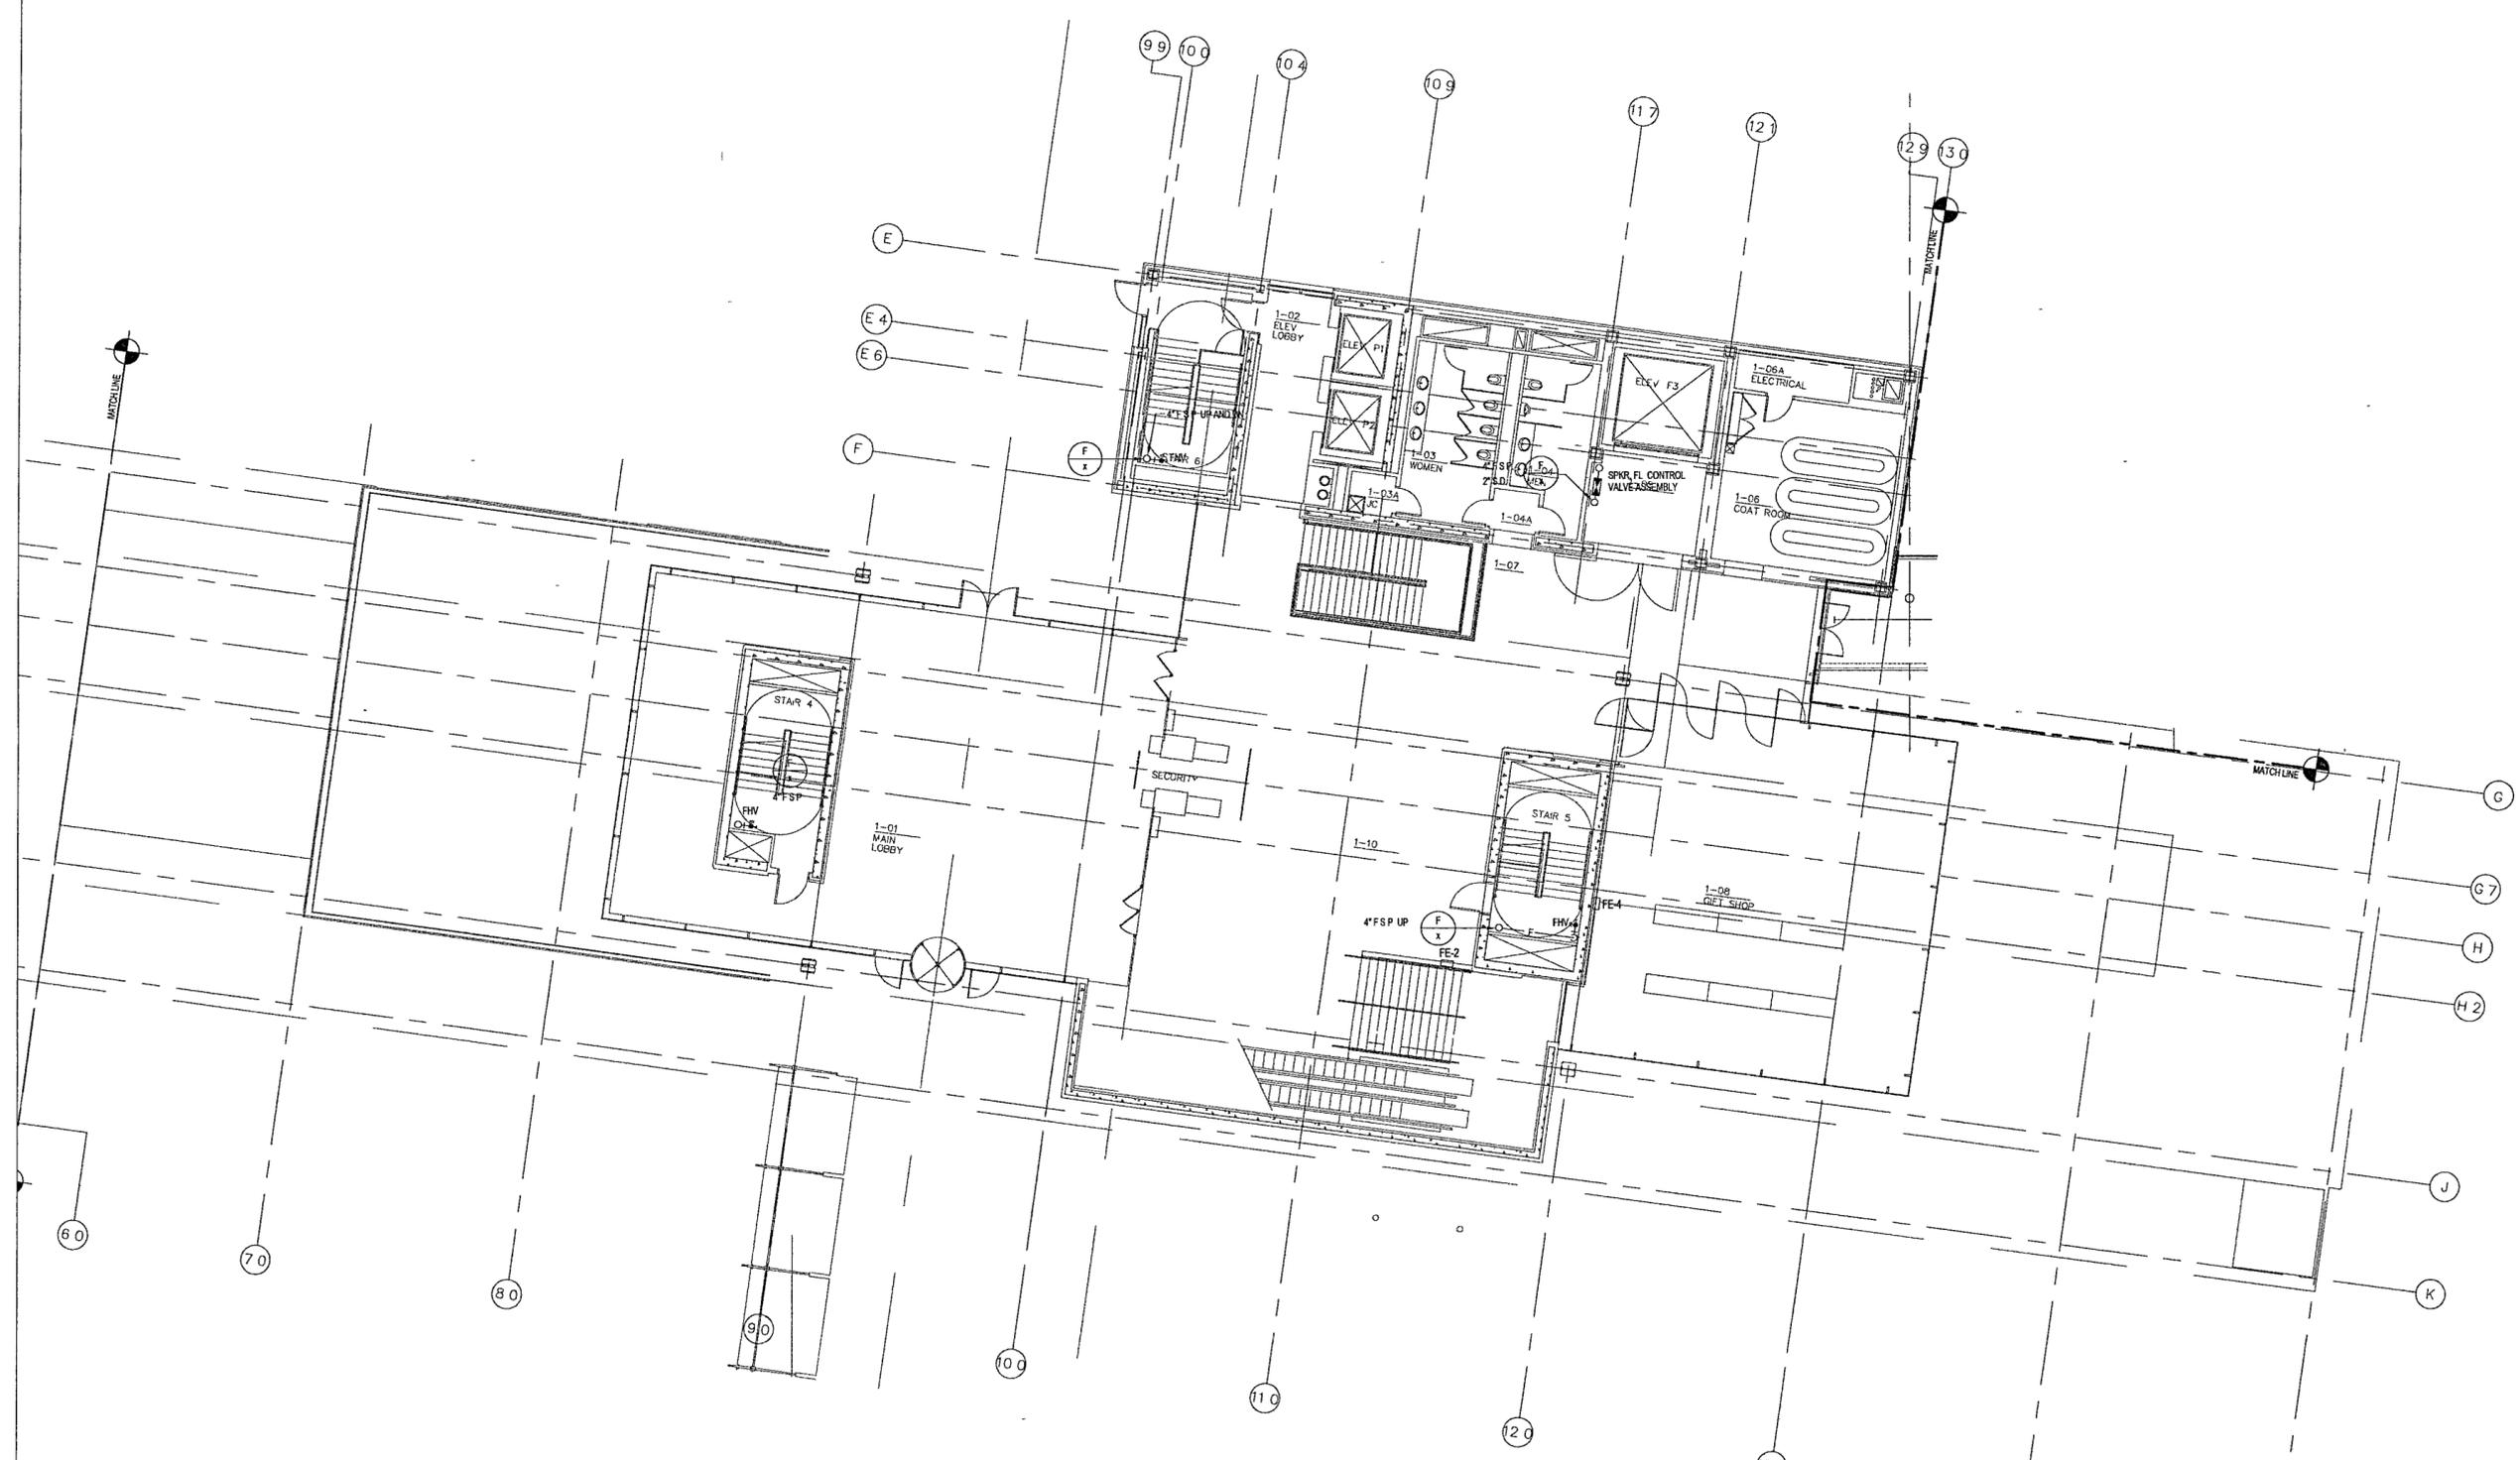

**1 MUSEUM - FIRST LEVEL FIRE PROTECTION PLAN**  
F101b | F101b 1/8" = 1'-0"



9/27