

**WILLIAM J CLINTON
PRESIDENTIAL
CENTER**

LITTLE ROCK, ARKANSAS

Architect
POLSHEK PARTNERSHIP LLP
320 West 13th Street
New York, New York 10014
212.807 7171

Coordinating Architects
POLK STANLEY YEARY ARCHITECTS, LM
700 South Schiller Street
Little Rock, Arkansas 72201
501.378.0673

WITSELL EVANS RASCO
901 West Third Street
Little Rock, Arkansas 72201
501.374.5300

WOODS CARADINE ARCHITECTS
2220 South Main Street
Little Rock, Arkansas 72206
501.374.4060

Landscape Architects
HARGREAVES ASSOCIATES
118 Magazine Street
Cambridge Massachusetts 02139
617.661.0070


LANDSCAPE ARCHITECTURE, Inc.
2300 Colborne Lane Suite 202
Little Rock, Arkansas 72202
501.374.5610

Structural Engineer
LESLIE E. ROBERTSON ASSOC. RLP
30 Broad Street 47th Floor
New York, New York 10004
212.750.9000

MEP Engineers
FLACK + KURTZ Inc.
475 Fifth Avenue
New York, New York 10017
212.532.9600

CROMWELL ARCHITECTS ENGINEERS
101 South Spring Street
Little Rock, Arkansas 72201
501.372.2900

Curtilage Consultant
R. A. HEINTGES ARCHITECTS
126 Fifth Avenue 9th Floor
New York, New York 10011
212.652.2966

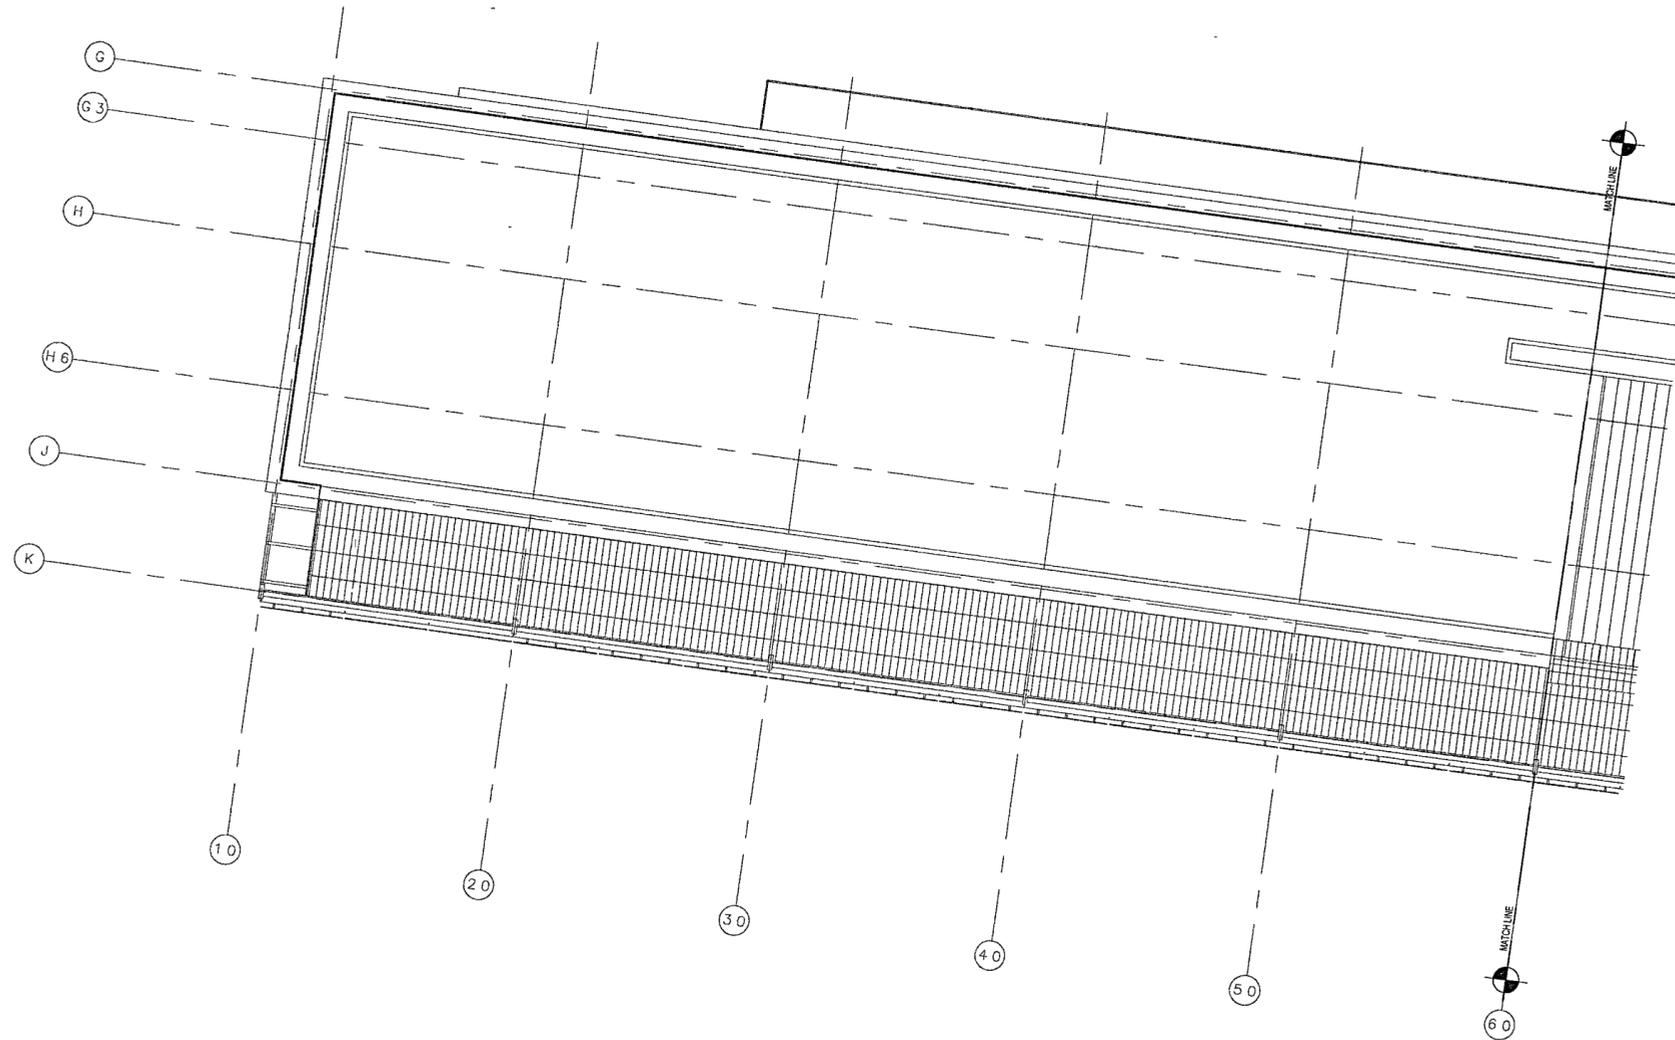


1 MUSEUM ROOF/EXECUTIVE LEVEL - FIRE PROTECTION PLAN
F105a | F105a 1/8" = 1'-0"



Seal



100% Construction Documents	09/27/02
90% Progress Printing	08/30/02
100% Design Development	03/01/02
Issue	Date

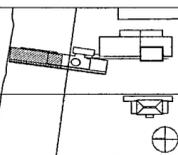


Job No. POLSHEK & PARTNERS ARCH. 9908
CROMWELL AE 99-114
Scale 1/8" = 1'-0"
Date SEPTEMBER 27, 2002

Title **MUSEUM ROOF/
EXECUTIVE LEVEL
FIRE PROTECTION
PARTIAL PLAN**

Sheet No.

 F105a



FOR OFFICIAL USE ONLY