

**WILLIAM J CLINTON
PRESIDENTIAL
CENTER**

LITTLE ROCK, ARKANSAS

Architect
POLSHEK PARTNERSHIP LLP
320 West 13th Street
New York, New York 10014
212.607.7171

Coordinating Architects
POLK STANLEY YEARY ARCHITECTS, Ltd
700 South Schiller Street
Little Rock, Arkansas 72201
501.378.0878

WITSELL EVANS RASCO
501 West Third Street
Little Rock, Arkansas 72201
501.374.5300

WOODS CARADINE ARCHITECTS
2200 South Main Street
Little Rock, Arkansas 72206
501.374.4060

Landscape Architects
HARGREAVES ASSOCIATES
118 Magazine Street
Cambridge, Massachusetts 02139
617.661.0070

LANDSCAPE ARCHITECTURE, Inc.
2300 Coltondale Lane Suite 202
Little Rock, Arkansas 72202
501.374.5610

Structural Engineer
LESLIE E. ROBERTSON ASSOC. RLLP
30 Broad Street 47th Floor
New York, New York 10004
212.750.9000


MEP Engineers
FLACK + KURTZ Inc.
475 Fifth Avenue
New York, New York 10017
212.532.9800

CROWMELL ARCHITECTS ENGINEERS
101 South Spring Street
Little Rock, Arkansas 72201
501.372.2900

Curtilage Consultant
R. A. HEINTGES ARCHITECTS
126 Fifth Avenue 9th Floor
New York, New York 10011
212.652-2966



Issue	Date
100% Construction Documents	09/27/02
90% Progress Printing	08/29/02
100% Design Development	03/01/02

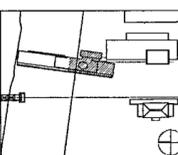


Job No: POLSHEK & PARTNERS ARCH 9806
CROWMELL AE 98-114
Scale: 1/8" = 1'-0"
Date: SEPTEMBER 27, 2002

Title: MUSEUM ROOF/
EXECUTIVE LEVEL
FIRE PROTECTION
PARTIAL PLAN

Sheet No:
F105b



FOR OFFICIAL USE ONLY

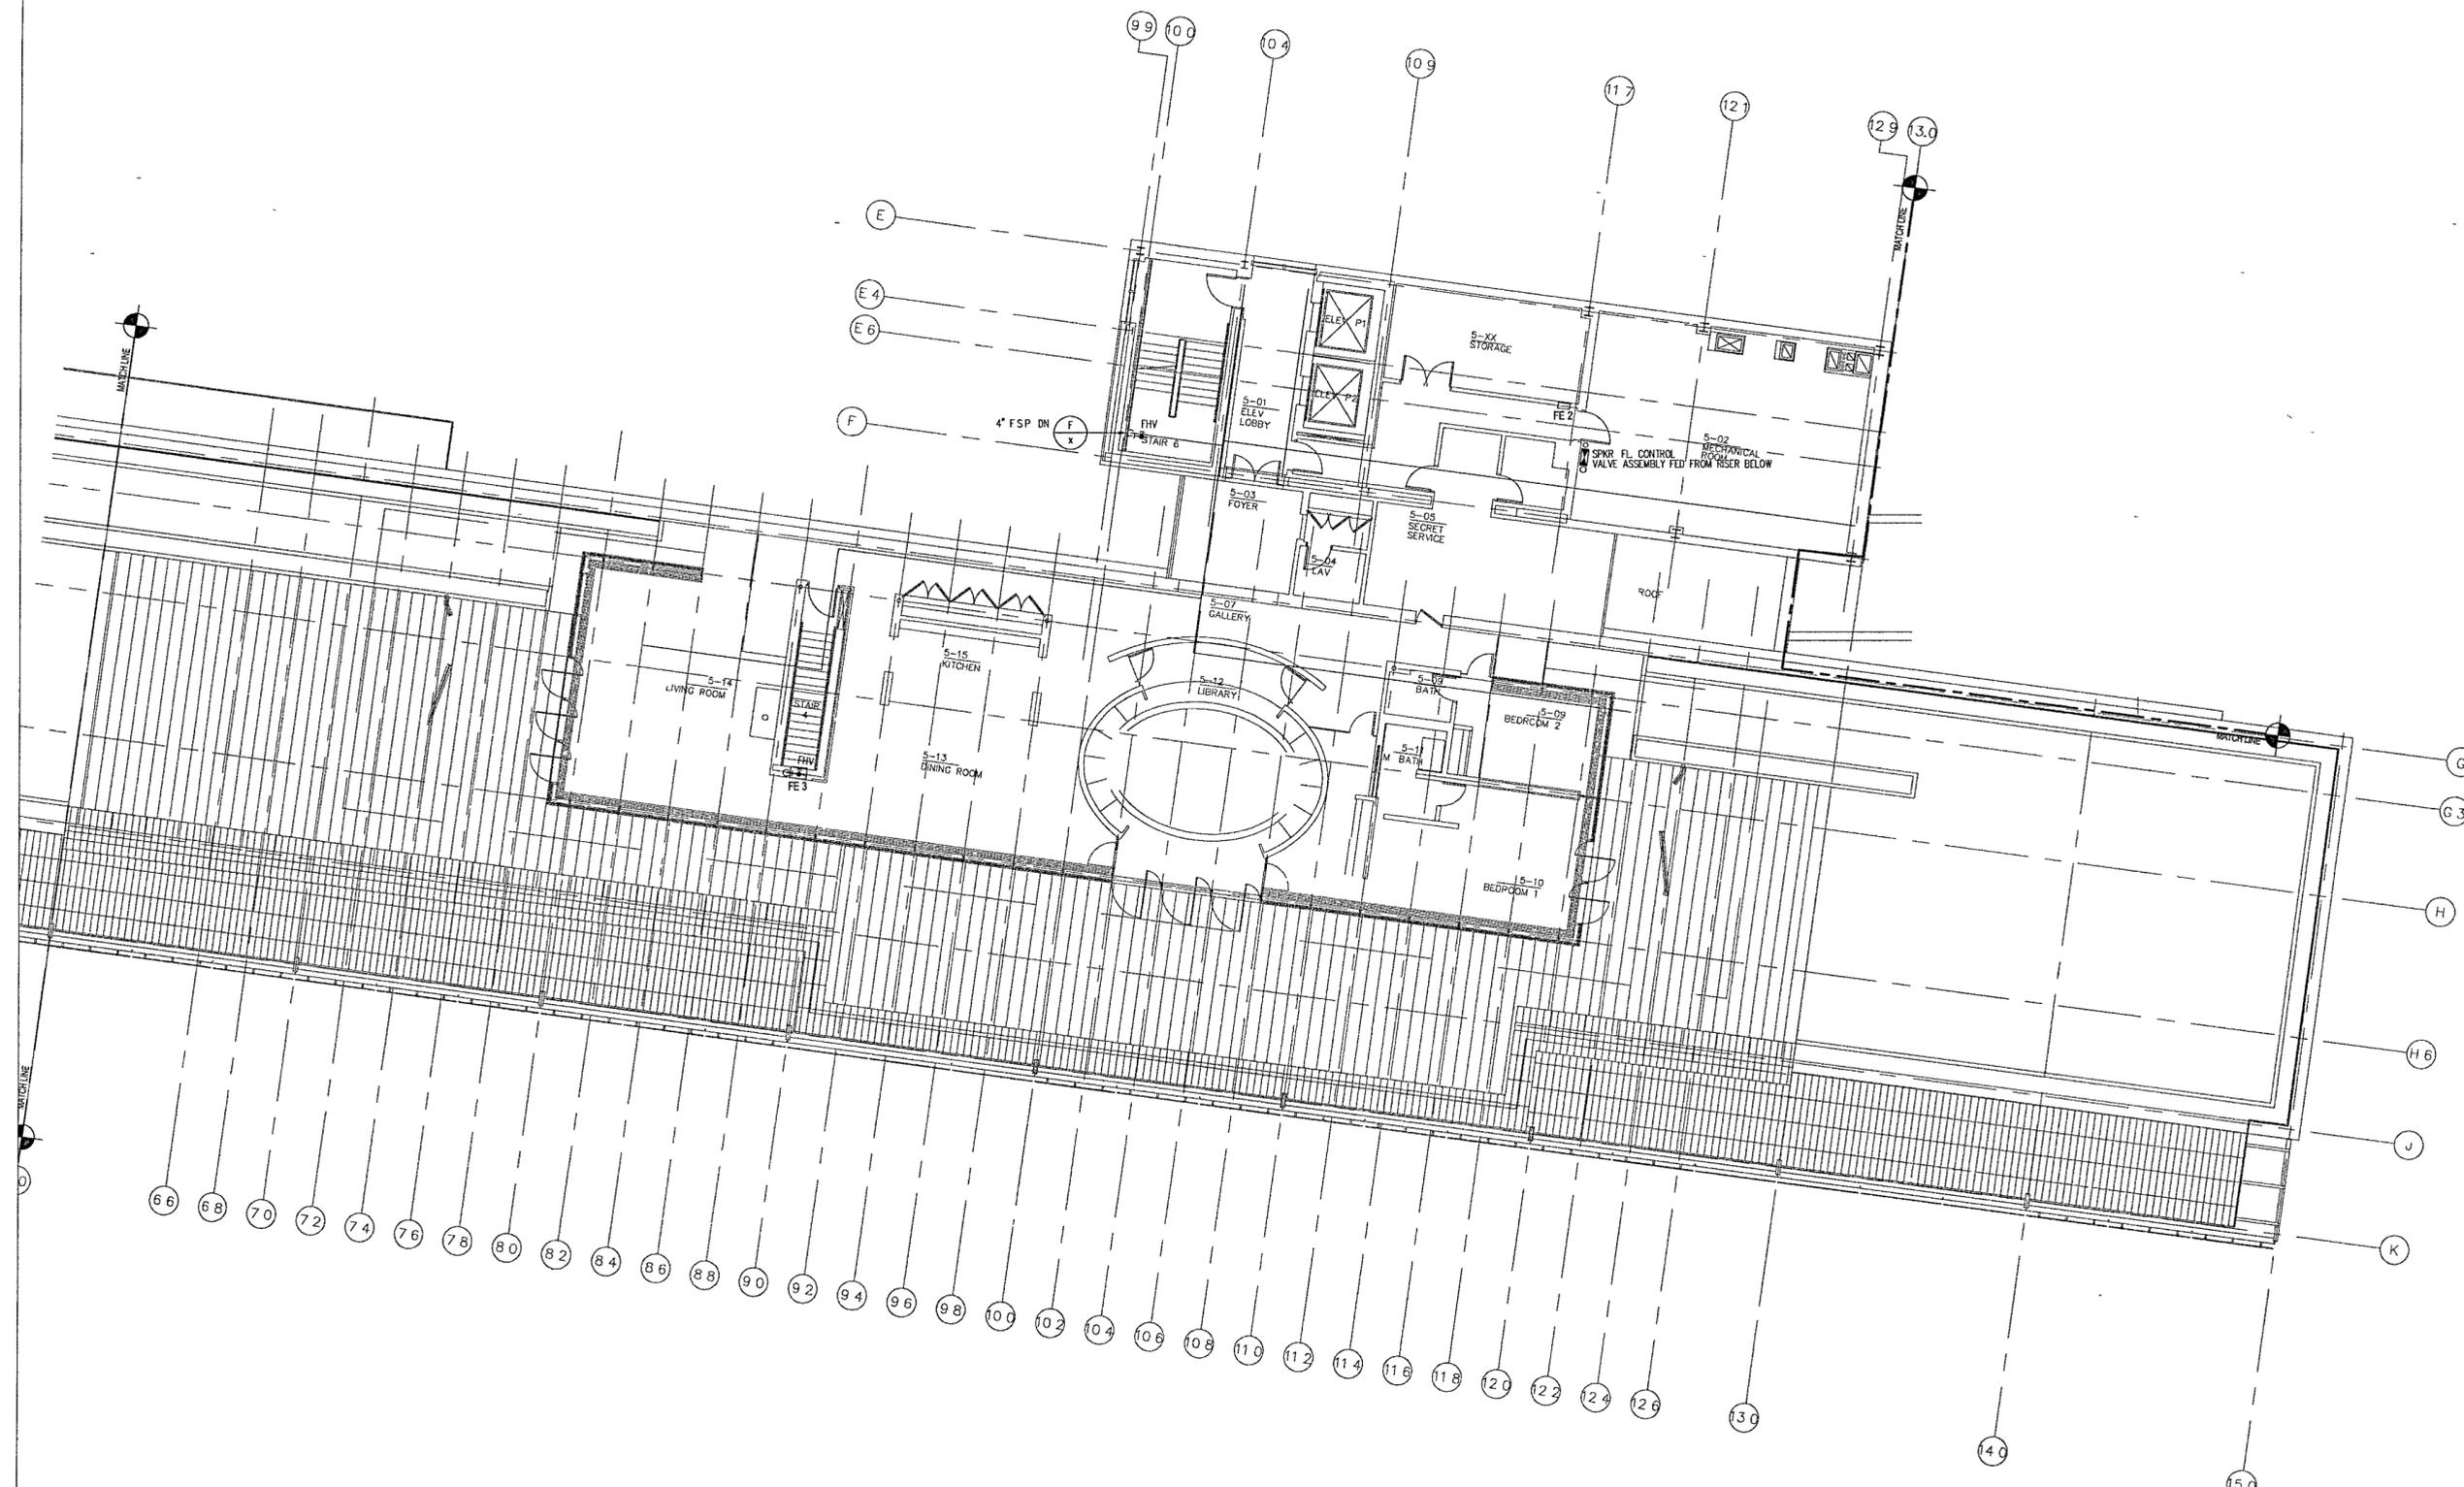

1 MUSEUM ROOF/EXECUTIVE LEVEL - FIRE PROTECTION PLAN
F105b | F105b 1/8" = 1'-0"



10x8