

**WILLIAM J. CLINTON  
PRESIDENTIAL  
CENTER**

LITTLE ROCK, ARKANSAS

Architect  
POLSHEK PARTNERSHIP LLP  
320 West 13th Street  
New York, New York 10014  
212 807 7171

Coordinating Architects  
POLK STANLEY YEARY ARCHITECTS  
700 South Schiller Street  
Little Rock, Arkansas 72201  
501 378 0878

WITSELL EVANS & RASCO  
901 West Third Street  
Little Rock, Arkansas 72201  
501 374 5300

WOODS CARADINE ARCHITECTS  
2200 South Main Street  
Little Rock, Arkansas 72206  
501 374 4060

Landscape Architects  
HARGREAVES ASSOCIATES  
118 Magazine Street  
Cambridge Massachusetts 02139  
617 561 0070

 
LANDSCAPE ARCHITECTURE, Inc.  
2300 Cottondale Lane, Suite 202  
Little Rock, Arkansas 72202  
501 374 5610

Structural Engineer  
LESLIE E. ROBERTSON ASSOC., RLLP  
30 Broad Street, 47th Floor  
New York, New York 10004  
212 750 9000

MEP Engineers  
FLACK + KURTZ Inc.  
475 Fifth Avenue  
New York, New York 10017  
212 532 9600

CROMWELL ARCHITECTS ENGINEERS  
101 South Spring Street  
Little Rock, Arkansas 72201  
501 372 2900


FoodService Consultants



NEXT STEP DESIGN, INC  
1116 West Street, Suite C  
Annapolis, Maryland 21401  
410 263 1200

Seal

100% Construction Docs	9/27/02
90% Progress Printing	8/30/02
100% Construction	6/14/02
100% DD	2/28/02
Issue	Date

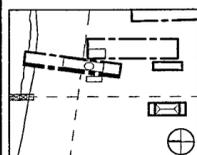

Job No 9908


Scale 1/4" = 1'-0"

Date SEPTEMBER 27, 2002

Title **FOOD SERVICE  
GROUND LEVEL  
EQUIPMENT  
PLAN**

Sheet No

**FS-2**

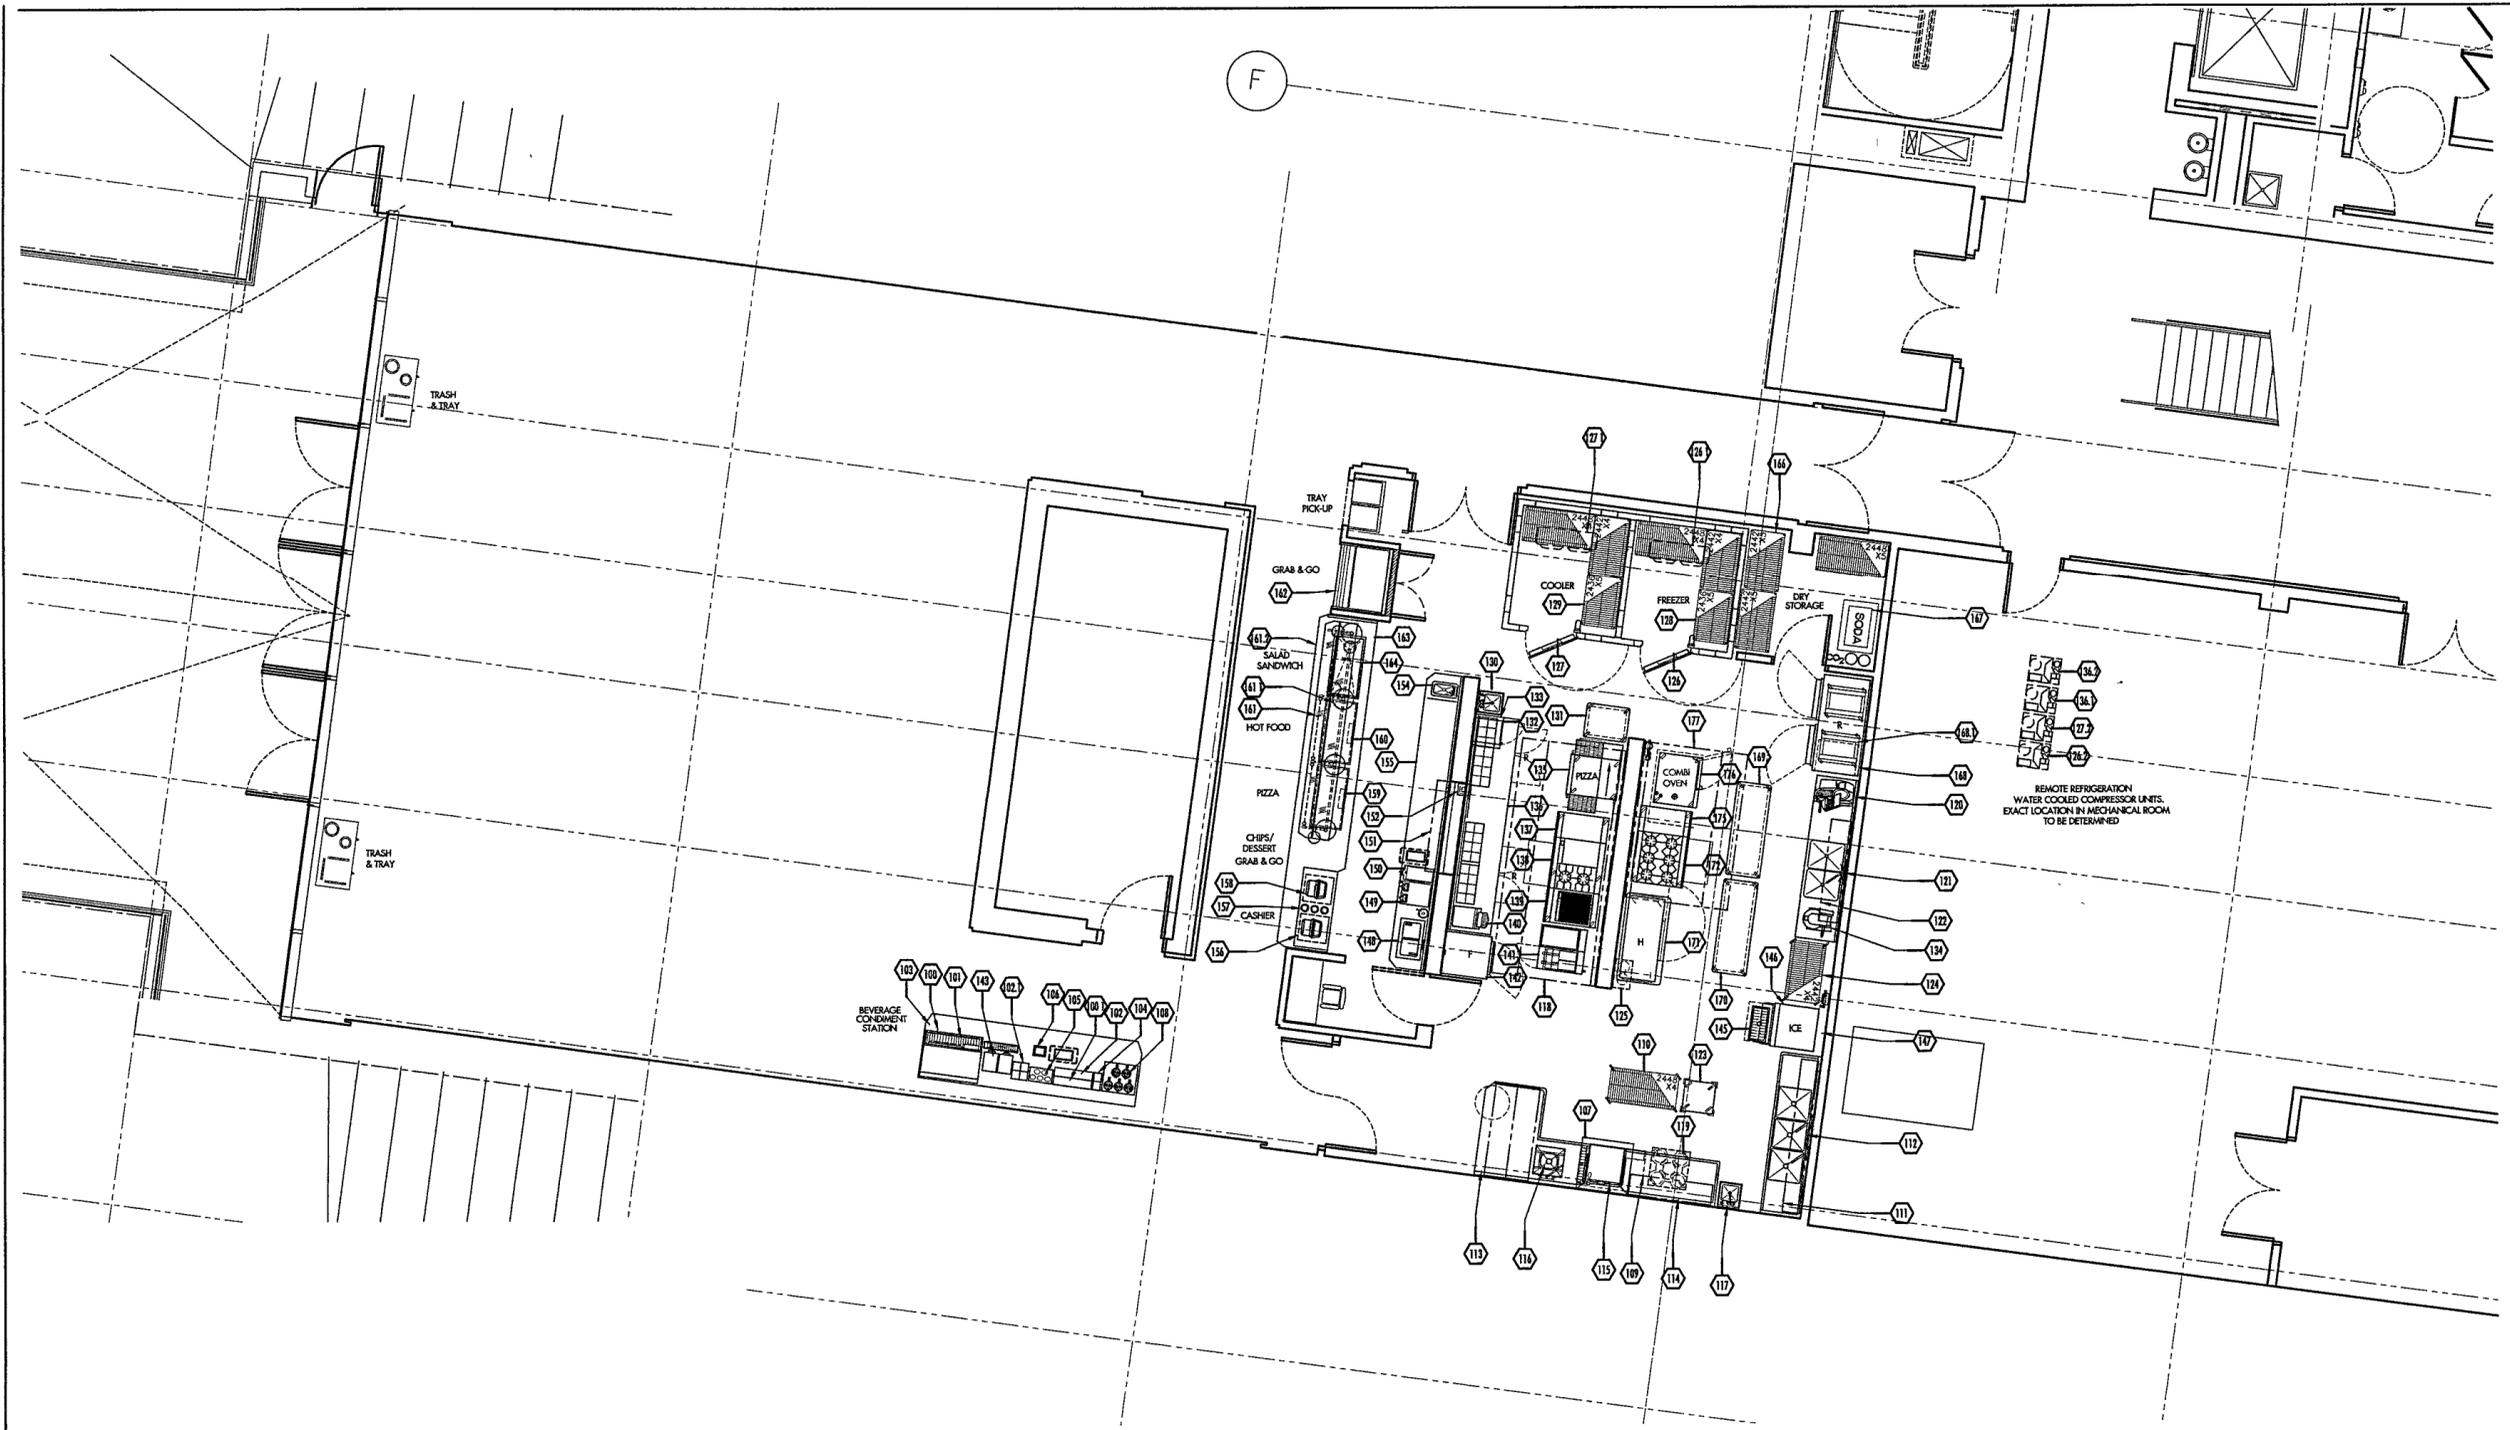

**K.E.C. NOTES**

- 1 REFER TO ARCHITECTURAL DRAWINGS FOR FINISH SCHEDULE AND MILLWORK DETAILS
- 2 FOOD SERVICE EQUIPMENT WILL BE SUPPLIED BY THE OWNER'S KITCHEN EQUIPMENT CONTRACTOR (K.E.C.), EXCEPT AS NOTED
- 3 THE OWNER'S KITCHEN EQUIPMENT CONTRACTOR (K.E.C.) WILL BE RESPONSIBLE FOR THE RECEIVING, STORAGE, DELIVERY TO SITE, UNCRATING, ASSEMBLY, SETTING IN PLACE, LEVELING, AND SEALING OF ALL EQUIPMENT THAT THEY SUPPLY
- 4 ALL ROUGH-INS AND FINAL CONNECTIONS BY GENERAL CONTRACTOR, EXCEPT WHERE NOTED
- 5 K.E.C. TO ASSIST IN FIELD VERIFICATION OF ALL ROUGH-INS AND CRITICAL DIMENSIONS
- 6 K.E.C. TO PROVIDE MINIMUM 1 YEAR PARTS AND SERVICE WARRANTY FOR REFRIGERATION, COOKING, AND MECHANICAL EQUIPMENT
- 7 K.E.C. TO HANG EXHAUST HOODS ONLY
- 8 K.E.C. TO PROVIDE FULLY OPERATIONAL FIRE SYSTEM AND OBTAIN ALL APPROVALS
- 9 K.E.C. TO PROVIDE FINAL START UP OF ALL REFRIGERATION, RUN REQUIRED REFRIGERANT LINES AND HANG COILS
- 10 K.E.C. - FOR COMPLETE SPECIFICATIONS AND MODEL NUMBERS, THESE PLANS MUST BE BID WITH FOOD SERVICE SPECIFICATIONS BOOK.

**GROUND LEVEL EQUIPMENT FLOOR PLAN**

SCALE 1/4" = 1'-0"

**G.C. NOTES**

- 1 GENERAL CONTRACTOR WILL MOUNT ALL WALL-MOUNTED EQUIPMENT UNLESS OTHERWISE NOTED
- 2 GENERAL CONTRACTOR WILL REINFORCE ALL WALLS BEHIND WALL-MOUNTED EQUIPMENT (SEE SPECIAL CONDITIONS PLAN)
- 3 PLUMBER WILL COMPLETELY INSTALL ALL HAND SINKS, FLOOR TROUGHS, DISPOSERS, & FAUCETS (AS PROVIDED BY THE KEC)
- 4 REFER TO ARCHITECTURAL DRAWINGS FOR FINISH SCHEDULE AND MILLWORK DETAILS
- 5 ALL ROUGH-INS AND FINAL CONNECTIONS WILL BE DONE BY GENERAL CONTRACTOR, EXCEPT WHERE NOTED
- 6 GENERAL CONTRACTOR TO READ ALL NOTES AND REVIEW ALL FOODSERVICE PLANS FOR COMPLETE SCOPE OF WORK