

**WILLIAM J CLINTON  
PRESIDENTIAL  
CENTER**

LITTLE ROCK, ARKANSAS

Architect  
POLSHEK PARTNERSHIP LLP  
320 West 13th Street  
New York, New York 10014  
212 807 7171

Coordinating Architects  
POLK STANLEY YEARY ARCHITECTS  
700 South Schiller Street  
Little Rock, Arkansas 72201  
501 378 0878

WITSELL EVANS & RASCO  
801 West Third Street  
Little Rock, Arkansas 72201  
501 374 5300

WOODS CARADINE ARCHITECTS  
2200 South Main Street  
Little Rock, Arkansas 72206  
501 374.4060

Landscape Architects  
HARGREAVES ASSOCIATES  
118 Magazine Street  
Cambridge, Massachusetts 02139  
617 661 0070

LANDSCAPE ARCHITECTURE, Inc.  
2300 Cottondale Lane Suite 202  
Little Rock, Arkansas 72202  
501 374 5810

Structural Engineer  
LESLIE E. ROBERTSON ASSOC., RLLP  
30 Broad Street, 47th Floor  
New York, New York 10004  
212 750 9000

MEP Engineers  
FLACK + KURTZ Inc.  
475 Fifth Avenue  
New York, New York 10017  
212 532 9600


CROMWELL ARCHITECTS ENGINEERS  
101 South Spring Street  
Little Rock, Arkansas 72201  
501 372 2800

FoodService Consultants

  
NEXT STEP DESIGN, INC.  
1118 West Street, Suite C  
Annapolis, Maryland 21401  
410 263 1200

Seal

100% Construction Docs.	9/27/02
90% Progress Printing	8/30/02
100% Construction	6/14/02
100% DD	2/28/02
Issue	Date

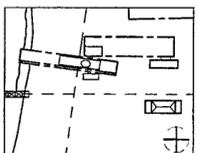

Job No. 9908


Scale 1/4" = 1'-0"

Date SEPTEMBER 27, 2002

Title **FOOD SERVICE  
GROUND LEVEL  
PLUMBING ROUGH-IN  
PLAN**

Sheet No.

**FS-P2**

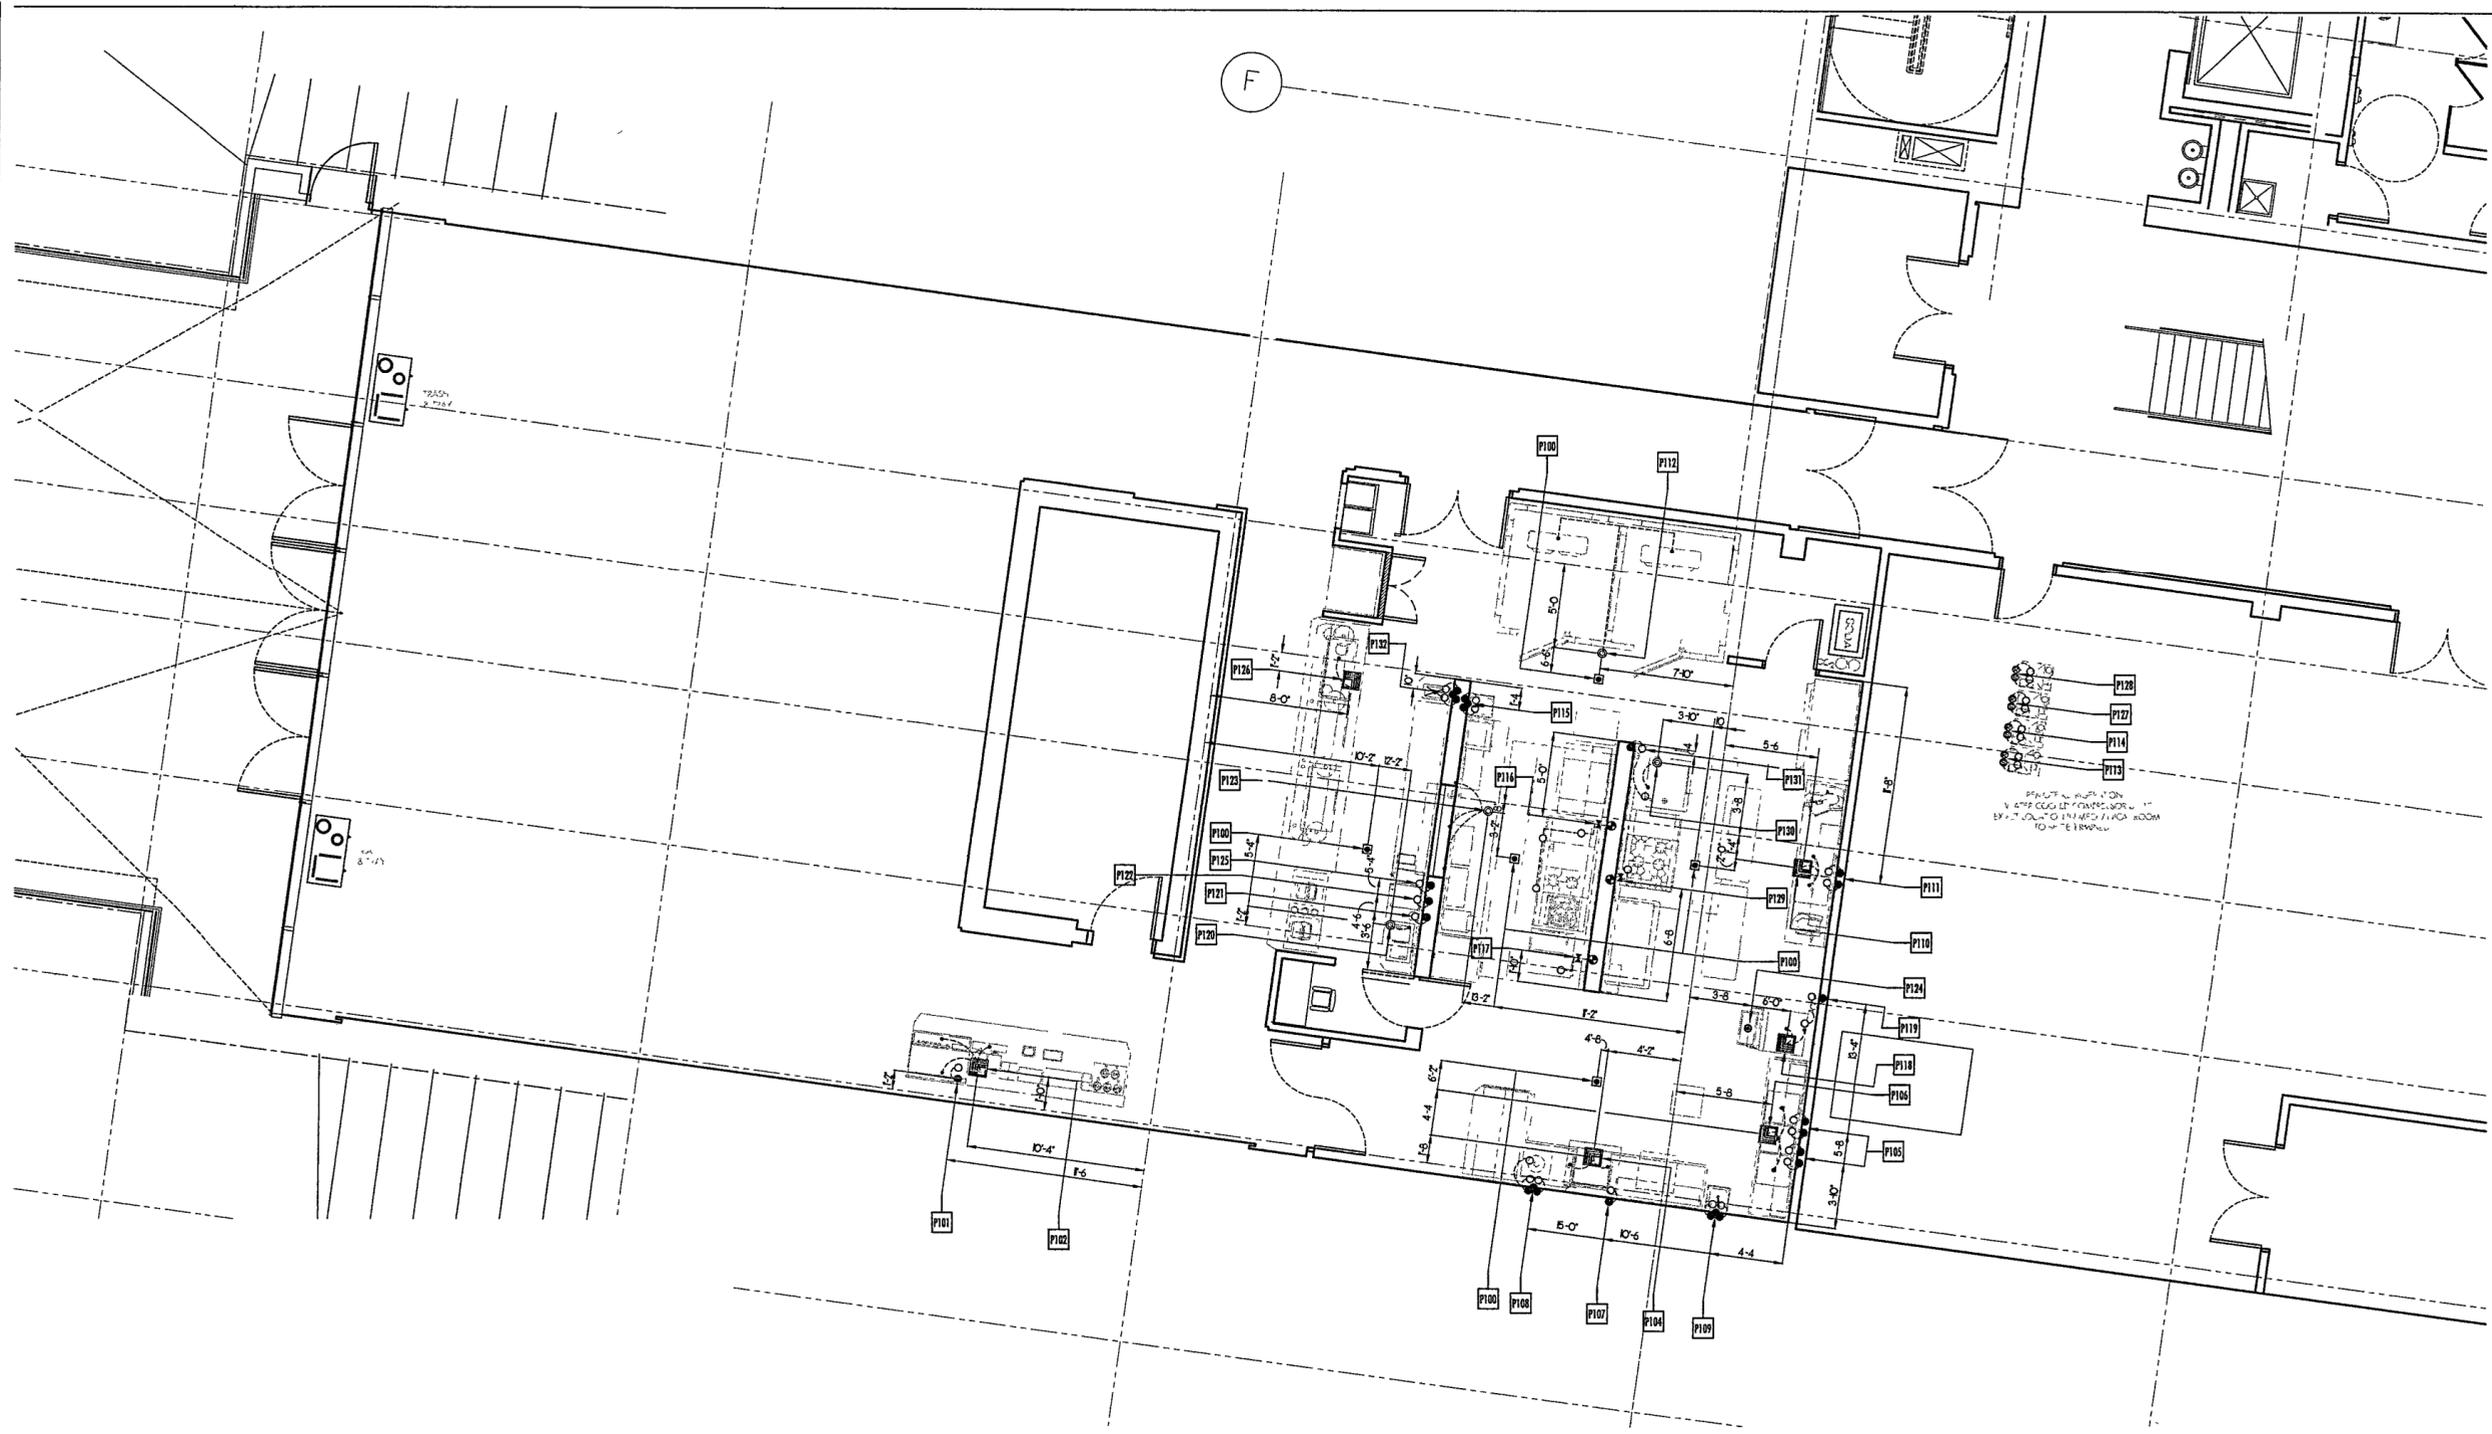

**GROUND LEVEL PLUMBING ROUGH-IN PLAN**

SCALE 1/4" = 1'-0"

**GENERAL PLUMBING NOTES**

- ALL WORK TO BE DONE IN ACCORDANCE WITH ALL LOCAL CODES
- ALL WATER LINES TO HAVE SHUT-OFF VALVES
- PLUMBER TO PROVIDE DISHWASHER HOT WATER, MINIMUM 140° F., CONSTANT SUPPLY
- ALL INTERCONNECTING AND FINAL CONNECTIONS BY PLUMBER
- FOR COMPLETE PLUMBING SCOPE OF WORK - REFER TO PLUMBING ENGINEERING DRAWINGS BY OTHERS
- THE HOT WATER HEATER SHALL BE SIZED TO THE MAXIMUM USE DEMANDS OF ALL PLUMBING FIXTURES
- PLUMBER CONTRACTOR TO PIPE DRAINS FROM WALK-IN COOLER EVAPORATOR UNITS TO OPEN SITE DRAIN. USE COPPER PIPE ONLY
- PLUMBER TO SUPPLY AND INSTALL BACK FLOW PREVENTERS ON ALL EQUIPMENT AS REQUIRED BY LOCAL CODES
- PLUMBER CONTRACTOR TO COMPLETELY INSTALL ALL HAND SINKS, FAUCETS, LEVER DRAINS, & GARBAGE DISPOSALS, AS PROVIDED BY THE K.E.C.
- PLUMBER TO SUPPLY AND INSTALL VACUUM BREAKERS FOR COFFEE AND ICE MAKERS
- PLUMBER TO INSTALL SOLENOID VALVE AND VACUUM BREAKERS FOR DISPOSERS
- PLUMBER TO SUPPLY AND INSTALL ANY REQUIRED GREASE TRAP OR RECEPTOR AS MAY BE REQUIRED BY LOCAL CODES. SEE PLUMBING ENGINEERING PLANS BY OTHERS FOR DETAILS AND SPECIFICATIONS
- PLUMBER TO INSTALL ALL FLOOR SINKS FLUSH OR JUST BELOW THE FINISHED FLOOR.
- PLUMBER TO INSTALL SHUT-OFF VALVE IN MAIN GAS LINE FOR FIRE EXTINGUISHING SYSTEM. VALVE PROVIDED BY K.E.C.
- PLUMBER TO INSTALL FLEXIBLE QUICK DISCONNECTS, AS SUPPLIED BY THE K.E.C., ON ITEM NO'S 8, 10, 137, 141, & 172.

**PLUMBING LEGEND**

- CONNECTION
- STUB-UP PIPE
- SHUT OFF
- GAS PIPE STUB-UP
- OPEN SITE FLOOR DRAIN
- FLOOR SINK (3/4 GRATE)
- AREA FLOOR DRAIN
- ⊙ REMOTE CONDENSING WATER SUPPLY
- ⊙ REMOTE CONDENSING WATER RETURN
- CW COLD WATER
- HW HOT WATER
- W WASTE
- IW INDIRECT WASTE
- BTU BRITISH THERMAL UNIT
- SE SELF EVAPORATOR
- AFF ABOVE FINISH FLOOR
- PSI POUNDS PER SQUARE INCH
- BTIC BRANCH TO CONNECTION

