

**WILLIAM J. CLINTON
PRESIDENTIAL
CENTER**

LITTLE ROCK, ARKANSAS

Architect
POLSHEK PARTNERSHIP LLP
320 West 13th Street
New York, New York 10014
212 807 7171

Coordinating Architects
POLK STANLEY YEARY ARCHITECTS
700 South Schiller Street
Little Rock, Arkansas 72201
501 378.0878

WITSELL EVANS & RASCO
901 West Third Street
Little Rock, Arkansas 72201
501 374 5300

WOODS CARADINE ARCHITECTS
2200 South Main Street
Little Rock, Arkansas 72206
501 374-4080

Landscape Architects
HARGREAVES ASSOCIATES
118 Magazine Street
Cambridge, Massachusetts 02139
617 661 0070

LANDSCAPE ARCHITECTURE, Inc
2300 Cottondale Lane, Suite 202
Little Rock, Arkansas 72202
501 374 5610

Structural Engineer
LESLIE E. ROBERTSON ASSOC., RLLP
30 Broad Street, 47th Floor
New York, New York 10004
212 750 9000

MEP Engineers
FLACK + KURTZ Inc.
475 Fifth Avenue
New York, New York 10017
212 532-9600


CROMWELL ARCHITECTS ENGINEERS
101 South Spring Street
Little Rock, Arkansas 72201
501 372-2900



NEXT STEP DESIGN, INC
1116 West Street, Suite C
Annapolis, Maryland 21401
410 263 1200

Seal

100% Construction Docs	9/27/02
90% Progress Printing	8/30/02
100% Construction	8/14/02
100% DD	2/28/02
Issue	Date

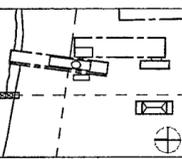

Job No 9908


Scale 1/4" = 1'-0"

Date SEPTEMBER 27, 2002

Title
**FOOD SERVICE
GROUND LEVEL
ELECTRICAL
ROUGH-IN PLAN**

Sheet No

FS-E2

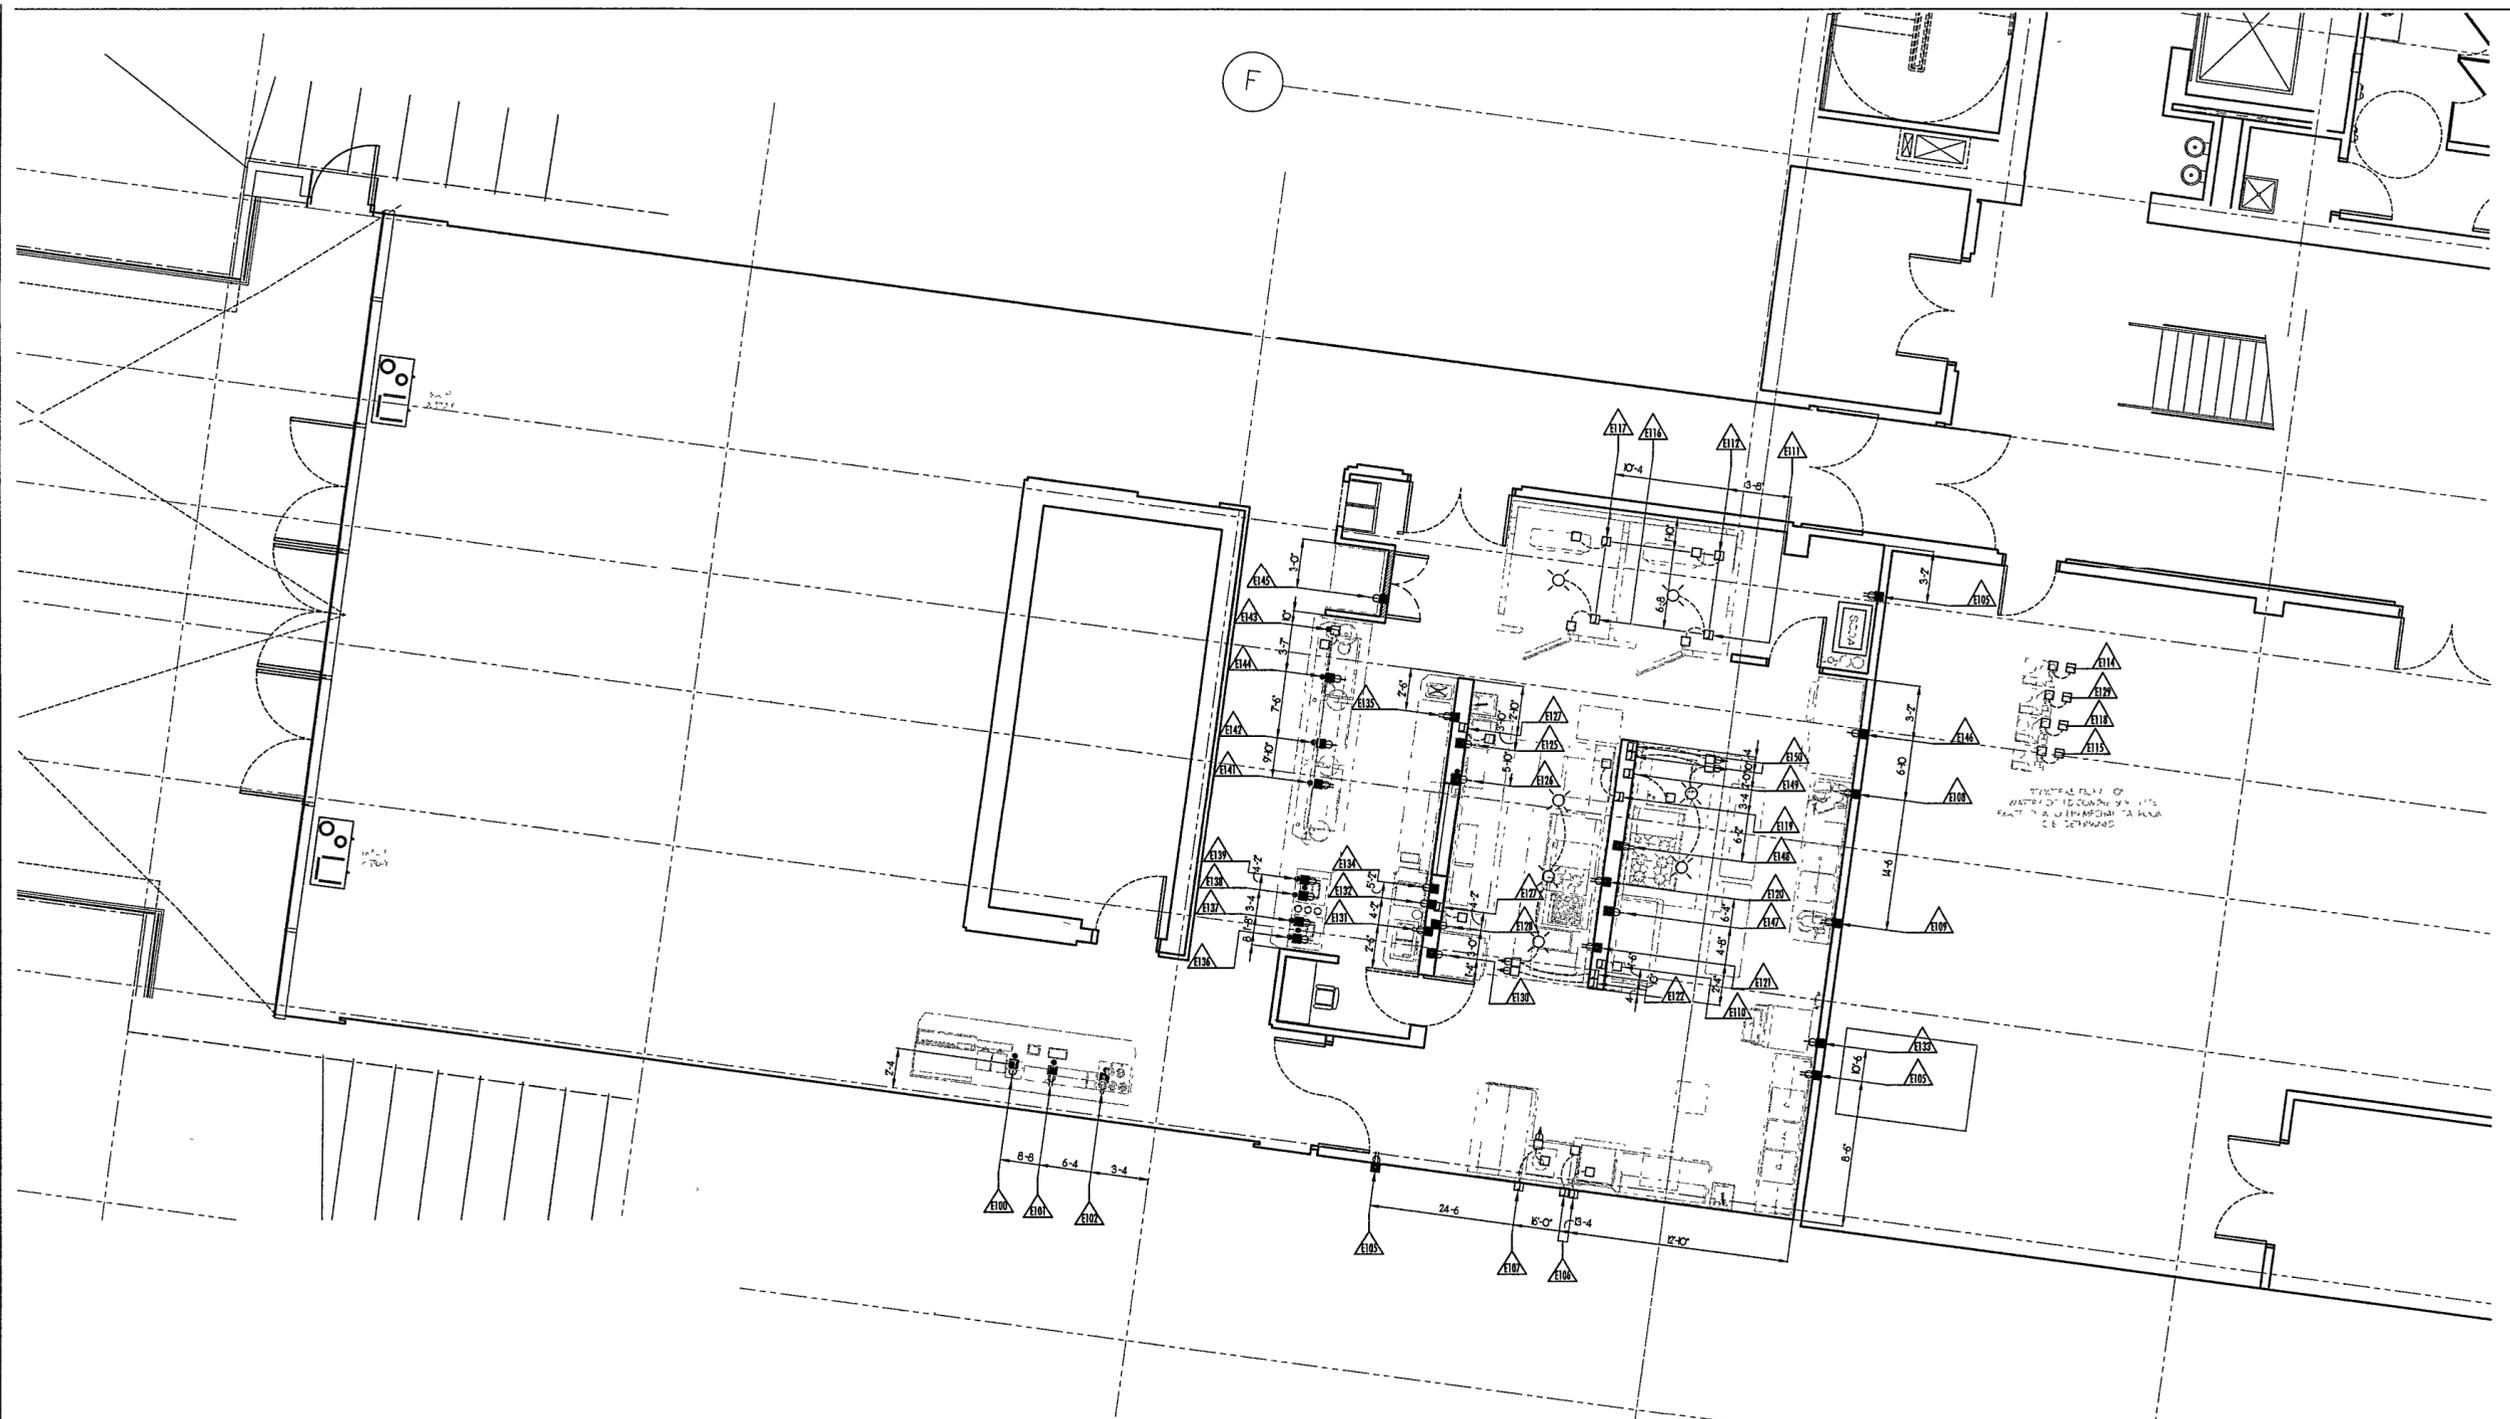

- GENERAL ELECTRICAL NOTES**
- ALL WORK TO BE DONE IN ACCORDANCE WITH ALL LOCAL CODES
 - SEE ELECTRICAL ENGINEERING PLANS BY OTHERS FOR COMPLETE SCOPE OF WORK AND ELECTRICAL SPECIFICATIONS
 - ELECTRICIAN TO SUPPLY AND INSTALL ALL DUPLEX RECEPTACLES AND SWITCHES WITH STAINLESS STEEL FACE PLATES
 - ELECTRICIAN TO SUPPLY ALL NECESSARY CONTACTORS, STARTERS, AND DISCONNECTS
 - ELECTRICIAN TO WIRE DISPOSER WITH START-STOP STATION AND SOLENOID VALVE
 - ELECTRICIAN TO INTERWIRE CONDENSING UNIT WITH EVAPORATOR COIL IN WALK-IN COOLER
 - ELECTRICIAN TO PROVIDE AND INSTALL (WRAP) HEAT TAPE AROUND CONDENSATE DRAIN LINES IN WALK-IN FREEZER
 - ELECTRICIAN TO INTERWIRE EXTRA LIGHT FIXTURES IN WALK-IN COOLER, ITEM NO'S 126 & 127
 - ELECTRICIAN TO INTERWIRE FIRE EXTINGUISHING SYSTEM WITH EXHAUST FAN AND COOKING BATTERY, TO CAUSE FAN TO TURN ON AND COOKING BATTERY TO TURN OFF WHEN FIRE SYSTEM IS ACTIVATED
 - ELECTRICIAN TO SUPPLY CONTACTORS AND/OR SHUNT TRIP BREAKERS TO PROVIDE FOR TOTAL FUEL SHUT-OFF TO COOKING BATTERY
 - ELECTRICIAN TO WIRE AND INSTALL START-STOP STATION WITH RED LIGHT INDICATOR FOR EXHAUST AND RETURN AIR FANS
 - ELECTRICIAN TO CONNECT HOOD LIGHTS IN EXHAUST, AND WIRE TO WALL SWITCH IN HOOD. SEE FS-H1 & FS-H2
 - ELECTRICIAN TO SUPPLY AND INSTALL START-STOP STATION FOR EXHAUST FAN ON DISHWASHER. DUCT AND FAN BY OTHERS.

GROUND LEVEL ELECTRICAL ROUGH-IN PLAN

SCALE 1/4" = 1'-0"

- ELECTRICAL LEGEND**
- DUPLEX RECEPTACLE
 - SINGLE RECEPTACLE
 - CEILING LIGHT
 - WALL LIGHT
 - JUNCTION BOX
 - DROP CORD (HEIGHT AS INDICATED)
 - WALL SWITCH
 - CONNECTION
 - STUB-UP CONDUIT
 - STUB-UP CONDUIT
 - EMPTY CONDUIT FOR BEVERAGE LINES
 - VOLT
 - PHASE
 - KW KILOWATT
 - AMP AMPERE
 - H P HORSE POWER
 - AFF ABOVE FINISH FLOOR
 - C&P CORD AND PLUG
 - CONV CONVENIENCE OUTLET