


**GENERAL NOTES.**

- 1 BEFORE INSTALLATION OF ANY DUCTWORK, THE CONTRACTOR SHALL COORDINATE ALL PLUMBING, FIRE PROTECTION, AND DUCTWORK ROUTING
- 2 REFER TO THE ARCHITECTURAL REFLECTED CEILING PLANS AND ELEVATIONS FOR EXACT LOCATION OF AIR DEVICES AND LOUVERS
- 3 ALL SUPPLY AND RETURN BRANCHES TO AND FROM AIR DEVICES IN AREAS WITH LAY-IN CEILING SHALL BE PROVIDED WITH A VOLUME DAMPER AT THE MAIN DUCT
- 4 PROVIDE 5'-0" MAXIMUM FLEX DUCT AT AIR DEVICES
- 5 VERIFY ROOM SENSOR (THERMOSTAT) LOCATIONS WITH THE CONSTRUCTION MANAGER
- 6 COORDINATE LOCATION OF CONDUITS IN BLOCK WALLS FOR ROOM SENSORS WITH CONSTRUCTION MANAGER. SURFACE MOUNTED CONDUIT IS NOT ALLOWED
- 7 PROVIDE DYNAMIC FIRE DAMPERS OF PROPER RATING AT ALL DUCT PENETRATIONS THROUGH RATED WALLS
- 8 PROVIDE ACCESS DOORS IN DRYWALL CEILINGS AS REQUIRED TO PROVIDE ACCESS FOR MAINTENANCE TO VALVES, DAMPERS, FIRE DAMPERS, ETC

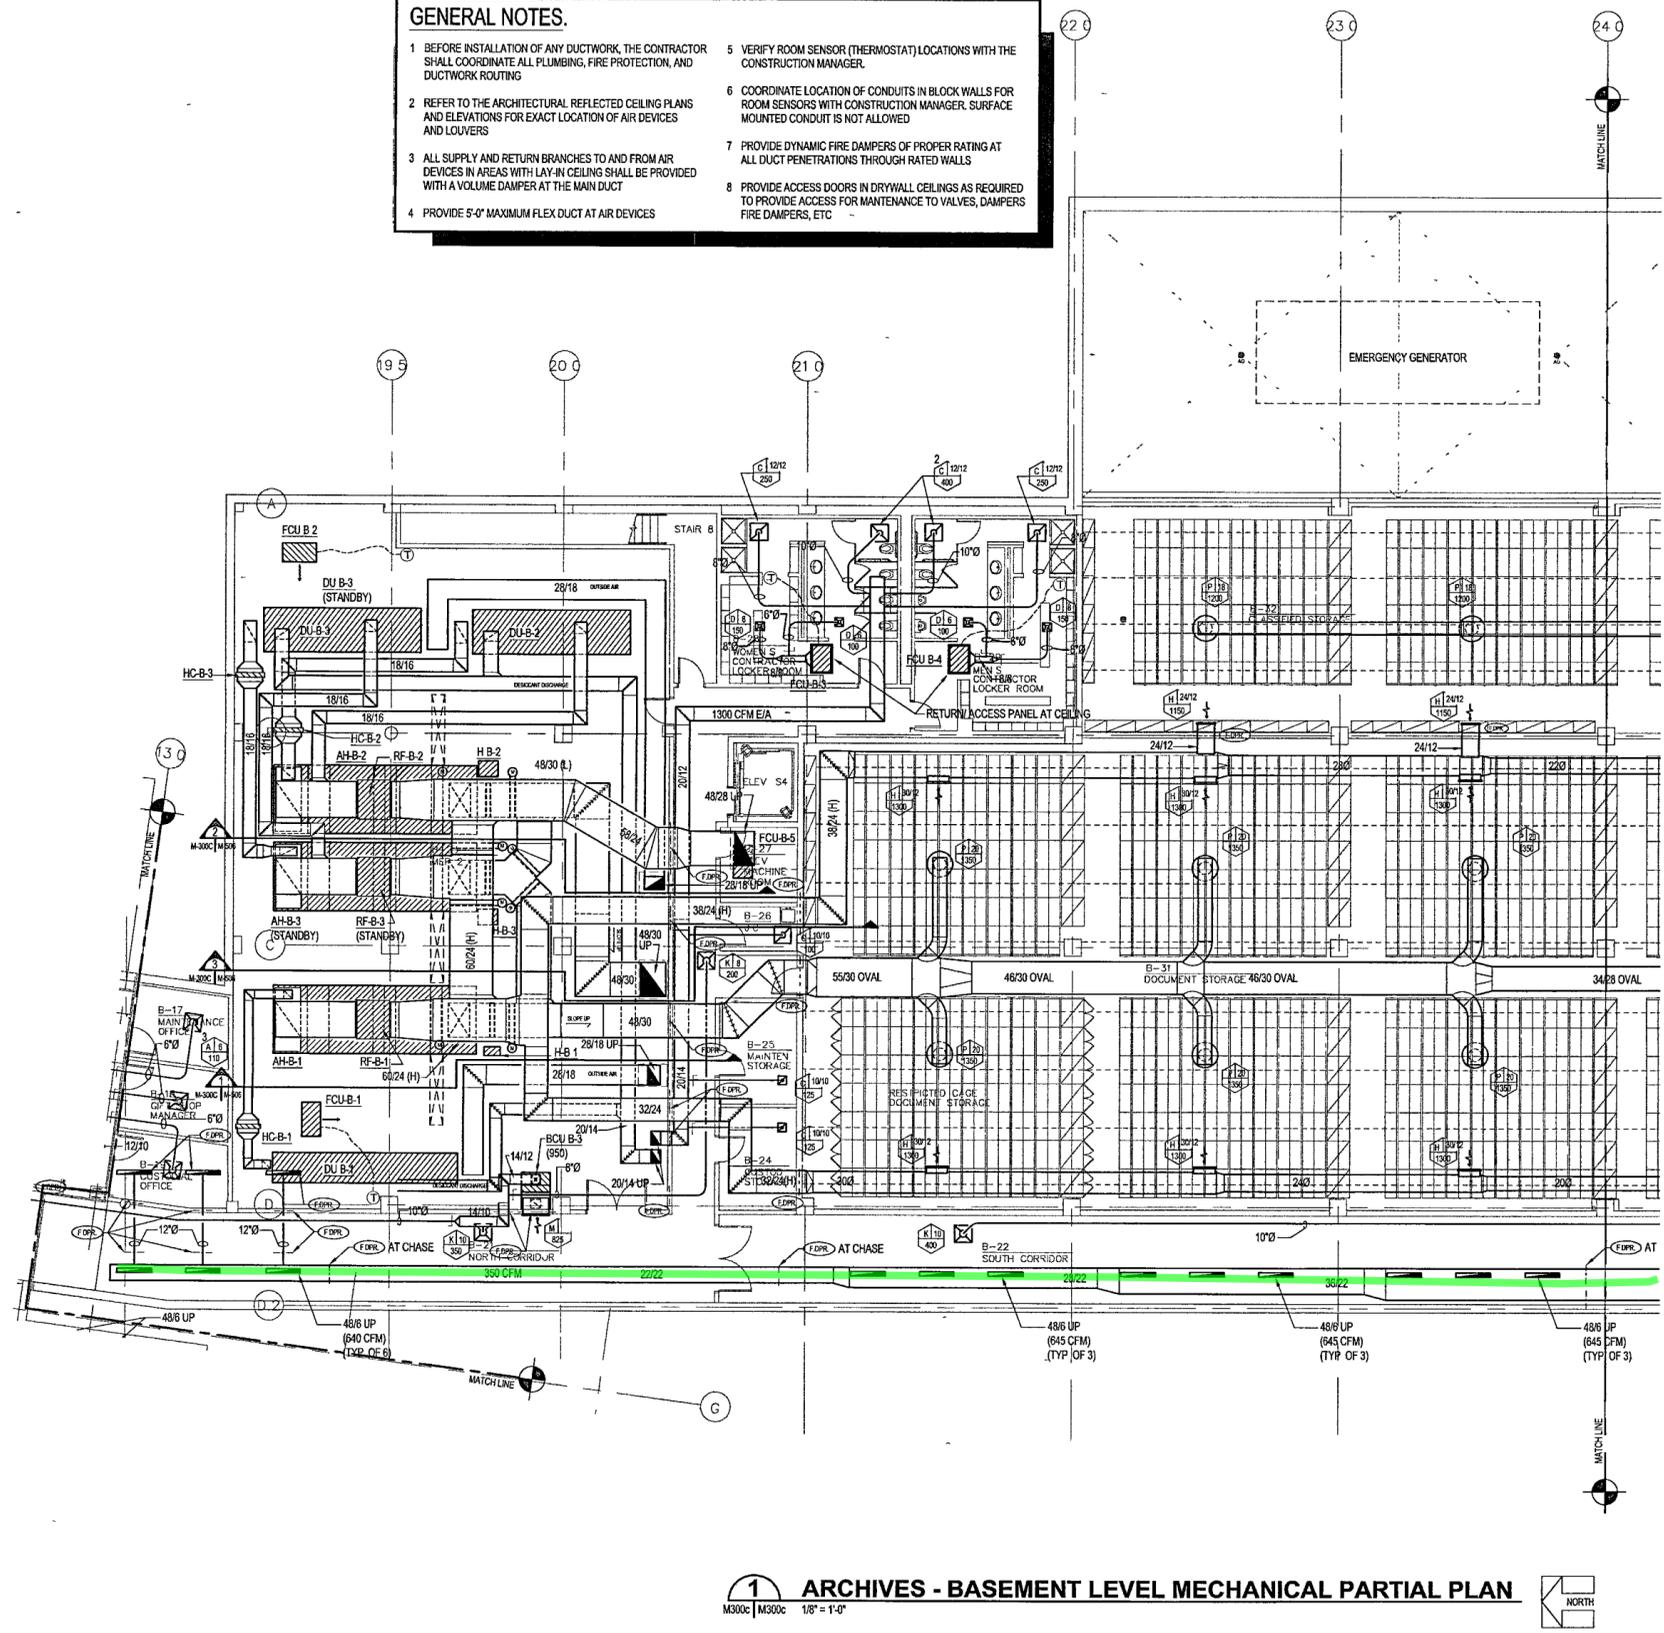

**1 ARCHIVES - BASEMENT LEVEL MECHANICAL PARTIAL PLAN**

M300C | M300C | 1/8" = 1'-0"



**WILLIAM J CLINTON  
PRESIDENTIAL  
CENTER**

LITTLE ROCK, ARKANSAS

Architect  
POLSHEK PARTNERSHIP LLP  
320 West 13th Street  
New York, New York 10014  
212.807.7171

Coordinating Architects  
POLK STANLEY YEARY ARCHITECTS, Ltd  
700 South Sabine Street  
Little Rock, Arkansas 72201  
501.378.0878

WITSSELL EVANS RASCO  
901 West Third Street  
Little Rock, Arkansas 72201  
501.374.5300

WOODS CARADINE ARCHITECTS  
2200 South Main Street  
Little Rock, Arkansas 72206  
501.374.4060

Landscape Architects  
HARGREAVES ASSOCIATES  
118 Magazine Street  
Cambridge, Massachusetts 02139  
617.851.0070


LANDSCAPE ARCHITECTURE, Inc.  
2300 Cottondale Lane Suite 202  
Little Rock, Arkansas 72202  
501.374.5510

Structural Engineer  
LESLIE E. ROBERTSON ASSOC. RLLP  
30 Broad Street, 4th Floor  
New York, New York 10004  
212.750.9000


MEP Engineers  
FLACK + KURTZ Inc.  
475 Fifth Avenue  
New York, New York 10017  
212.532.9600

CROMWELL ARCHITECTS ENGINEERS  
101 South Spring Street  
Little Rock, Arkansas 72201  
501.372.2900

Curtilwall Consultant  
R. A. HENTGES ARCHITECTS  
126 Fifth Avenue, 9th Floor  
New York, New York 10011  
212.632.2966

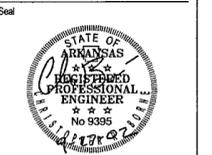

	Date
100% Construction Documents	09/27/02
90% Progress Printing	08/30/02
100% Design Development	03/01/02
Issue	Date

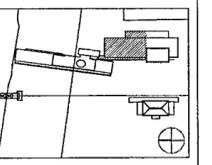

Job No: POLSHEK & PARTNERS ARCH 9908  
CROMWELL AE 99-114

Scale: 1/8" = 1'-0"

Date: SEPTEMBER 27, 2002

Title: **ARCHIVES  
BASEMENT LEVEL  
MECHANICAL  
PARTIAL PLAN**

Sheet No: **M300C**



**FOR OFFICIAL USE ONLY**