


**GENERAL NOTES:**

- BEFORE INSTALLATION OF ANY DUCTWORK, THE CONTRACTOR SHALL COORDINATE ALL PLUMBING, FIRE PROTECTION, AND DUCTWORK ROUTING
- REFER TO THE ARCHITECTURAL REFLECTED CEILING PLANS AND ELEVATIONS FOR EXACT LOCATION OF AIR DEVICES AND LOUVERS
- ALL SUPPLY AND RETURN BRANCHES TO AND FROM AIR DEVICES IN AREAS WITH LAY-IN CEILING SHALL BE PROVIDED WITH A VOLUME DAMPER AT THE MAIN DUCT
- PROVIDE 5'-0" MAXIMUM FLEX DUCT AT AIR DEVICES
- VERIFY ROOM SENSOR (THERMOSTAT) LOCATIONS WITH THE CONSTRUCTION MANAGER.
- COORDINATE LOCATION OF CONDUITS IN BLOCK WALLS FOR ROOM SENSORS WITH CONSTRUCTION MANAGER. SURFACE MOUNTED CONDUIT IS NOT ALLOWED
- PROVIDE DYNAMIC FIRE DAMPERS OF PROPER RATING AT ALL DUCT PENETRATIONS THROUGH RATED WALLS
- PROVIDE ACCESS DOORS IN DRYWALL CEILINGS AS REQUIRED TO PROVIDE ACCESS FOR MAINTENANCE TO VALVES, DAMPERS FIRE DAMPERS, ETC

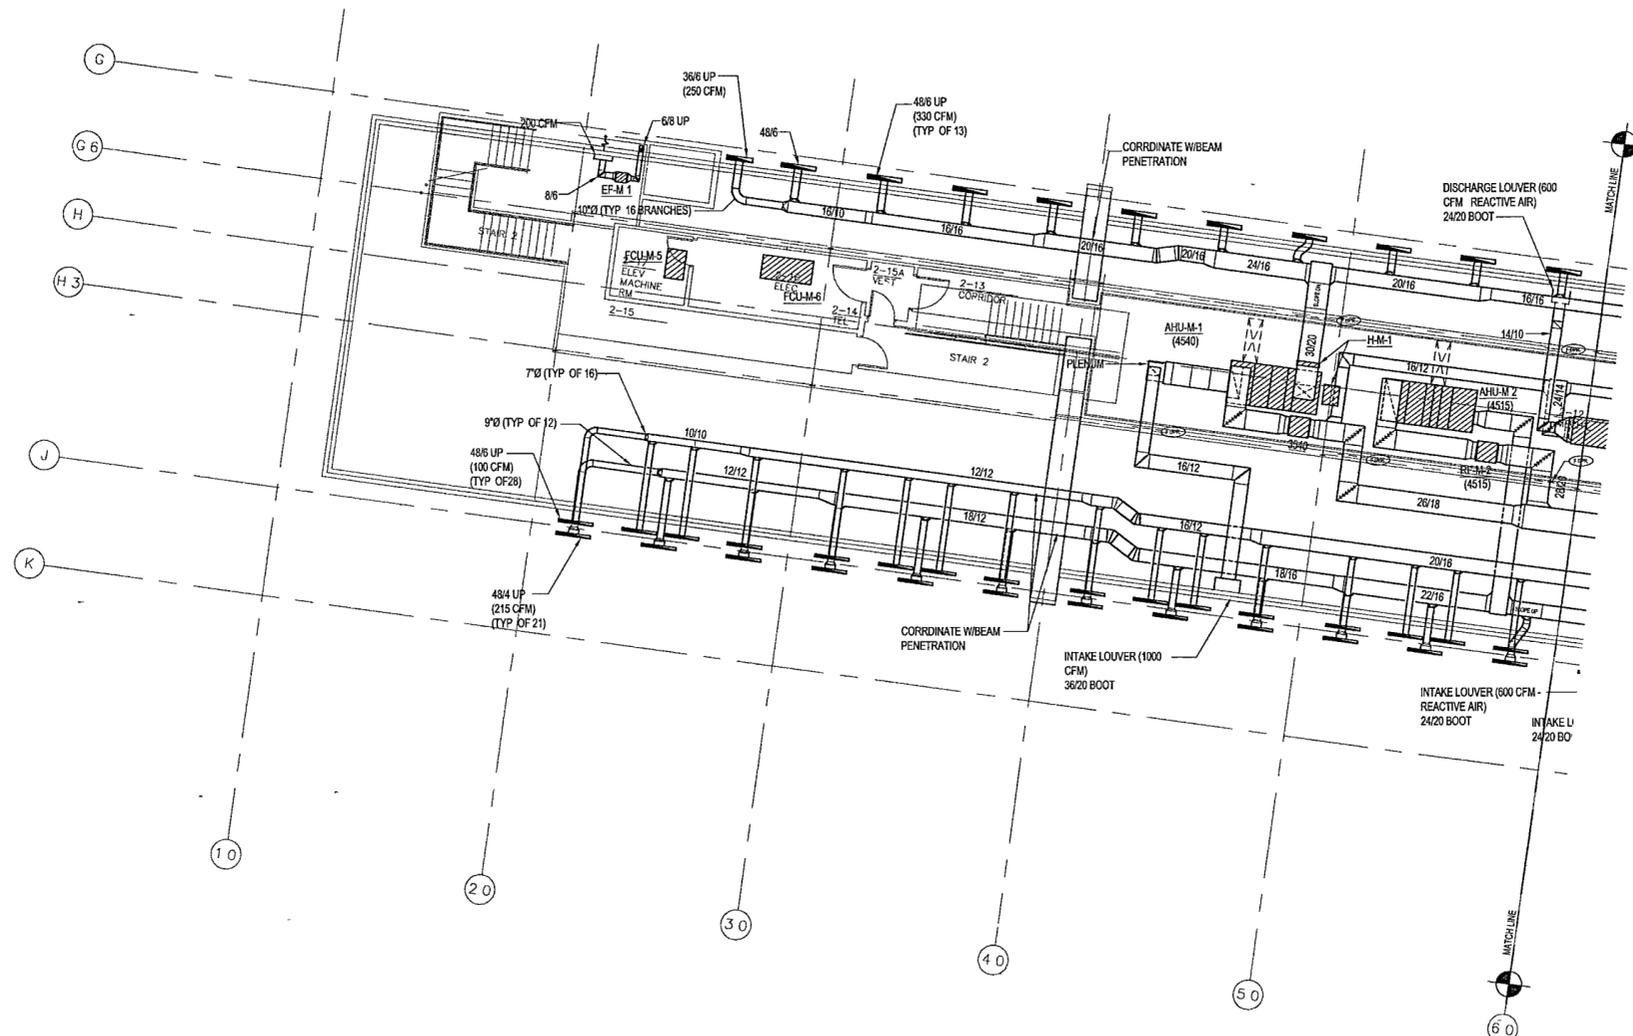

**1 MUSEUM - SECOND LEVEL MECHANICAL PLAN**  
 M302a | M302b 1/8" = 1'-0"

**WILLIAM J. CLINTON  
 PRESIDENTIAL  
 CENTER**

LITTLE ROCK, ARKANSAS

Architect  
 POLSHEK PARTNERSHIP LLP  
 320 West 13th Street  
 New York, New York 10014  
 212 607 7171

Coordinating Architects  
 POLK STANLEY YEARY ARCHITECTS LM  
 700 South Salaker Street  
 Little Rock, Arkansas 72201  
 501 378 0878

WITSELL EVANS PASCO  
 901 West Third Street  
 Little Rock, Arkansas 72201  
 501 374 5300

WOODS CARADINE ARCHITECTS  
 2200 South Main Street  
 Little Rock, Arkansas 72206  
 501 374 4060

Landscape Architects  
 HARGREAVES ASSOCIATES  
 118 Magazine Street  
 Cambridge, Massachusetts 02139  
 617 661 0070

LANDSCAPE ARCHITECTURE, Inc.  
 2300 Cottondale Lane Suite 202  
 Little Rock, Arkansas 72202  
 501.374.5510

Structural Engineer  
 LESLIE E. ROBERTSON ASSOC. RLP  
 30 Broad Street, 47th Floor  
 New York, New York 10004  
 212 750 9000


MEP Engineers  
 FLACK + KURTZ Inc.  
 475 Fifth Avenue  
 New York, New York 10017  
 212.532.9600

CROMWELL ARCHITECTS ENGINEERS  
 101 South Spring Street  
 Little Rock, Arkansas 72201  
 501.372.2900

Curtainwall Consultant  
 R. A. HEINTGES ARCHITECTS  
 125 Fifth Avenue, 9th Floor  
 New York, New York 10011  
 212 652-2966



Issue	Date
100% Construction Documents	09/27/02
90% Progress Printing	09/20/02
100% Design Development	03/01/02

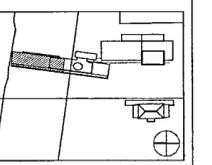

Job No: POLSHEK & PARTNERS ARCH. 9908  
 CROMWELL AE 99-114  
 Scale: 1/8" = 1'-0"  
 Date: SEPTEMBER 27, 2002

Title: **MUSEUM  
 SECOND LEVEL  
 MECHANICAL  
 PARTIAL PLAN**

Sheet No: **M302a**



**FOR OFFICIAL USE ONLY**