


- GENERAL NOTES:**
- BEFORE INSTALLATION OF ANY DUCTWORK, THE CONTRACTOR SHALL COORDINATE ALL PLUMBING, FIRE PROTECTION, AND DUCTWORK ROUTING.
  - REFER TO THE ARCHITECTURAL REFLECTED CEILING PLANS AND ELEVATIONS FOR EXACT LOCATION OF AIR DEVICES AND LOUVERS.
  - ALL SUPPLY AND RETURN BRANCHES TO AND FROM AIR DEVICES IN AREAS WITH LAY IN CEILING SHALL BE PROVIDED WITH A VOLUME DAMPER AT THE MAIN DUCT.
  - PROVIDE 5'-0" MAXIMUM FLEX DUCT AT AIR DEVICES.
  - VERIFY ROOM SENSOR (THERMOSTAT) LOCATIONS WITH THE CONSTRUCTION MANAGER.
  - COORDINATE LOCATION OF CONDUITS IN BLOCK WALLS FOR ROOM SENSORS WITH CONSTRUCTION MANAGER. SURFACE MOUNTED CONDUIT IS NOT ALLOWED.
  - PROVIDE DYNAMIC FIRE DAMPERS OF PROPER RATING AT ALL DUCT PENETRATIONS THROUGH RATED WALLS.
  - PROVIDE ACCESS DOORS IN DRYWALL CEILINGS AS REQUIRED TO PROVIDE ACCESS FOR MAINTENANCE TO VALVES, DAMPERS, FIRE DAMPERS, ETC.

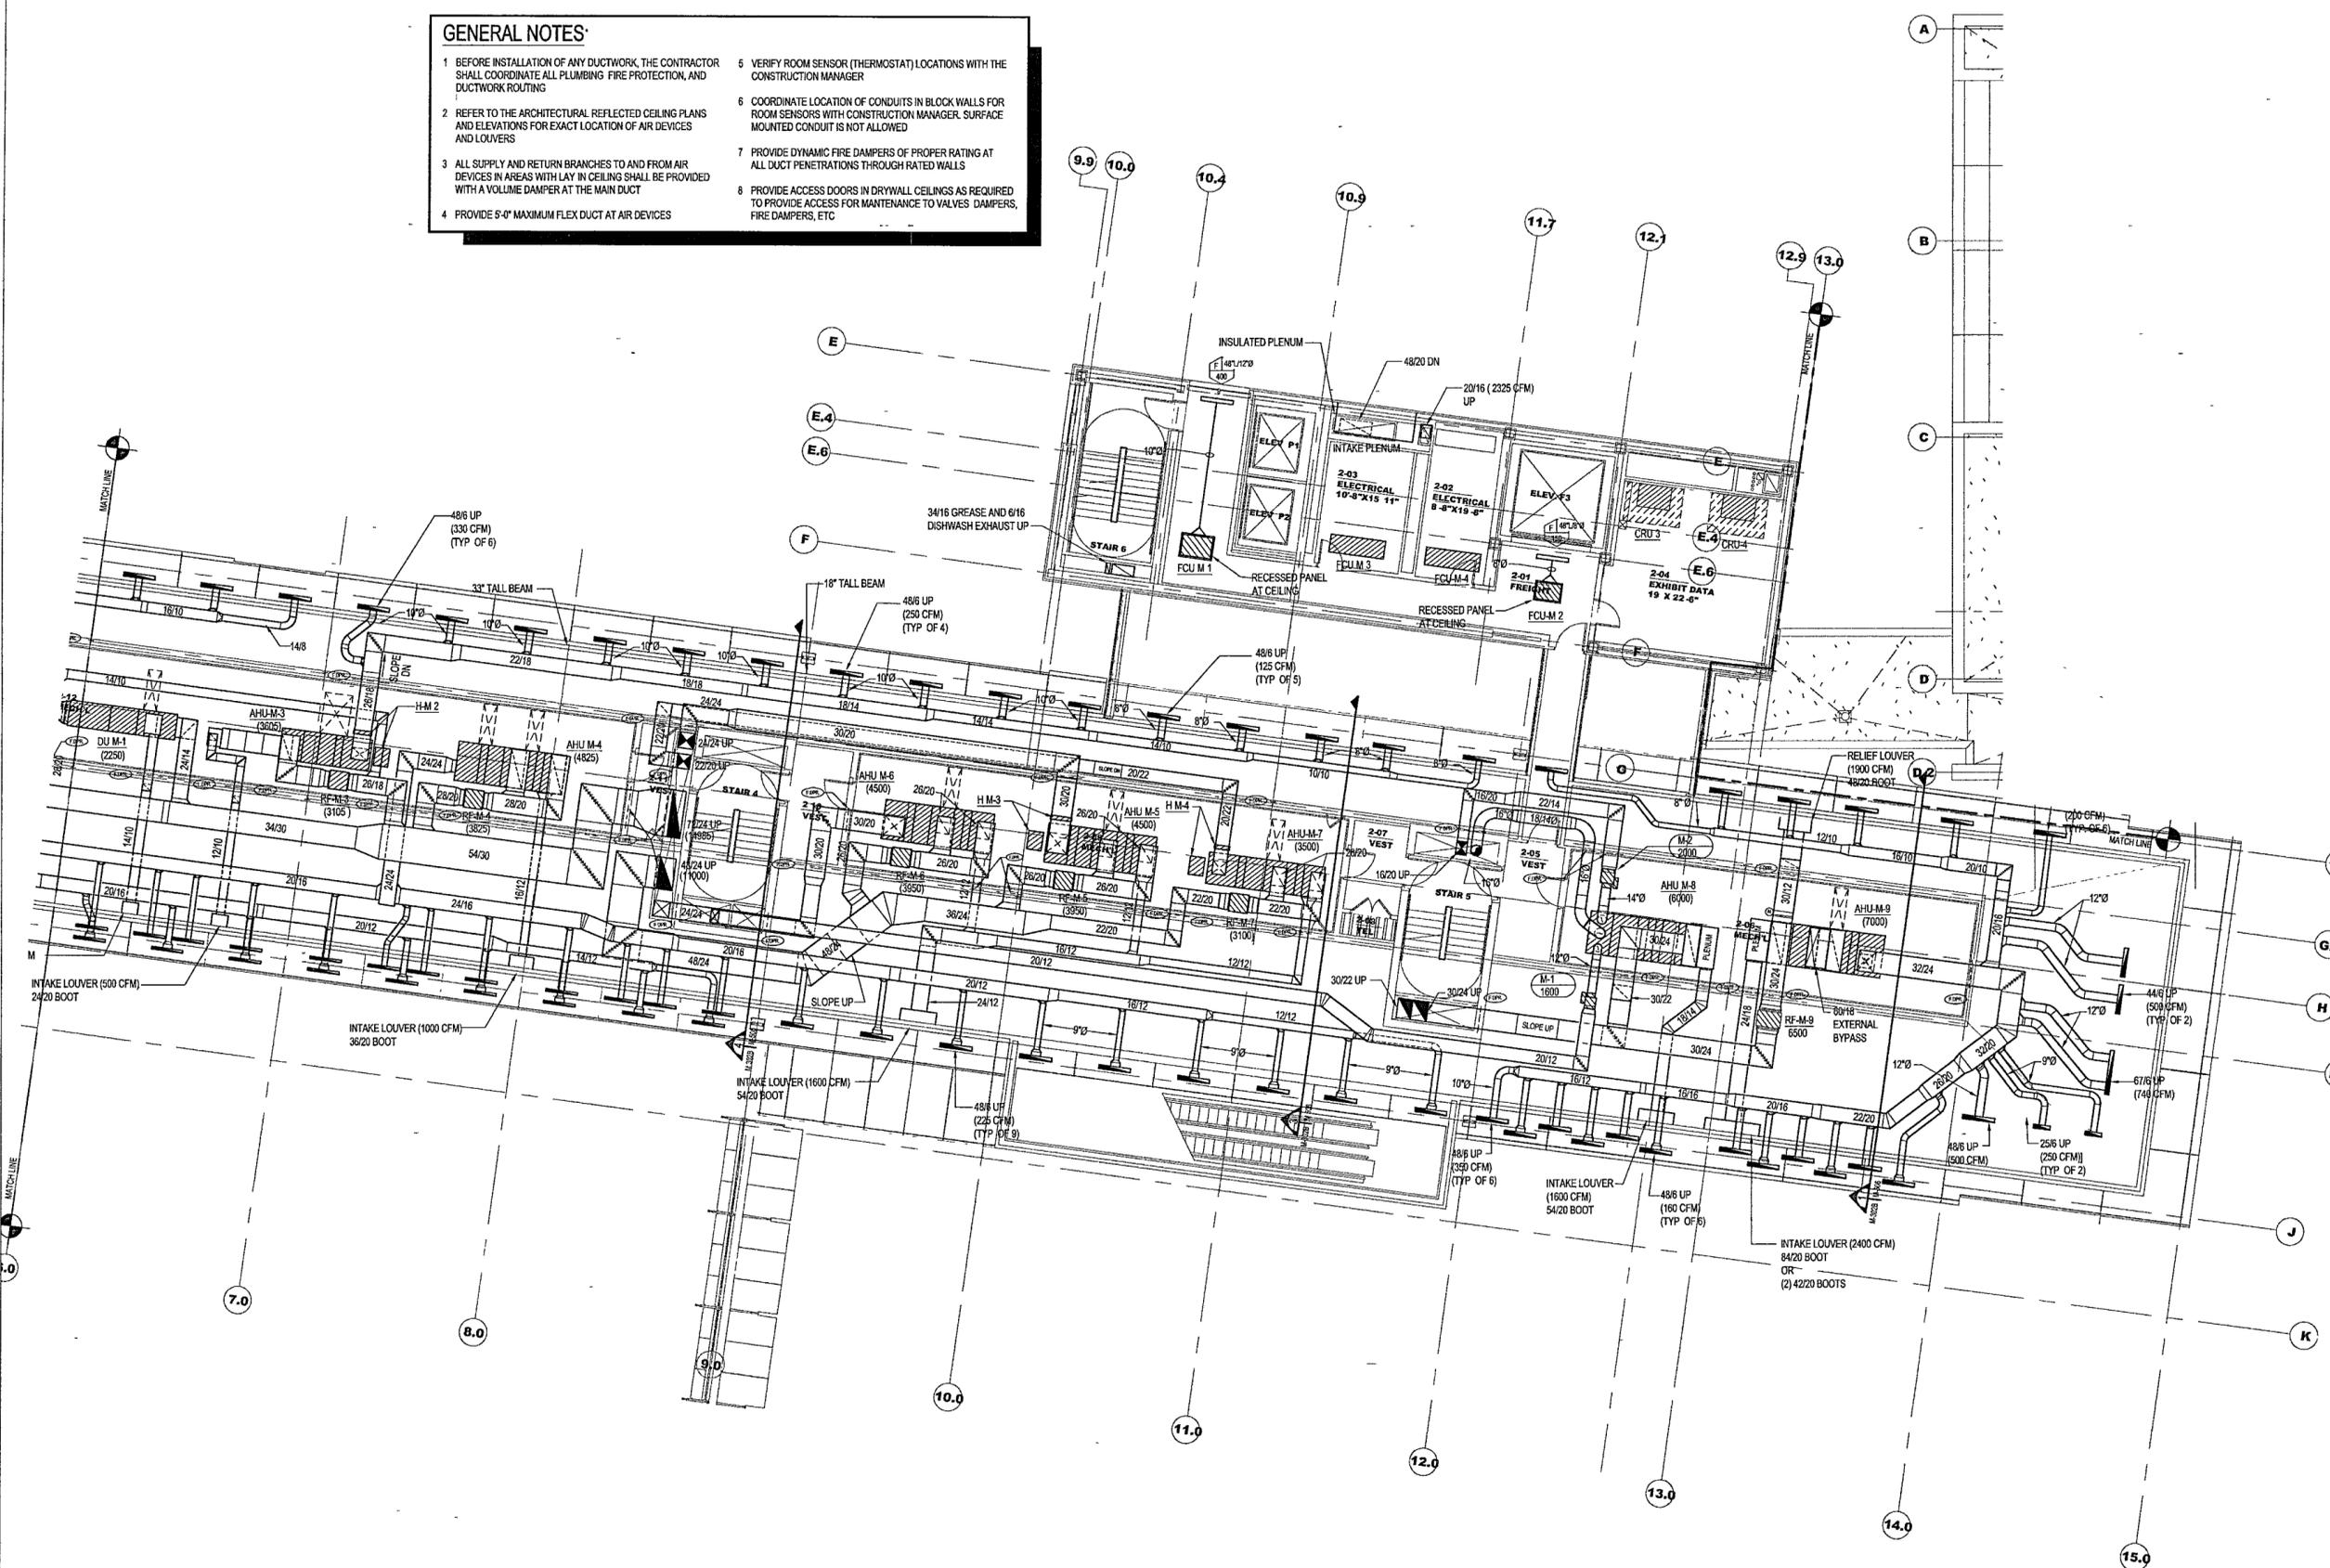

**1 MUSEUM - SECOND LEVEL MECHANICAL PLAN**  
 M302b | M302c 1/8" = 1'-0" NORTH

**WILLIAM J CLINTON  
PRESIDENTIAL  
CENTER**

LITTLE ROCK, ARKANSAS

Architect  
 POLSHEK PARTNERSHIP LLP  
 320 West 13th Street  
 New York, New York 10014  
 212.807.7171

Coordinating Architects  
 POLK STANLEY YEARY ARCHITECTS, Ltd  
 700 South Sculler Street  
 Little Rock, Arkansas 72201  
 501.378.0878

WITSELL EVANS PASCO  
 901 West Third Street  
 Little Rock, Arkansas 72201  
 501.374.5300

WOODS CARADINE ARCHITECTS  
 2200 South Main Street  
 Little Rock, Arkansas 72206  
 501.374.4066

Landscape Architects  
 HARGREAVES ASSOCIATES  
 118 Magazine Street  
 Cambridge, Massachusetts 02139  
 617.661.0070

LANDSCAPE ARCHITECTURE, Inc.  
 2300 Cottondale Lane Suite 202  
 Little Rock, Arkansas 72202  
 501.374.5610

Structural Engineer  
 LESLIE E. ROBERTSON ASSOC. R.L.P.  
 30 Broad Street, 4th Floor  
 New York, New York 10004  
 212.532.9000

MEP Engineers  
 FLACK + KURTZ Inc.  
 475 Fifth Avenue  
 New York, New York 10017  
 212.532.9600

CROMWELL ARCHITECTS ENGINEERS  
 101 South Spring Street  
 Little Rock, Arkansas 72201  
 501.372.2900

Curtilage Consultant  
 R. A. HEINTGES ARCHITECTS  
 126 Fifth Avenue 9th Floor  
 New York, New York 10011  
 212.652.2956

Soil

STATE OF ARKANSAS  
 REGISTERED PROFESSIONAL ENGINEER  
 No. 9395  
 WILLIAM J. CLINTON

100% Construction Documents	09/27/02
90% Progress Printing	09/20/02
100% Design Development	03/14/02
Issue	Date

Job No: POLSHEK & PARTNERS ARCH. 9908  
 CROMWELL AE 99-114

Scale: 1/8" = 1'-0"

Date: SEPTEMBER 27, 2002

Title: MUSEUM SECOND LEVEL MECHANICAL PARTIAL PLAN

Sheet No. **M302b**

FOR OFFICIAL USE ONLY