


**GENERAL NOTES:**

- BEFORE INSTALLATION OF ANY DUCTWORK, THE CONTRACTOR SHALL COORDINATE ALL PLUMBING, FIRE PROTECTION, AND DUCTWORK ROUTING
- REFER TO THE ARCHITECTURAL REFLECTED CEILING PLANS AND ELEVATIONS FOR EXACT LOCATION OF AIR DEVICES AND LOUVERS
- ALL SUPPLY AND RETURN BRANCHES TO AND FROM AIR DEVICES IN AREAS WITH LAY-IN CEILING SHALL BE PROVIDED WITH A VOLUME DAMPER AT THE MAIN DUCT
- PROVIDE 5'-0" MAXIMUM FLEX DUCT AT AIR DEVICES
- VERIFY ROOM SENSOR (THERMOSTAT) LOCATIONS WITH THE CONSTRUCTION MANAGER.
- COORDINATE LOCATION OF CONDUITS IN BLOCK WALLS FOR ROOM SENSORS WITH CONSTRUCTION MANAGER. SURFACE MOUNTED CONDUIT IS NOT ALLOWED
- PROVIDE DYNAMIC FIRE DAMPERS OF PROPER RATING AT ALL DUCT PENETRATIONS THROUGH RATED WALLS
- PROVIDE ACCESS DOORS IN DRYWALL CEILINGS AS REQUIRED TO PROVIDE ACCESS FOR MAINTENANCE TO VALVES, DAMPERS, FIRE DAMPERS, ETC

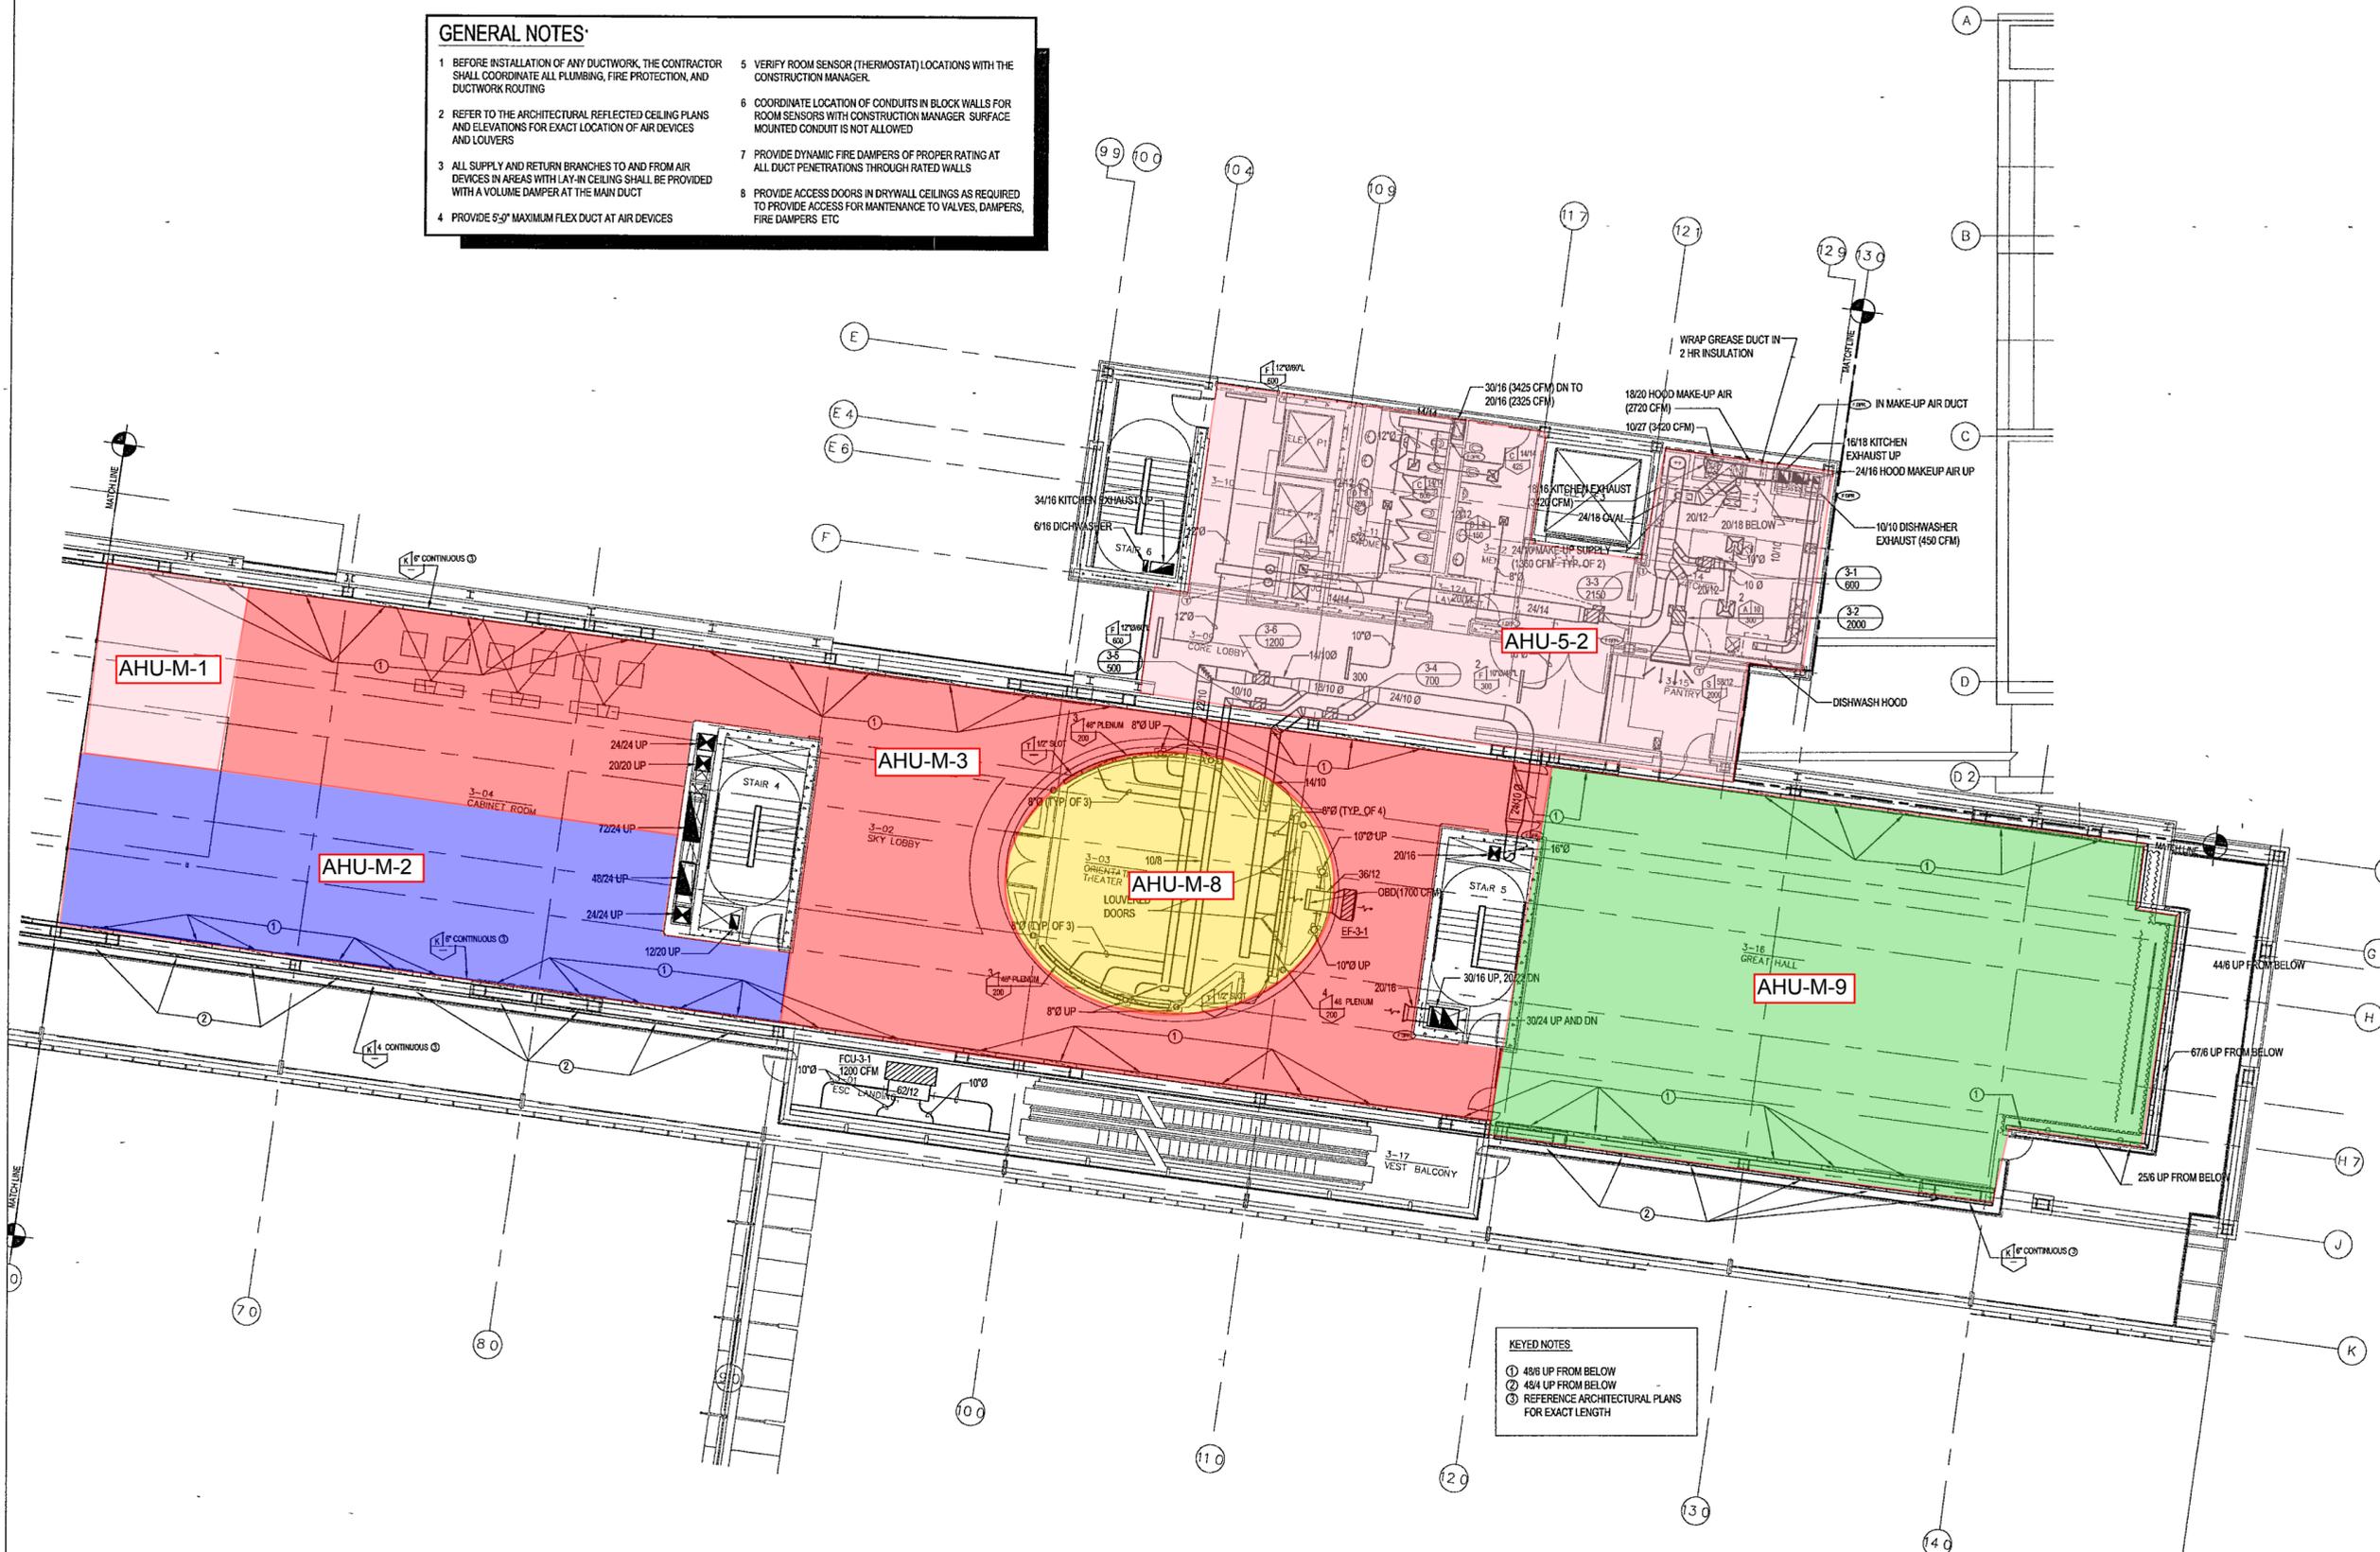

**KEYED NOTES:**  
 ① 4816 UP FROM BELOW  
 ② 4814 UP FROM BELOW  
 ③ REFERENCE ARCHITECTURAL PLANS FOR EXACT LENGTH

**1 MUSEUM - LOWER LEVEL MECHANICAL PARTIAL PLAN**  
 M303b | M303b 1/8" = 1'-0" NORTH

**WILLIAM J. CLINTON  
 PRESIDENTIAL  
 CENTER**

LITTLE ROCK, ARKANSAS

**Architect**  
 POLSHEK PARTNERSHIP LLP  
 320 West 13th Street  
 New York, New York 10014  
 212 607 7171

**Coordinating Architects**  
 POLK STANLEY YEARY ARCHITECTS Ltd  
 700 South Schuler Street  
 Little Rock, Arkansas 72201  
 501.378.0878

**WITSELL EVANS RASCO**  
 901 West Third Street  
 Little Rock, Arkansas 72201  
 501.374.5300

**WOODS CARADINE ARCHITECTS**  
 2200 South Main Street  
 Little Rock, Arkansas 72206  
 501.374.4060

**Landscape Architects**  
 HARGREAVES ASSOCIATES  
 118 Magazine Street  
 Cambridge, Massachusetts 02139  
 617.661.0070

**LANDSCAPE ARCHITECTURE Inc.**  
 2300 Cotuit Lane Suite 202  
 Little Rock, Arkansas 72202  
 501.374.5610

**Structural Engineer**  
 LESLIE E. ROBERTSON ASSOC. RLLP  
 30 Broad Street 4th Floor  
 New York, New York 10004  
 212.750.9000


**MEP Engineers**  
 FLACK + KURTZ Inc  
 475 10th Avenue  
 New York, New York 10017  
 212.532.9600

**CROMWELL ARCHITECTS ENGINEERS**  
 101 South Spring Street  
 Little Rock, Arkansas 72201  
 501.372.2900

**Curtilwall Consultant**  
 R. A. HEINTGES ARCHITECTS  
 126 Fifth Avenue, 9th Floor  
 New York, New York 10011  
 212.652.2966



Issue	Date
100% Construction Documents	09/27/02
90% Progress Printing	08/30/02
100% Design Development	03/01/02

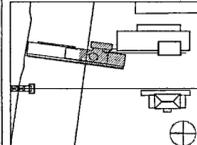

Job No: POLSHEK & PARTNERS ARCH. 9908  
 CROMWELL AE 99-114  
 Scale: 1/8" = 1'-0"  
 Date: SEPTEMBER 27, 2002

Title: **MUSEUM  
 LOWER LEVEL  
 MECHANICAL  
 PARTIAL PLAN**

Sheet No. **M303b**



**FOR OFFICIAL USE ONLY**