


**GENERAL NOTES**

- BEFORE INSTALLATION OF ANY DUCTWORK THE CONTRACTOR SHALL COORDINATE ALL PLUMBING FIRE PROTECTION, AND DUCTWORK ROUTING
- REFER TO THE ARCHITECTURAL REFLECTED CEILING PLANS AND ELEVATIONS FOR EXACT LOCATION OF AIR DEVICES AND LOUVERS
- ALL SUPPLY AND RETURN BRANCHES TO AND FROM AIR DEVICES IN AREAS WITH HANGING CEILING SHALL BE PROVIDED WITH A VOLUME DAMPER AT THE MAIN DUCT
- PROVIDE 5'-0" MAXIMUM FLEX DUCT AT AIR DEVICES
- VERIFY ROOM SENSOR (THERMOSTAT) LOCATIONS WITH THE CONSTRUCTION MANAGER
- COORDINATE LOCATION OF CONDUITS IN BLOCK WALLS FOR ROOM SENSORS WITH CONSTRUCTION MANAGER. SURFACE MOUNTED CONDUIT IS NOT ALLOWED
- PROVIDE DYNAMIC FIRE DAMPERS OF PROPER RATING AT ALL DUCT PENETRATIONS THROUGH RATED WALLS
- PROVIDE ACCESS DOORS IN DRYWALL CEILINGS AS REQUIRED TO PROVIDE ACCESS FOR MAINTENANCE TO VALVES, DAMPERS FIRE DAMPERS, ETC

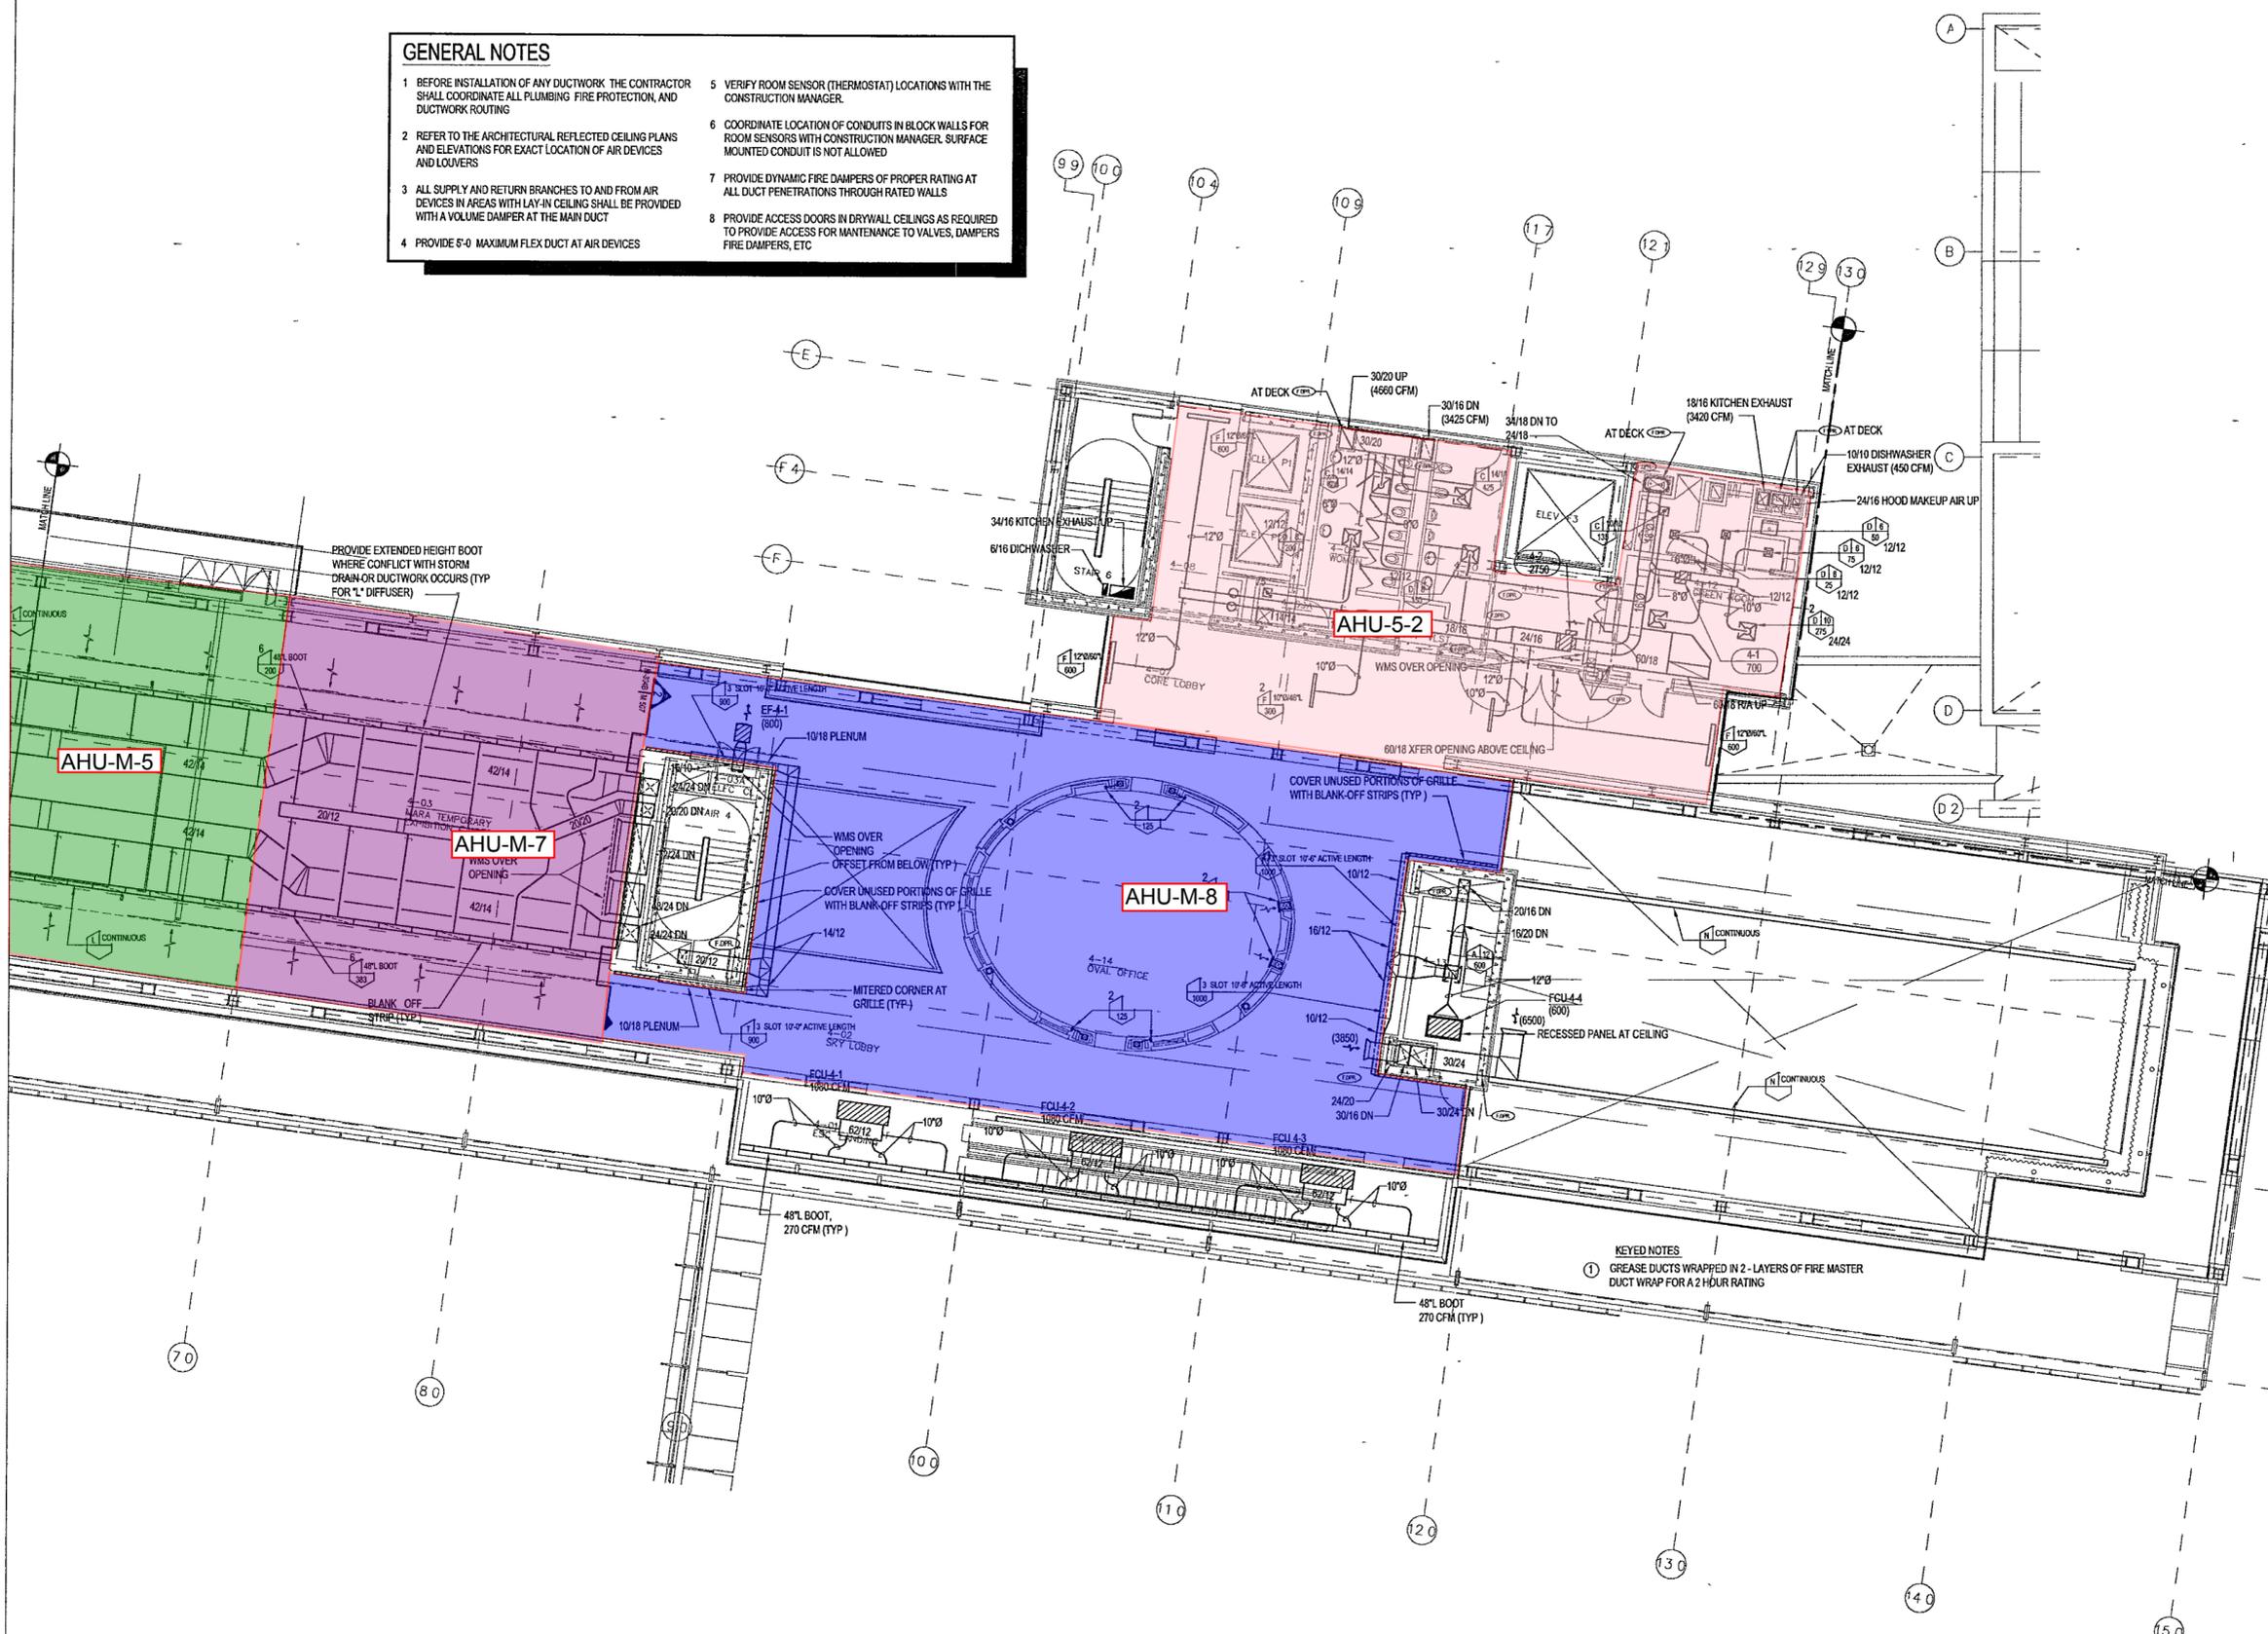

**1 MUSEUM - UPPER LEVEL MECHANICAL PLAN**  
 M304b | M304b 1/8" = 1'-0"

**WILLIAM J. CLINTON  
 PRESIDENTIAL  
 CENTER**

LITTLE ROCK, ARKANSAS  
 Architect  
 POLSHEK PARTNERSHIP LLP  
 320 West 13th Street  
 New York, New York 10014  
 212.207.7171

Coordinating Architects  
 POLK STANLEY YEARY ARCHITECTS Ltd  
 700 South Schiller Street  
 Little Rock, Arkansas 72201  
 501.378.0878

WITSSELL EVANS RASCO  
 501 West Third Street  
 Little Rock, Arkansas 72201  
 501.374.6300

WOODS CADARINE ARCHITECTS  
 2209 South Main Street  
 Little Rock, Arkansas 72206  
 501.374.4060

Landscape Architects  
 HARGREAVES ASSOCIATES  
 118 Magazine Street  
 Cambridge, Massachusetts 02139  
 617.661.0070

LANDSCAPE ARCHITECTURE, Inc.  
 2300 Cottondale Lane Suite 202  
 Little Rock, Arkansas 72202  
 501.374.5610

Structural Engineer  
 LESLIE E. ROBERTSON ASSOC. RLLP  
 30 Broad Street 4th Floor  
 New York, New York 10004  
 212.750.9000


MEP Engineers  
 FLACK + KURTZ Inc.  
 475 Fifth Avenue  
 New York, New York 10017  
 212.532.9600

CROMWELL ARCHITECTS ENGINEERS  
 101 South Spring Street  
 Little Rock, Arkansas 72201  
 501.372.2300

Curtilwall Consultant  
 R. A. HENTGES ARCHITECTS  
 126 Fifth Avenue 9th Floor  
 New York, New York 10011  
 212.652.2666



| Issue                       | Date     |
|-----------------------------|----------|
| 100% Construction Documents | 09/27/02 |
| 90% Progress Printing       | 08/20/02 |
| 100% Design Development     | 03/01/02 |

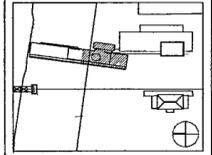

Job No: POLSHEK & PARTNERS ARCH 9908  
 CROMWELL AE 99-114  
 Scale: 1/8" = 1'-0"  
 Date: SEPTEMBER 27 2002

Title: **MUSEUM  
 UPPER LEVEL  
 MECHANICAL  
 PARTIAL PLAN**

Sheet No: **M304b**



**FOR OFFICIAL USE ONLY**