

GENERAL NOTES.

- BEFORE INSTALLATION OF ANY PIPING THE CONTRACTOR SHALL COORDINATE ALL PLUMBING, FIRE PROTECTION, AND DUCTWORK ROUTING
- PROVIDE ACCESS DOORS IN DRYWALL CEILINGS AS REQUIRED TO PROVIDE ACCESS FOR MAINTENANCE TO VALVES, ETC

**WILLIAM J CLINTON
PRESIDENTIAL
CENTER**

LITTLE ROCK, ARKANSAS

Architect
POLSHKE PARTNERSHIP LLP
320 West 13th Street
New York, New York 10014
212.607.7171

Coordinating Architects
POLK STANLEY YEARY ARCHITECTS Ltd
700 South Schiller Street
Little Rock, Arkansas 72201
501.378.0878

WITSELL EVANS RASCO
901 West Third Street
Little Rock, Arkansas 72201
501.374.5300

WOODS CARADINE ARCHITECTS
2200 South Main Street
Little Rock, Arkansas 72206
501.374.4060

Landscape Architects
HARGREAVES ASSOCIATES
118 Magazine Street
Cambridge, Massachusetts 02139
617.661.0070


LANDSCAPE ARCHITECTURE, Inc.
2300 Cotterdam Lane Suite 202
Little Rock, Arkansas 72202
501.374.5610

Structural Engineer
LESLIE E. ROBERTSON ASSOC. RLLP
30 Broad Street, 4th Floor
New York, New York 10004
212.750.9300

MEP Engineers
FLACK + KURTZ Inc.
475 Fifth Avenue
New York, New York 10017
212.532.9600

CROMMELL ARCHITECTS ENGINEERS
101 South Spring Street
Little Rock, Arkansas 72201
501.372.2900

Curtainwall Consultant
R. A. HEINTGES ARCHITECTS
126 Fifth Avenue, 9th Floor
New York, New York 10011
212.652.2965

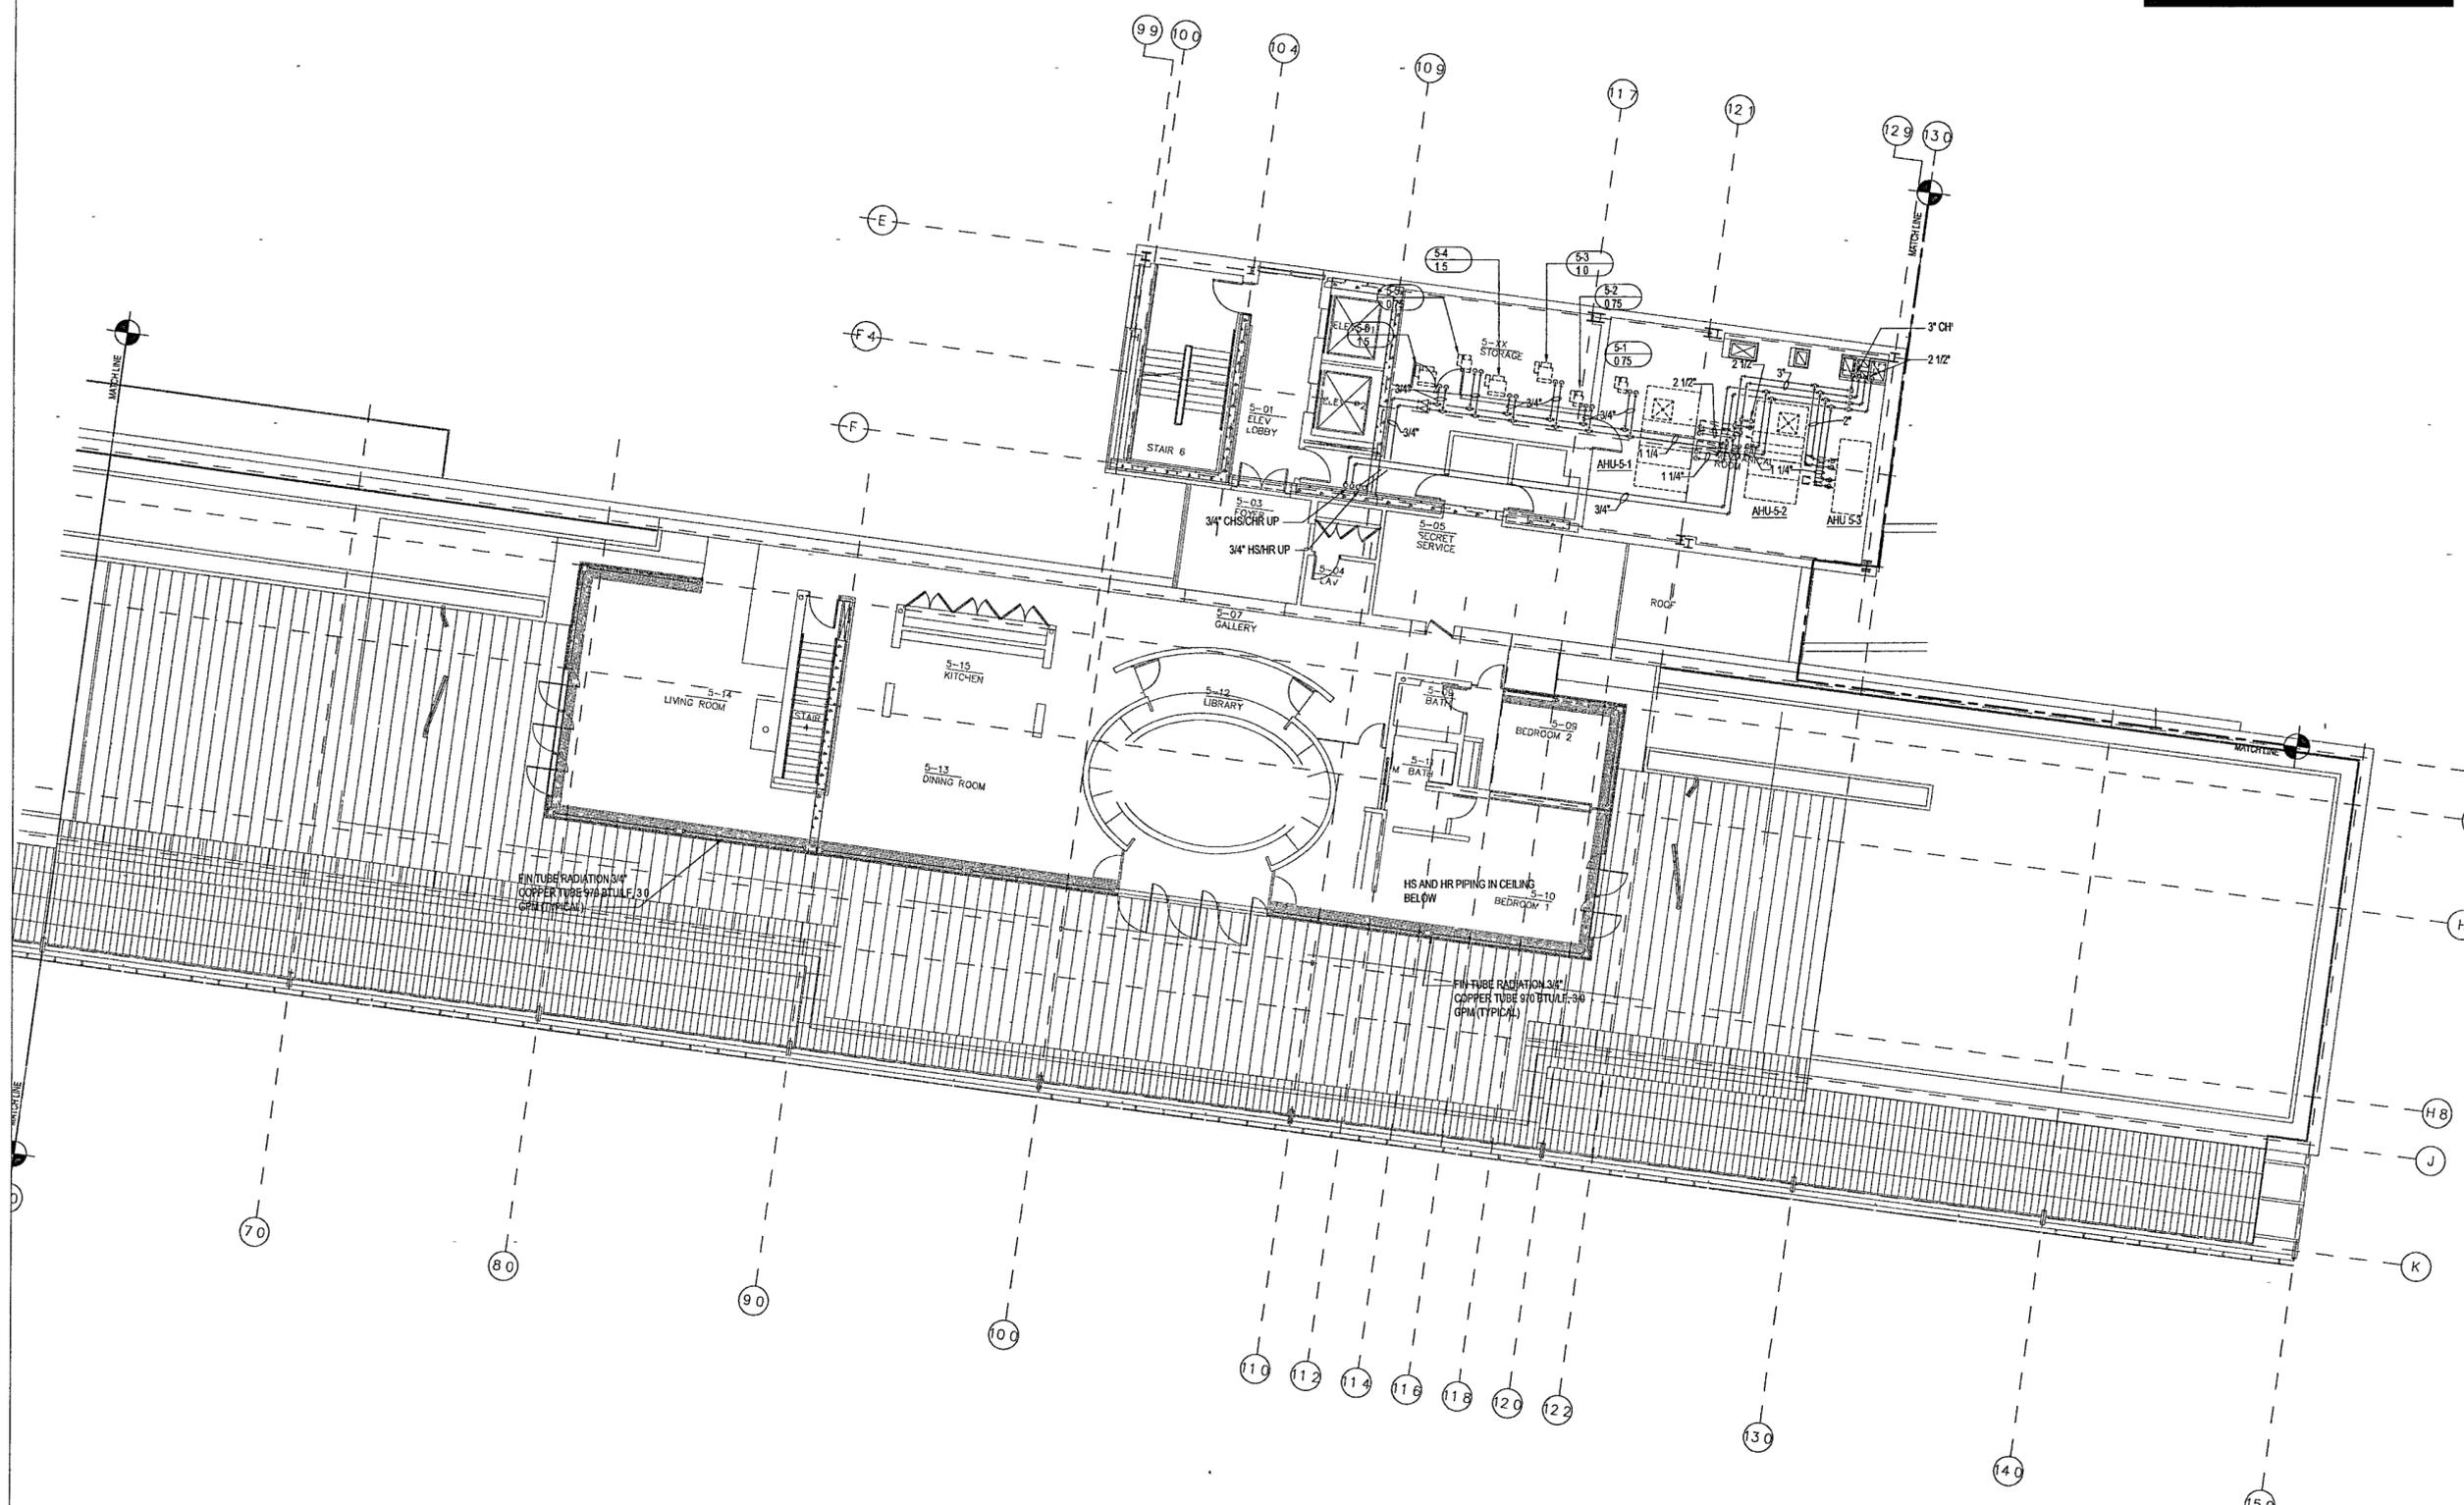


1 MUSEUM ROOF/EXECUTIVE LEVEL - MECHANICAL PIPING PLAN

M405b | M405b 1/8" = 1'-0"



100% Construction Documents	09/27/02
92% Progress Piping	08/30/02
Issue	Date

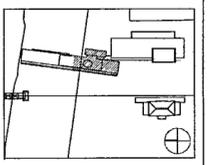

Job No POLSHEK & PARTNERS ARCH 9908
CROMMELL AE 99-114

Scale 1/8" = 1'-0"

Date SEPTEMBER 27, 2002

Title **MUSEUM ROOF/
EXECUTIVE LEVEL
MECHANICAL
PARTIAL PIPING PLAN**

Sheet No



M405b

FOR OFFICIAL USE ONLY