

**WILLIAM J CLINTON
PRESIDENTIAL
CENTER**

LITTLE ROCK, ARKANSAS

Architect
POLSHEK PARTNERSHIP LLP
320 West 13th Street
New York, New York 10014
212 807 7171

Coordinating Architects
POLK STANLEY YEARY ARCHITECTS, Ltd
700 South Schiller Street
Little Rock, Arkansas 72201
501 378 0878

WITSELL EVANS RASCO
901 West Third Street
Little Rock, Arkansas 72201
501 374 5300

WOODS CARADINE ARCHITECTS
2200 South Main Street
Little Rock, Arkansas 72206
501 374 4060

Landscape Architects
HARGREAVES ASSOCIATES
118 Magazine Street
Cambridge, Massachusetts 02139
617 861 0070

LANDSCAPE ARCHITECTURE, Inc
2300 Cottondale Lane Suite 202
Little Rock, Arkansas 72202
501 374 5910

Structural Engineer
LESLIE E. ROBERTSON ASSOC RLP
36 Broad Street, 4th Floor
New York, New York 10004
212 750 9000

MEP Engineers
FLACK + KURTZ Inc.
475 Fifth Avenue
New York, New York 10017
212 532 9600


CROMWELL ARCHITECTS ENGINEERS
101 South Spring Street
Little Rock, Arkansas 72201
501 372 2900

Curtilwall Consultant
R. A. HEINTGES ARCHITECTS
126 Fifth Avenue, 9th Floor
New York, New York 10011
212 652 2365

**100% PLUMBING
CONSTRUCTION DRAWINGS
ISSUE - JULY 1, 2002**



Issue	Date
100% Construction Documents	09/27/02
90% Progress Printing	08/30/02
General Revisions ASI #6	26 Aug 02
General Revisions ASI #3	9 Aug 02
Plumbing Contract Documents	07/01/02
100% Design Development Title as per LOT P100c	03/01/02

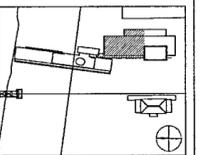

Job No POLSHEK & PARTNERS ARCH 9908
CROMWELL AE 99-114

Scale 1/8" = 1'-0"

Date JULY 01, 2002


Title **ARCHIVES
BASEMENT LEVEL
PLUMBING
PARTIAL PLAN**

Sheet No

P100c



FOR OFFICIAL USE ONLY

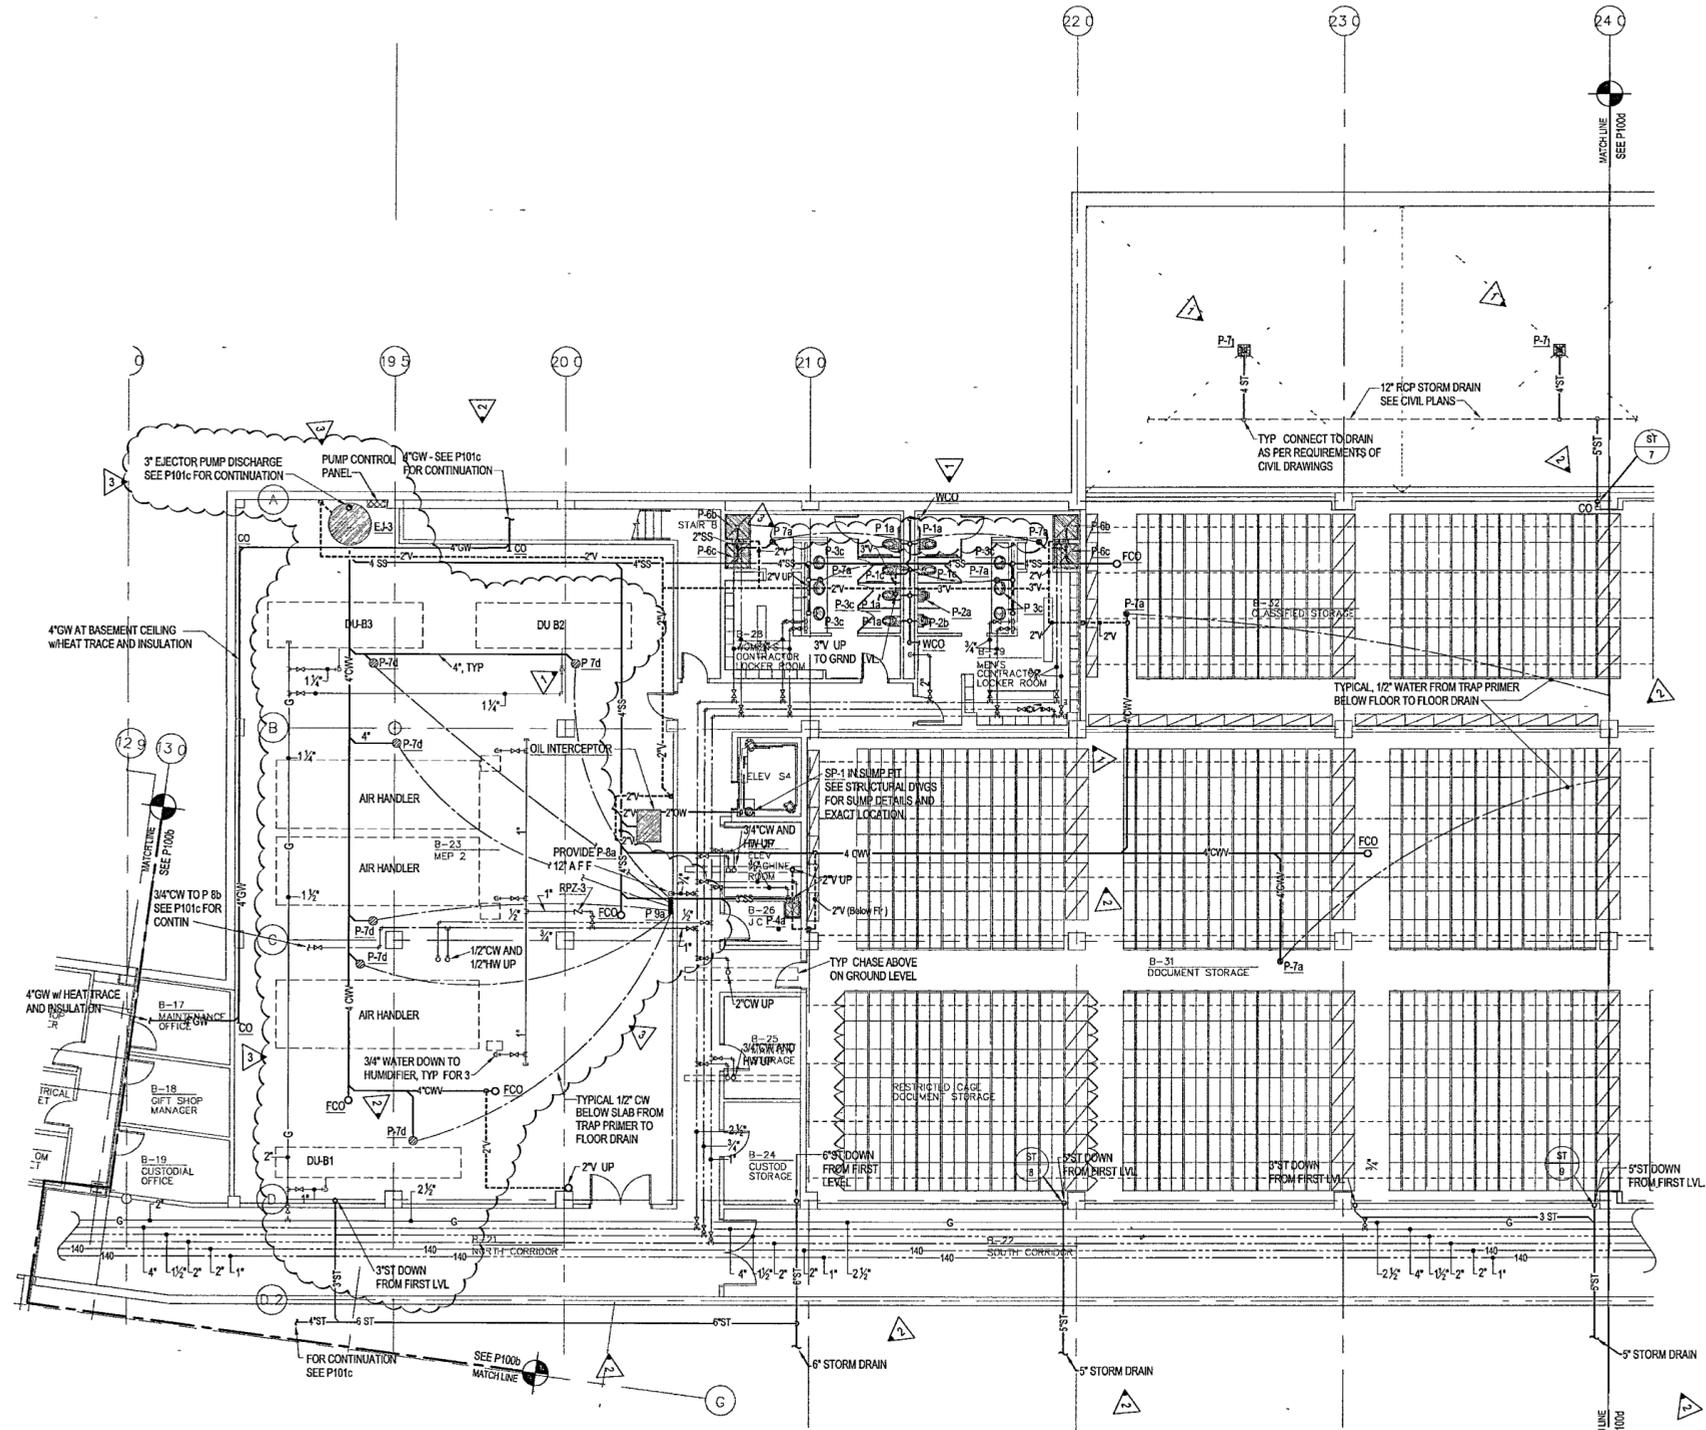

1 ARCHIVES - BASEMENT LEVEL PLUMBING PLAN
P100c | P100c 1/8" = 1'-0"

