

**WILLIAM J. CLINTON
PRESIDENTIAL
CENTER**

LITTLE ROCK, ARKANSAS

Architect
POLSHEK PARTNERSHIP LLP
320 West 13th Street
New York, New York 10014
212.807.7171

Coordinating Architects
POLK STANLEY YEARY ARCHITECTS, LPA
700 South Schiller Street
Little Rock, Arkansas 72201
501.378.0878

WITSELL EVANS RASCO
901 West Third Street
Little Rock, Arkansas 72201
501.374.5300

WOODS CARADINE ARCHITECTS
2200 South Main Street
Little Rock, Arkansas 72206
501.374.4060

Landscape Architects
HARGREAVES ASSOCIATES
118 Magazine Street
Cambridge, Massachusetts 02139
617.661.0070

LANDSCAPE ARCHITECTURE, Inc.
2300 Cottondale Lane Suite 202
Little Rock, Arkansas 72202
501.374.9510


Structural Engineer
LESLIE E. ROBERTSON ASSOC. RLP
30 Broad Street, 4th Floor
New York, New York 10004
212.750.9000

MEP Engineers
FLACK + KURTZ Inc.
475 Fifth Avenue
New York, New York 10017
212.532.9600


CROMWELL ARCHITECTS ENGINEERS
101 South Spring Street
Little Rock, Arkansas 72201
501.372.2300

Curtainwall Consultant
R. A. HEINTGES ARCHITECTS
126 Fifth Avenue, 9th Floor
New York, New York 10011
212.652.2566

**100% PLUMBING
CONSTRUCTION DRAWINGS
ISSUE - JULY 1, 2002**

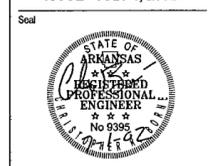

Issue	Date
100% Construction Documents	09/27/02
Revise Storm Drain ASI #7	3 Sept 02
90% Progress Printing	08/30/02
General Revisions ASI #6	26 Aug 02
General Revisions ASI #3	6 Aug 02
Plumbing Contract Documents	07/01/02
100% Design Development	03/01/02
100% Design Development	02/15/02
Issue	Date

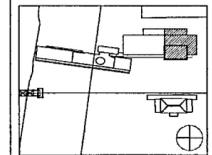

Job No: POLSHEK & PARTNERS ARCH 9908
CROMWELL AE 99-114

Scale: 1/8" = 1'-0"

Date: JULY 01, 2002


Title: **ARCHIVES
BASEMENT LEVEL
PLUMBING
PARTIAL PLAN**

Sheet No:

P100d



FOR OFFICIAL USE ONLY

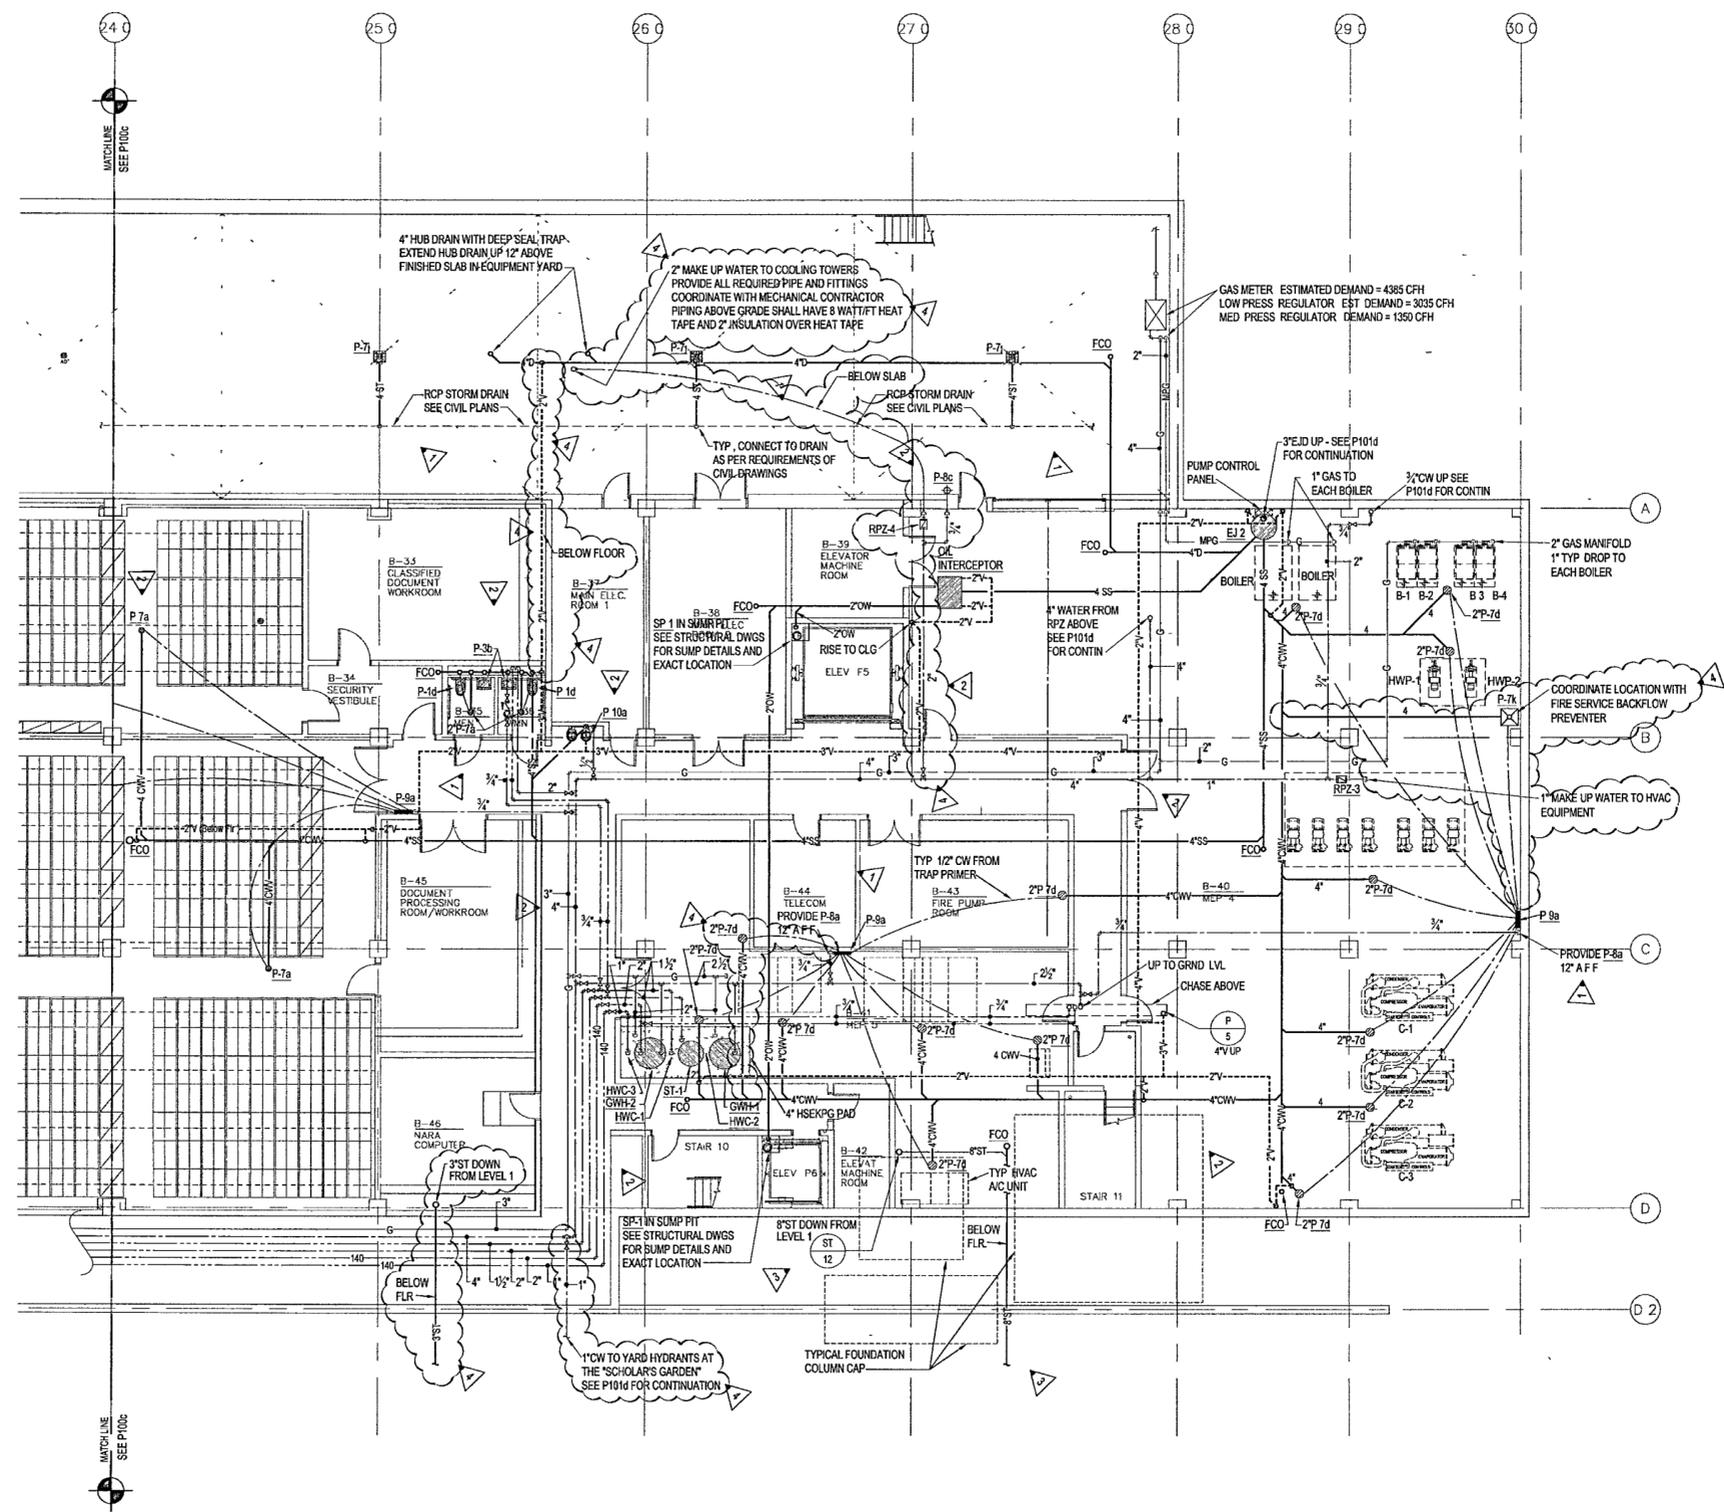

1 ARCHIVES - BASEMENT LEVEL PLUMBING PLAN
P100d | P100c 1/8" = 1'-0"



1/8/02