

LITTLE ROCK, ARKANSAS

Architect
POLSHEK PARTNERSHIP LLP
322 West 15th Street
New York, New York 10014
212.807.7171

Coordinating Architects
POLK STANLEY YEARY ARCHITECTS, Ltd
700 South Schiller Street
Little Rock, Arkansas 72201
501.378.0878

WITSELL EVANS RASCO
901 West Third Street
Little Rock, Arkansas 72201
501.374.5300

WOODS CARADINE ARCHITECTS
2200 South Main Street
Little Rock, Arkansas 72206
501.374.4060

Landscape Architects
HARGREAVES ASSOCIATES
118 Magazine Street
Cambridge, Massachusetts 02139
617.861.0070

LANDSCAPE ARCHITECTURE, Inc.
2300 Cottondale Lane Suite 202
Little Rock, Arkansas 72202
501.374.5610


Structural Engineer
LESLIE E. ROBERTSON ASSOC. R.L.P.
30 Broad Street, 4th Floor
New York, New York 10004
212.750.9000

MEP Engineers
FLACK + KURTZ Inc.
475 Fifth Avenue
New York, New York 10017
212.532.9600


CROMMELL ARCHITECTS ENGINEERS
101 South Spring Street
Little Rock, Arkansas 72201
501.372.2800

Curianwall Consultant
R. A. HEINTGES ARCHITECTS
126 Fifth Avenue, 9th Floor
New York, New York 10011
212.652.2965

**100% PLUMBING
CONSTRUCTION DRAWINGS
ISSUE - JULY 1, 2002**

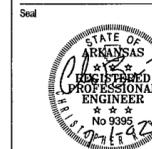

100% Construction Documents	09/27/02
90% Progress Printing	03/30/02
Revised Storm Drain	16 Aug 02
General Revisions ASI #3	9 Aug 02
Plumbing Contract Documents	07/01/02
100% Design Development	03/01/02
Issue	07/01/02

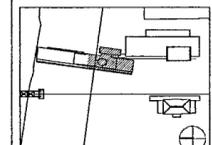

Job No: POLSHEK & PARTNERS ARCH 9908
CROMMELL AE 99-114

Scale: 1/8" = 1'-0"


Date: JULY 01, 2002

Title: **MUSEUM
GROUND LEVEL
PLUMBING
PARTIAL PLAN**


Sheet No.

P101b


FOR OFFICIAL USE ONLY

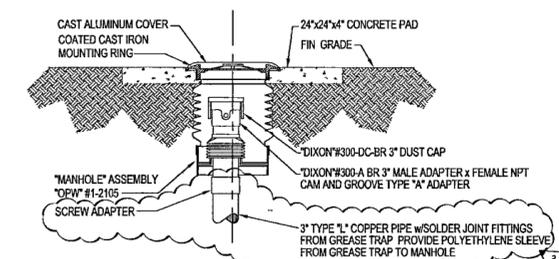

3 GREASE TRAP DRAIN CONNECTION
P101a | P101a NO SCALE

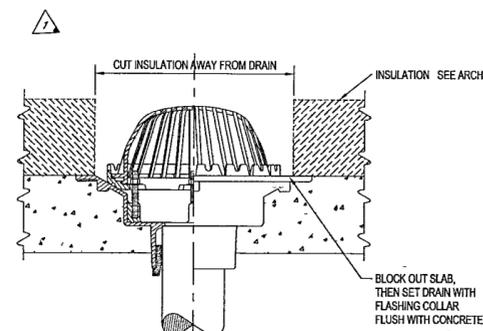

2 AREA DRAIN RDr INSTALLATION
P101b | P101b NO SCALE
RDr INSTALLATION SIMILAR

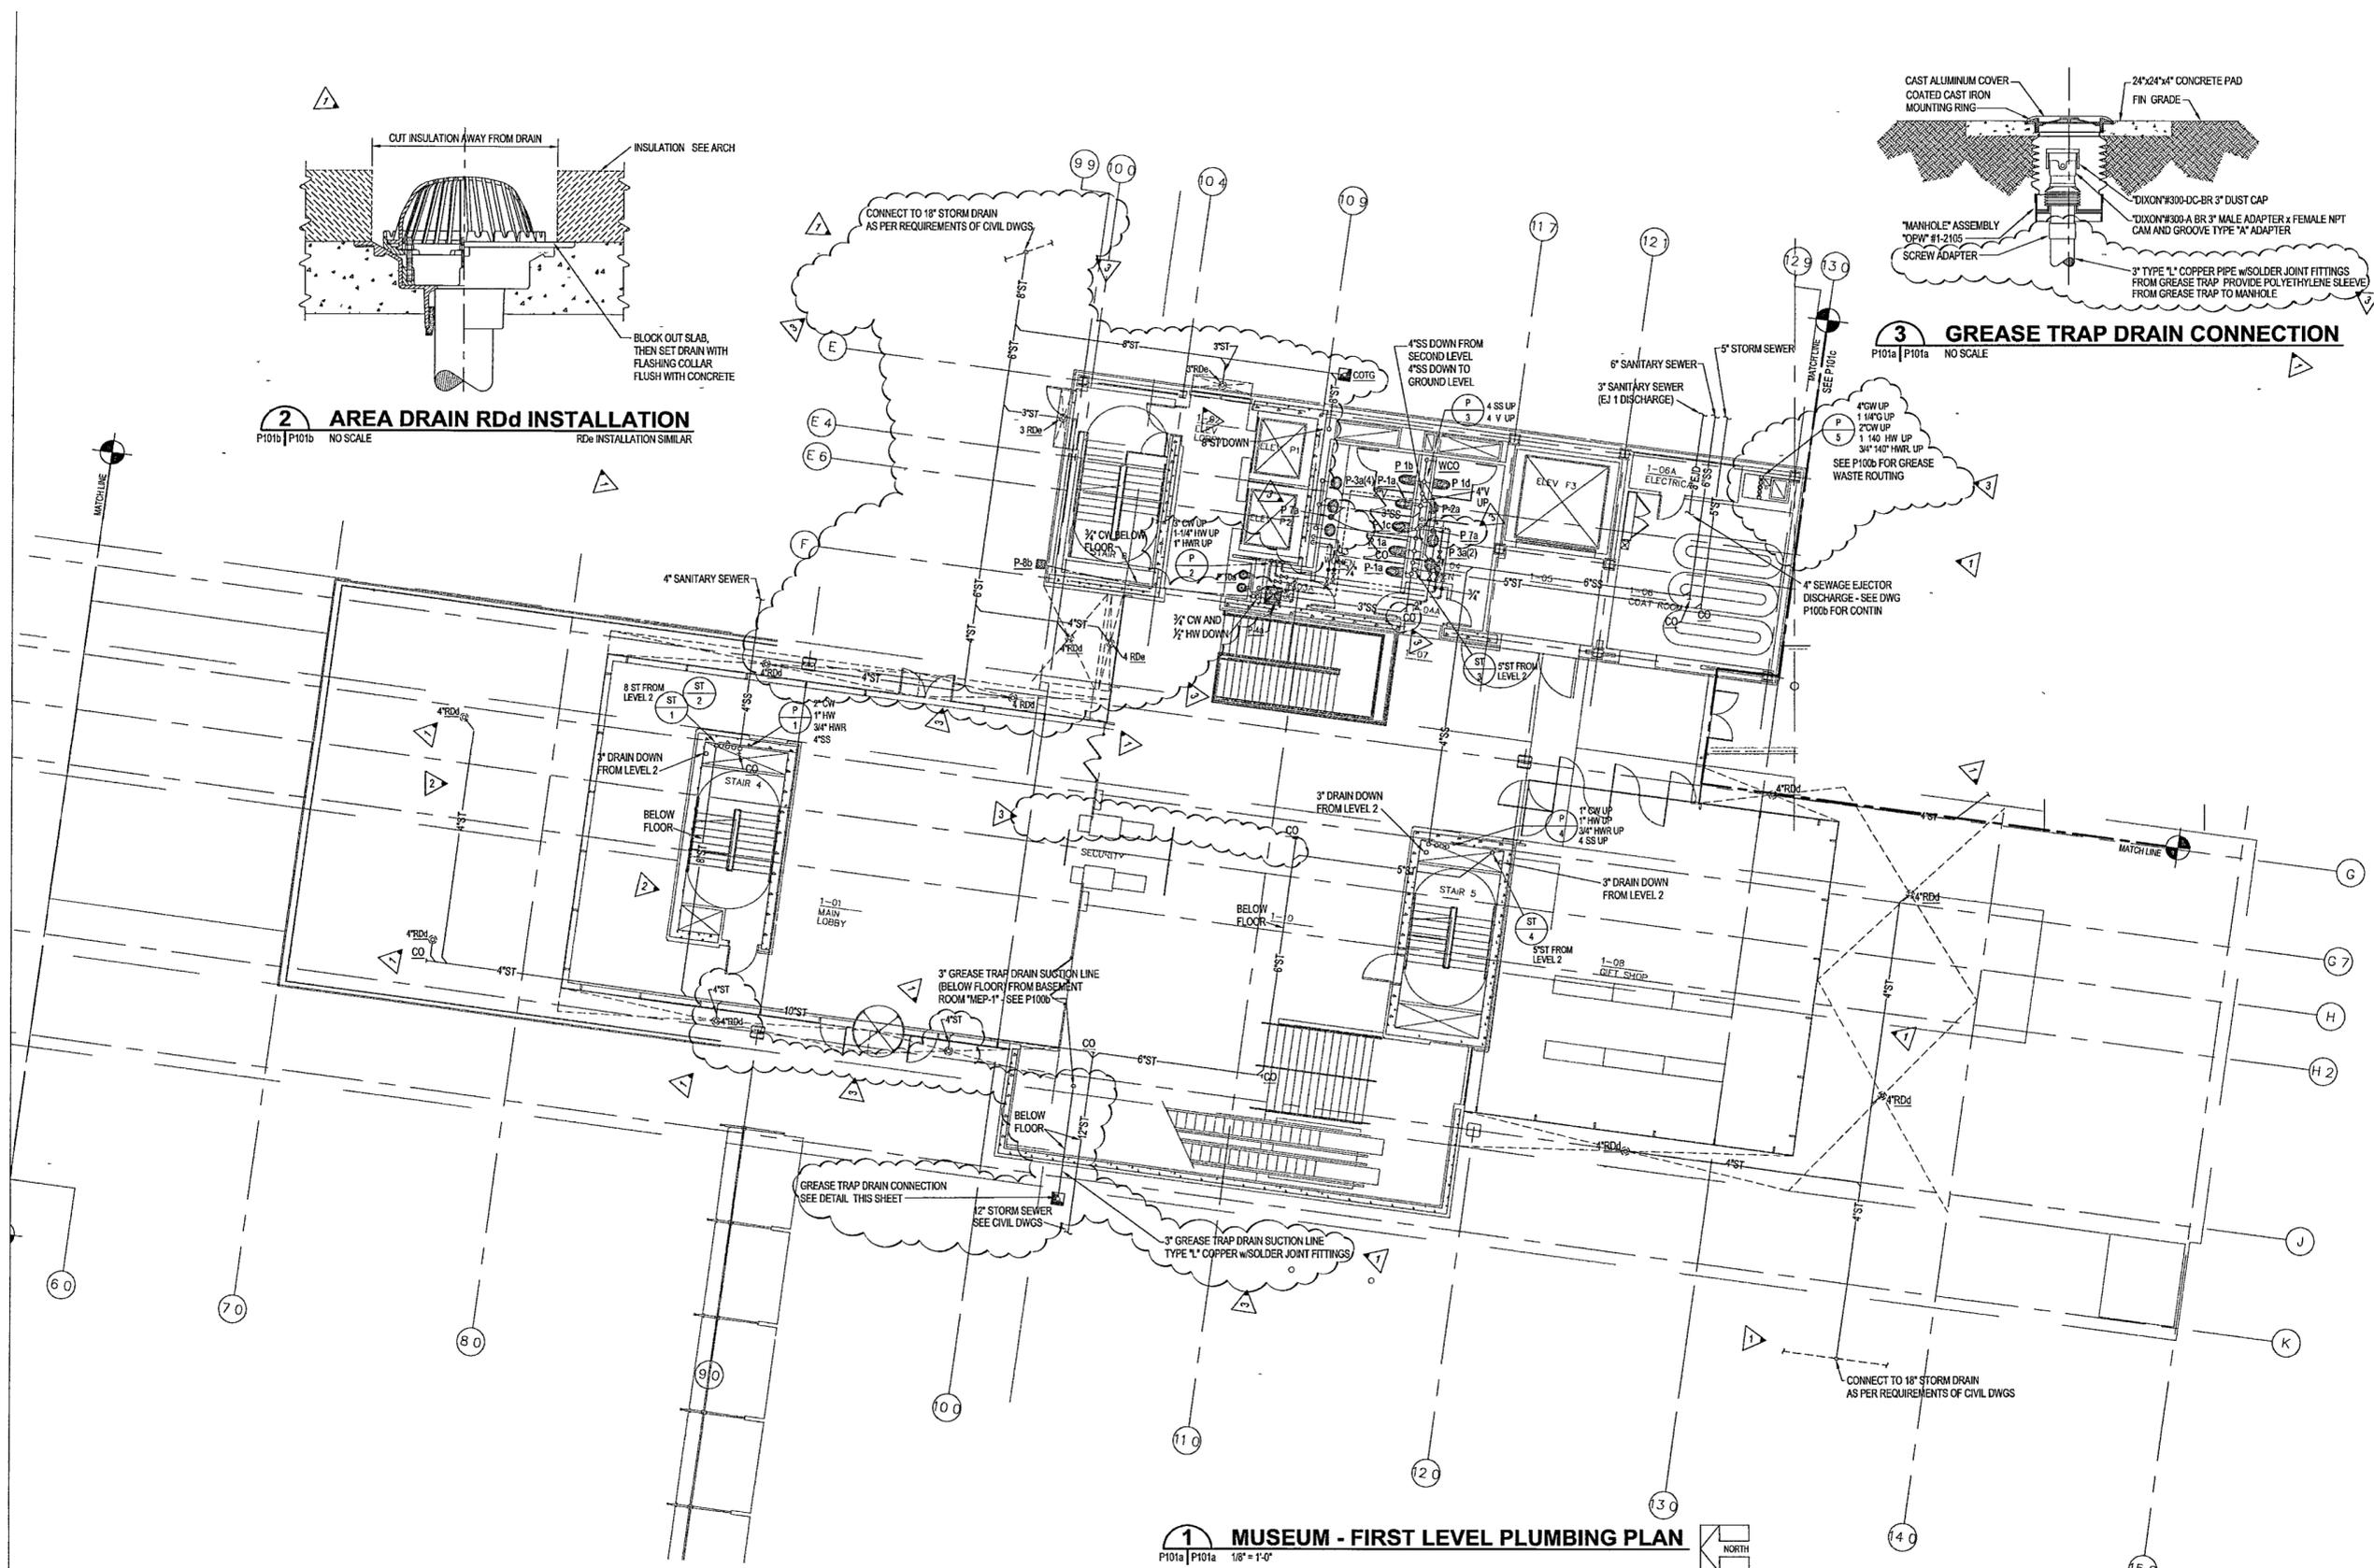

1 MUSEUM - FIRST LEVEL PLUMBING PLAN
P101a | P101a 1/8" = 1'-0"



99th