

**WILLIAM J CLINTON
PRESIDENTIAL
CENTER**

LITTLE ROCK, ARKANSAS

Architect
POLSHKE PARTNERSHIP LLP
320 West 13th Street
New York, New York 10014
212.807.7171

Coordinating Architects
POLK STANLEY YEARY ARCHITECTS Ltd
700 South Schiller Street
Little Rock Arkansas 72201
501.378.0878

WITSELL EVANS RASCO
901 West Third Street
Little Rock, Arkansas 72201
501.374.5300

WOODS CARADINE ARCHITECTS
2200 South Main Street
Little Rock, Arkansas 72206
501.374.4060

Landscape Architects
HARGREAVES ASSOCIATES
118 Magazine Street
Cambridge, Massachusetts 02139
617.861.0070

LANDSCAPE ARCHITECTURE, Inc.
2300 Coltondale Lane Suite 202
Little Rock, Arkansas 72202
501.374.5610


Structural Engineer
LESLIE E. ROBERTSON ASSOC. R/LP
30 Broad Street, 4th Floor
New York, New York 10004
212.750.9000

MEP Engineers
FLACK + KURTZ Inc.
475 Fifth Avenue
New York, New York 10017
212.532.9600


CROMWELL ARCHITECTS ENGINEERS
101 South Spring Street
Little Rock, Arkansas 72201
501.372.2300

Curianwall Consultant
R. A. HEINTGES ARCHITECTS
126 Fifth Avenue, 9th Floor
New York, New York 10011
212.652.2966

100% PLUMBING
CONSTRUCTION DRAWINGS
ISSUE - JULY 1, 2002

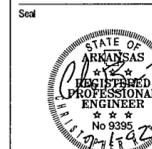

Issue	Date
100% Construction Documents	09/27/02
90% Progress Printing	08/30/02
General Revisions ASI #3	9/Aug 02
Plumbing Contract Documents	07/01/02
100% Design Development Titles as part of P101c	03/01/02

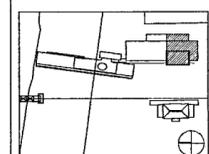

Job No: POLSHEK & PARTNERS ARCH 9908
CROMWELL LAE 99-114

Scale: 1/8" = 1'-0"

Date: JULY 01, 2002


Title: **ARCHIVES
GROUND LEVEL
PLUMBING
PARTIAL PLAN**

Sheet No:

P101d



FOR OFFICIAL USE ONLY

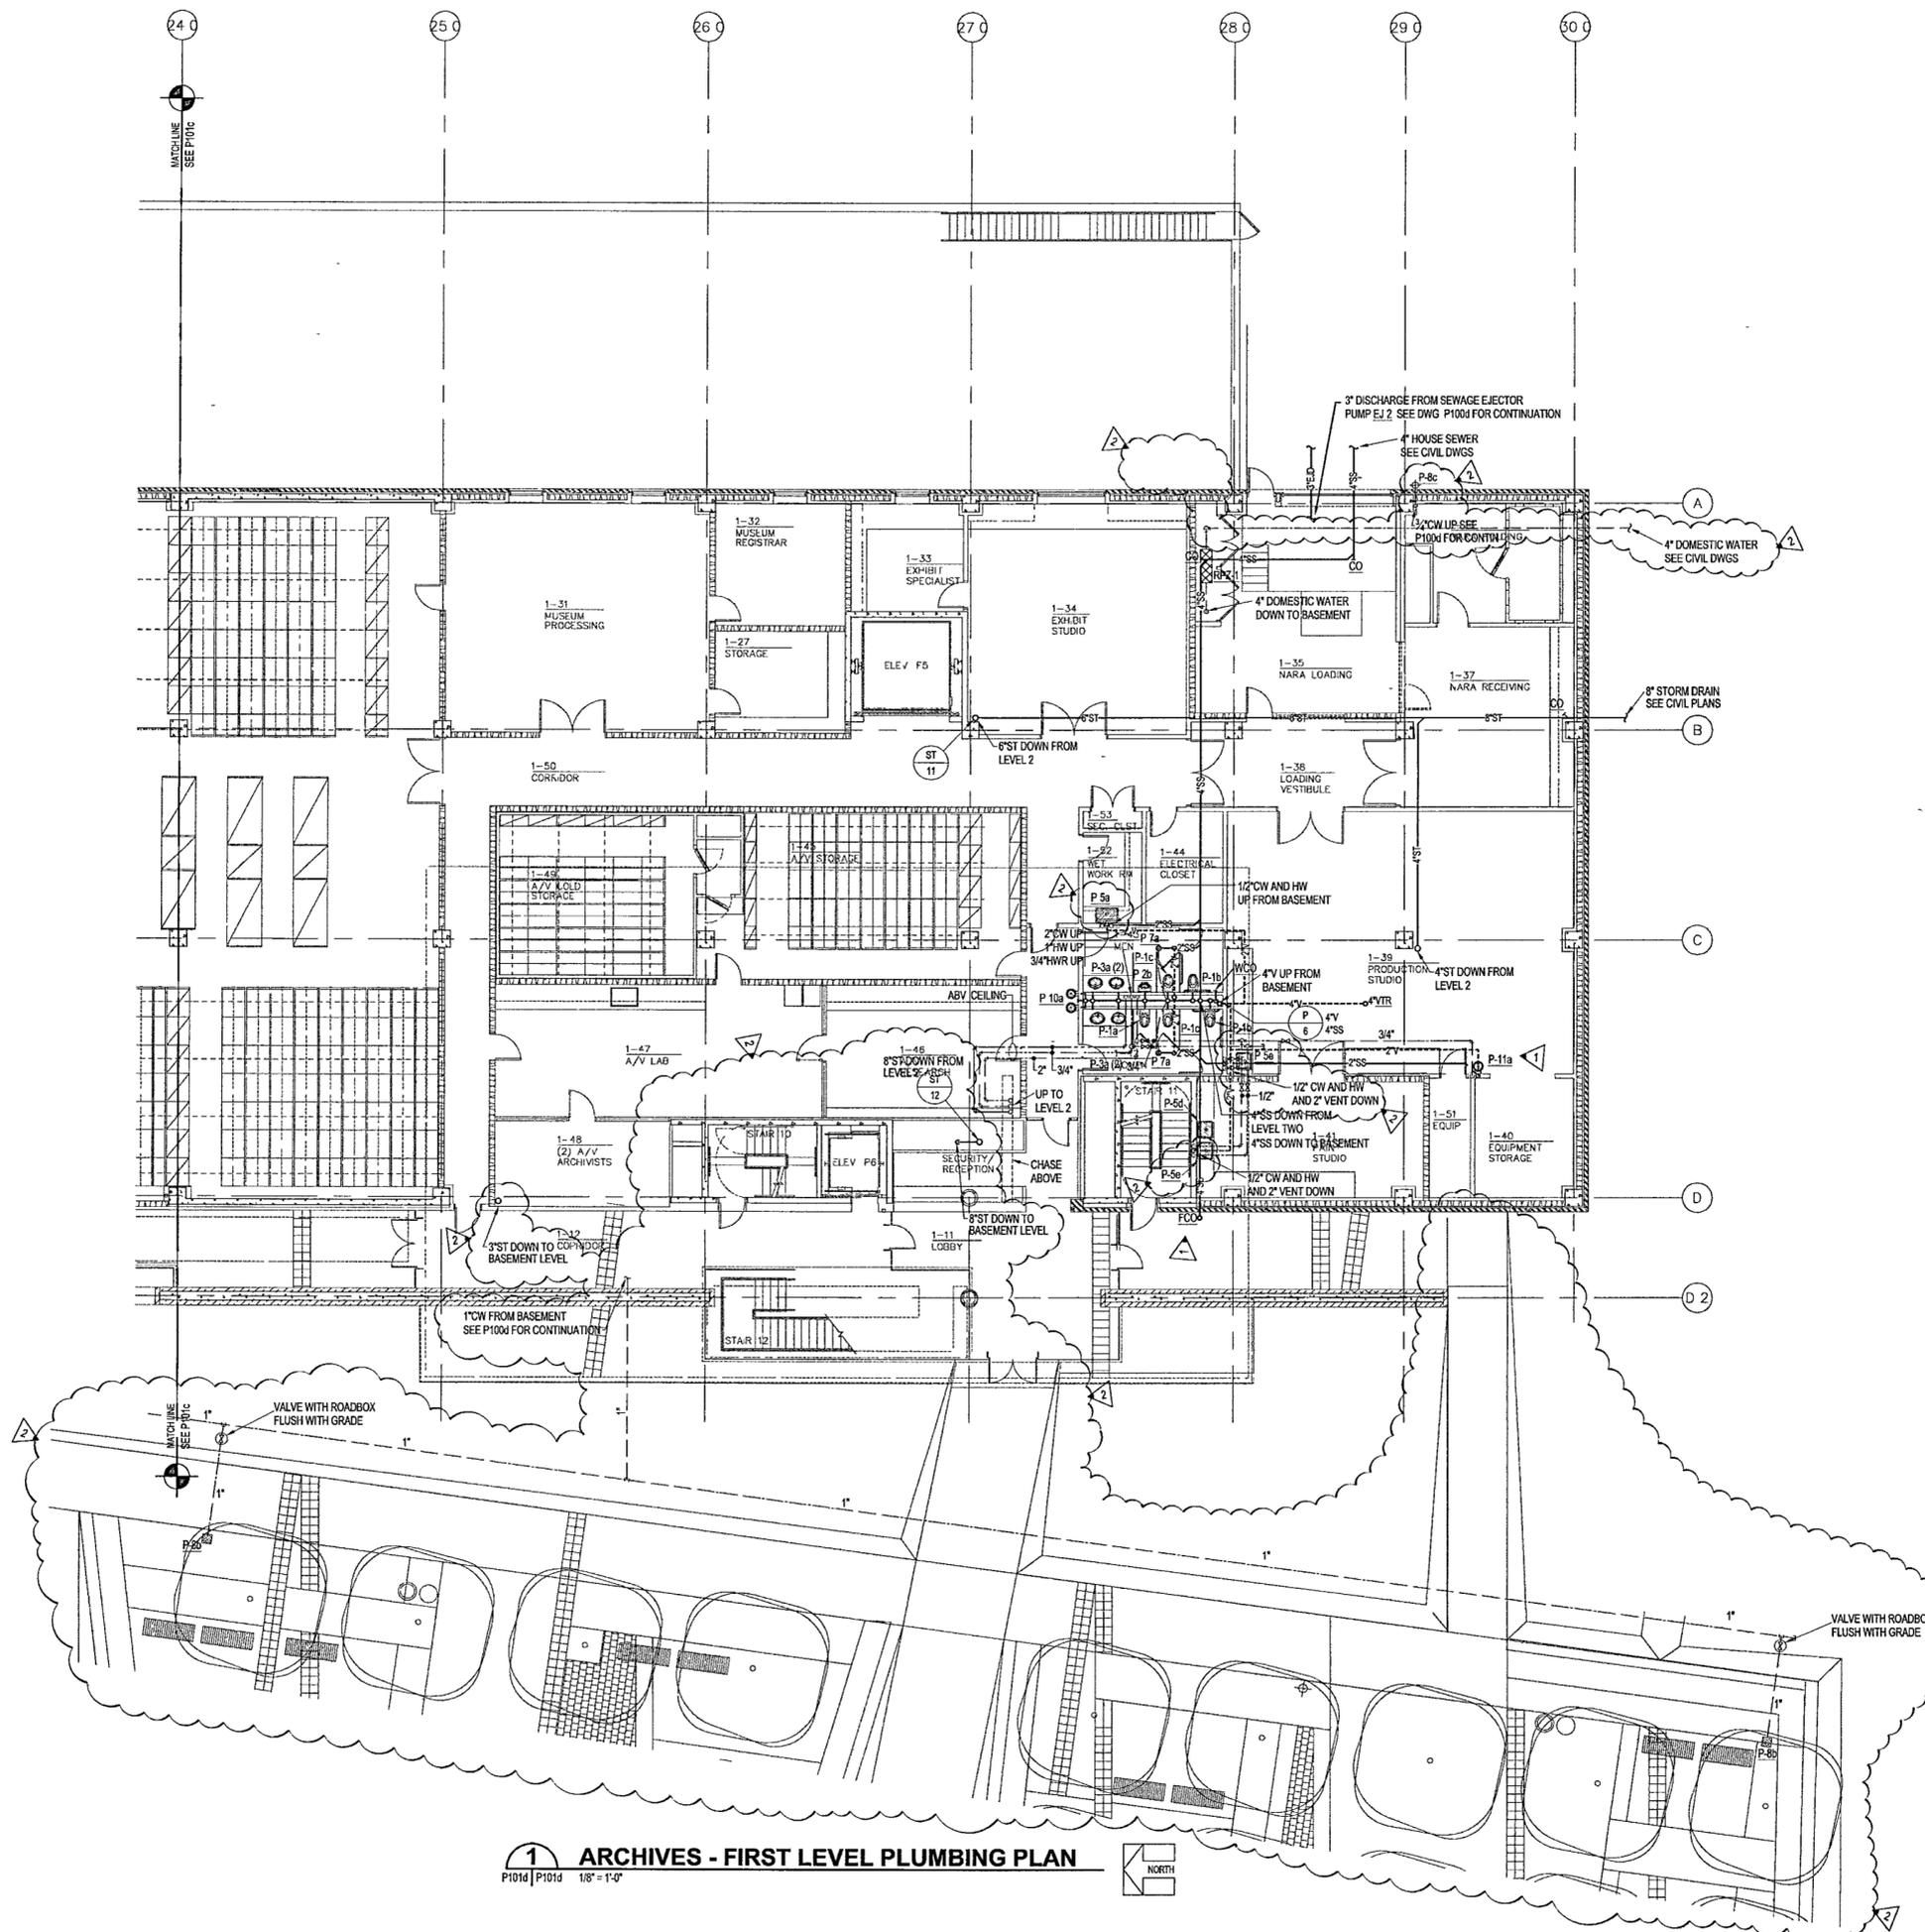

1 ARCHIVES - FIRST LEVEL PLUMBING PLAN
P101d | P101j 1/8" = 1'-0"



1-24-B