

WILLIAM J CLINTON  
PRESIDENTIAL  
CENTER

LITTLE ROCK, ARKANSAS

Architect

POLSHEK PARTNERSHIP LLP  
320 West 13th Street  
New York, New York 10014  
212.607.7171

Coordinating Architects

POLK STANLEY YEARY ARCHITECTS Ltd  
700 South Schiller Street  
Little Rock, Arkansas 72201  
501.378.0878

WITSELL EVANS RASCO  
801 West Third Street  
Little Rock, Arkansas 72201  
501.374.5300

WOODS CARADINE ARCHITECTS  
2200 South Main Street  
Little Rock, Arkansas 72206  
501.374.4060

Landscape Architects

HARGREAVES ASSOCIATES  
118 Magazine Street  
Cambridge, Massachusetts 02139  
617.661.0070

LANDSCAPE ARCHITECTURE, Inc.  
2300 Cottondale Lane Suite 202  
Little Rock, Arkansas 72202  
501.374.5510

Structural Engineer

LESLIE E. ROBERTSON ASSOC., RLP  
30 Broad Street, 47th Floor  
New York, New York 10004  
212.750.8000

MEP Engineers

FLACK + KURTZ, Inc.  
475 Fifth Avenue  
New York, New York 10017  
212.532.9600

CROMWELL ARCHITECTS ENGINEERS

101 South Spring Street  
Little Rock, Arkansas 72201  
501.372.2900

Curtilage Consultant


R. A. HEINTGES ARCHITECTS  
128 Fifth Avenue, 9th Floor  
New York, New York 10011  
212.652.2956

100% PLUMBING  
CONSTRUCTION DRAWINGS  
ISSUE - JULY 1, 2002

Seal



100% Construction Documents	09/27/02
90% Progress Printing	09/30/02
Plumbing Contract Documents	07/01/02
100% Design Development	03/01/02
Issue	Date

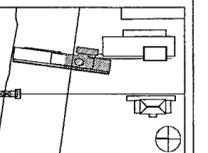

Job No. POLSHEK & PARTNERS ARCH 0008

CROMWELL AE 99-114

Scale 1/8" = 1'-0"


Date

Title  
MUSEUM  
SECOND LEVEL  
PLUMBING  
PARTIAL PLAN

Sheet No.

P102b

FOR OFFICIAL USE ONLY

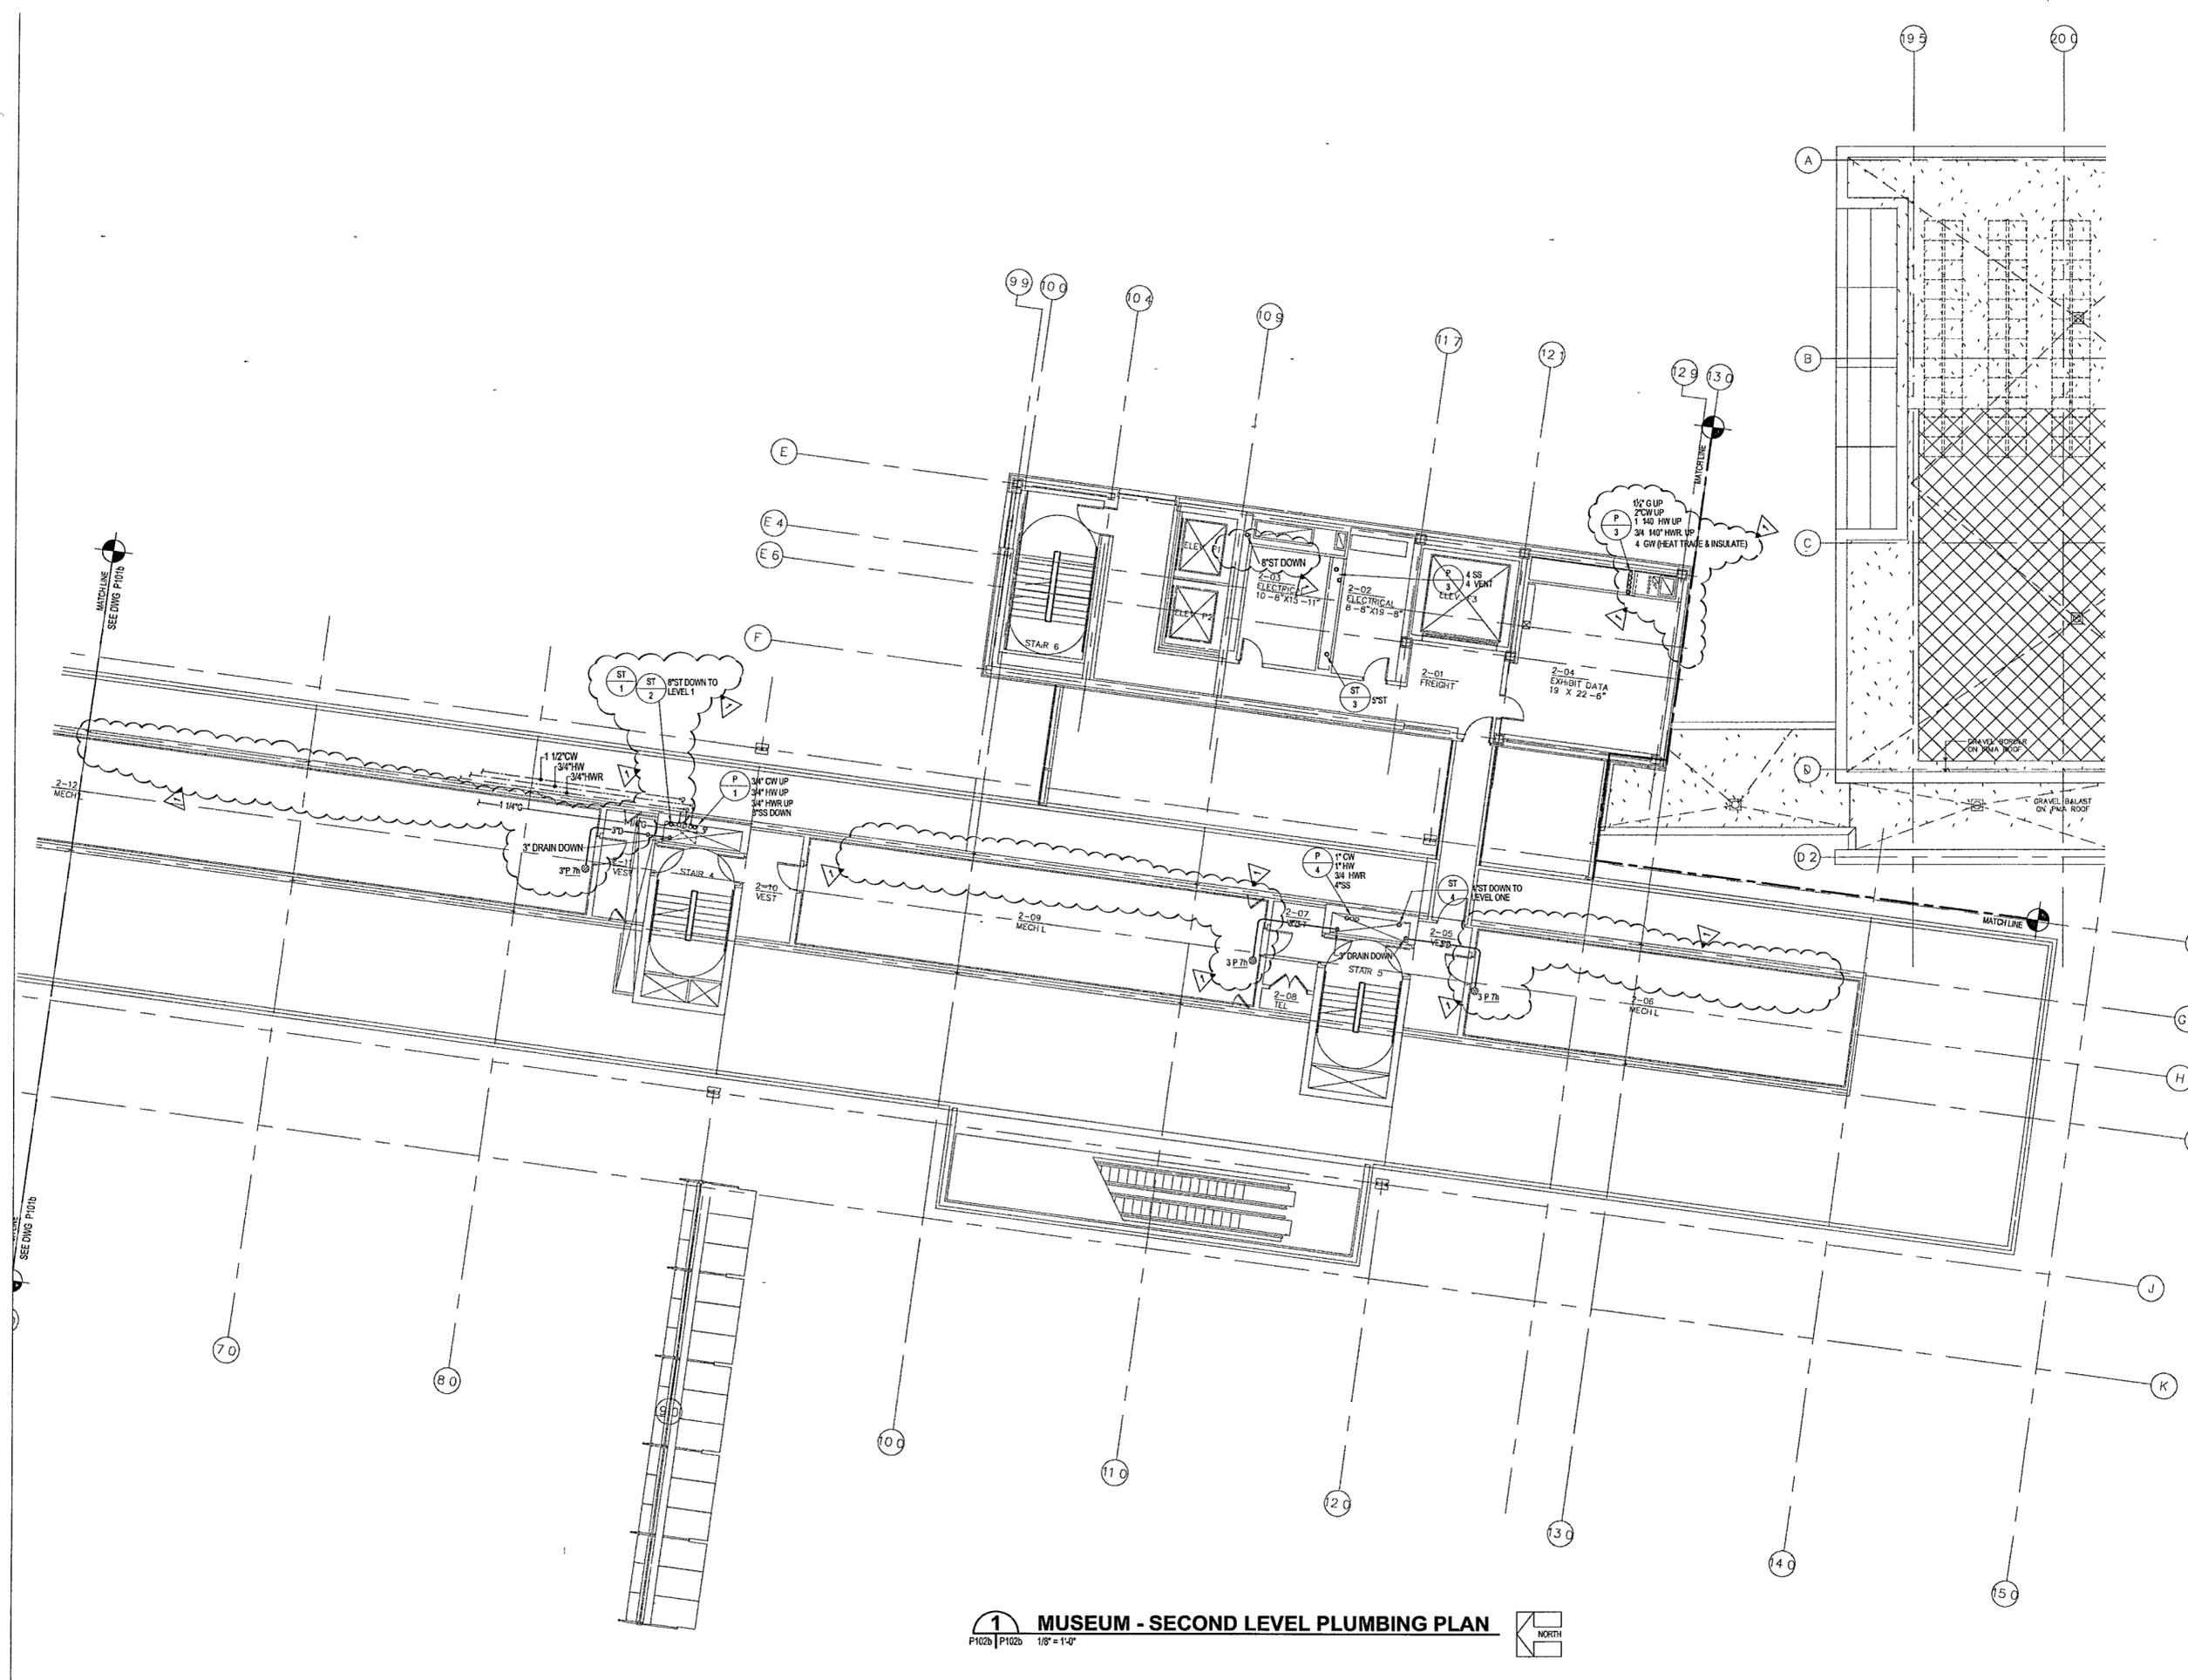

**1 MUSEUM - SECOND LEVEL PLUMBING PLAN**  
P102b | P102b 1/8" = 1'-0"



1448