

**WILLIAM J CLINTON
PRESIDENTIAL
CENTER**

LITTLE ROCK, ARKANSAS

Architect
POLSHEK PARTNERSHIP LLP
320 West 13th Street
New York, New York 10014
212.807.7171

Coordinating Architects
POLK STANLEY YEARY ARCHITECTS Ltd
700 South Schaller Street
Little Rock, Arkansas 72201
501.378.0878

WITSELL EVANS RASCO
801 West Third Street
Little Rock, Arkansas 72201
501.374.5300

WOODS CARADINE ARCHITECTS
2200 South Main Street
Little Rock, Arkansas 72206
501.374.4060

Landscape Architects
HARGREAVES ASSOCIATES
118 Magazine Street
Cambridge Massachusetts 02139
617.661.0070

LANDSCAPE ARCHITECTURE Inc.
2300 Cottondale Lane Suite 202
Little Rock, Arkansas 72202
501.374.5610

Structural Engineer
LESLIE E. ROBERTSON ASSOC. P.L.P.
30 Broad Street, 47th Floor
New York, New York 10004
212.759.9000

MEP Engineers
FLACK + KURTZ Inc.
475 Fifth Avenue
New York, New York 10017
212.532.9600


CROMMELL ARCHITECTS ENGINEERS
101 South Spring Street
Little Rock, Arkansas 72201
501.372.2300

Curtilwall Consultant
R. A. HEINTGES ARCHITECTS
126 Fifth Avenue, 9th Floor
New York, New York 10011
212.652.2965

**100% PLUMBING
CONSTRUCTION DRAWINGS
ISSUE - JULY 1, 2002**



Issue	Date
100% Construction Documents	09/27/02
90% Progress Printing	09/30/02
Plumbing Contract Documents	07/01/02
100% Design Development Titled as part of P102c	03/01/02

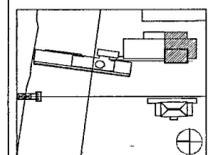

Job No POLSHEK & PARTNERS ARCH 9908
CROMMELL AE 99-114

 
Scale 1/8" = 1'-0"

Date JULY 01, 2002


Title **ARCHIVES
ROOF/SECOND LEVEL
PLUMBING
PARTIAL PLAN**

Sheet No

P102d



FOR OFFICIAL USE ONLY

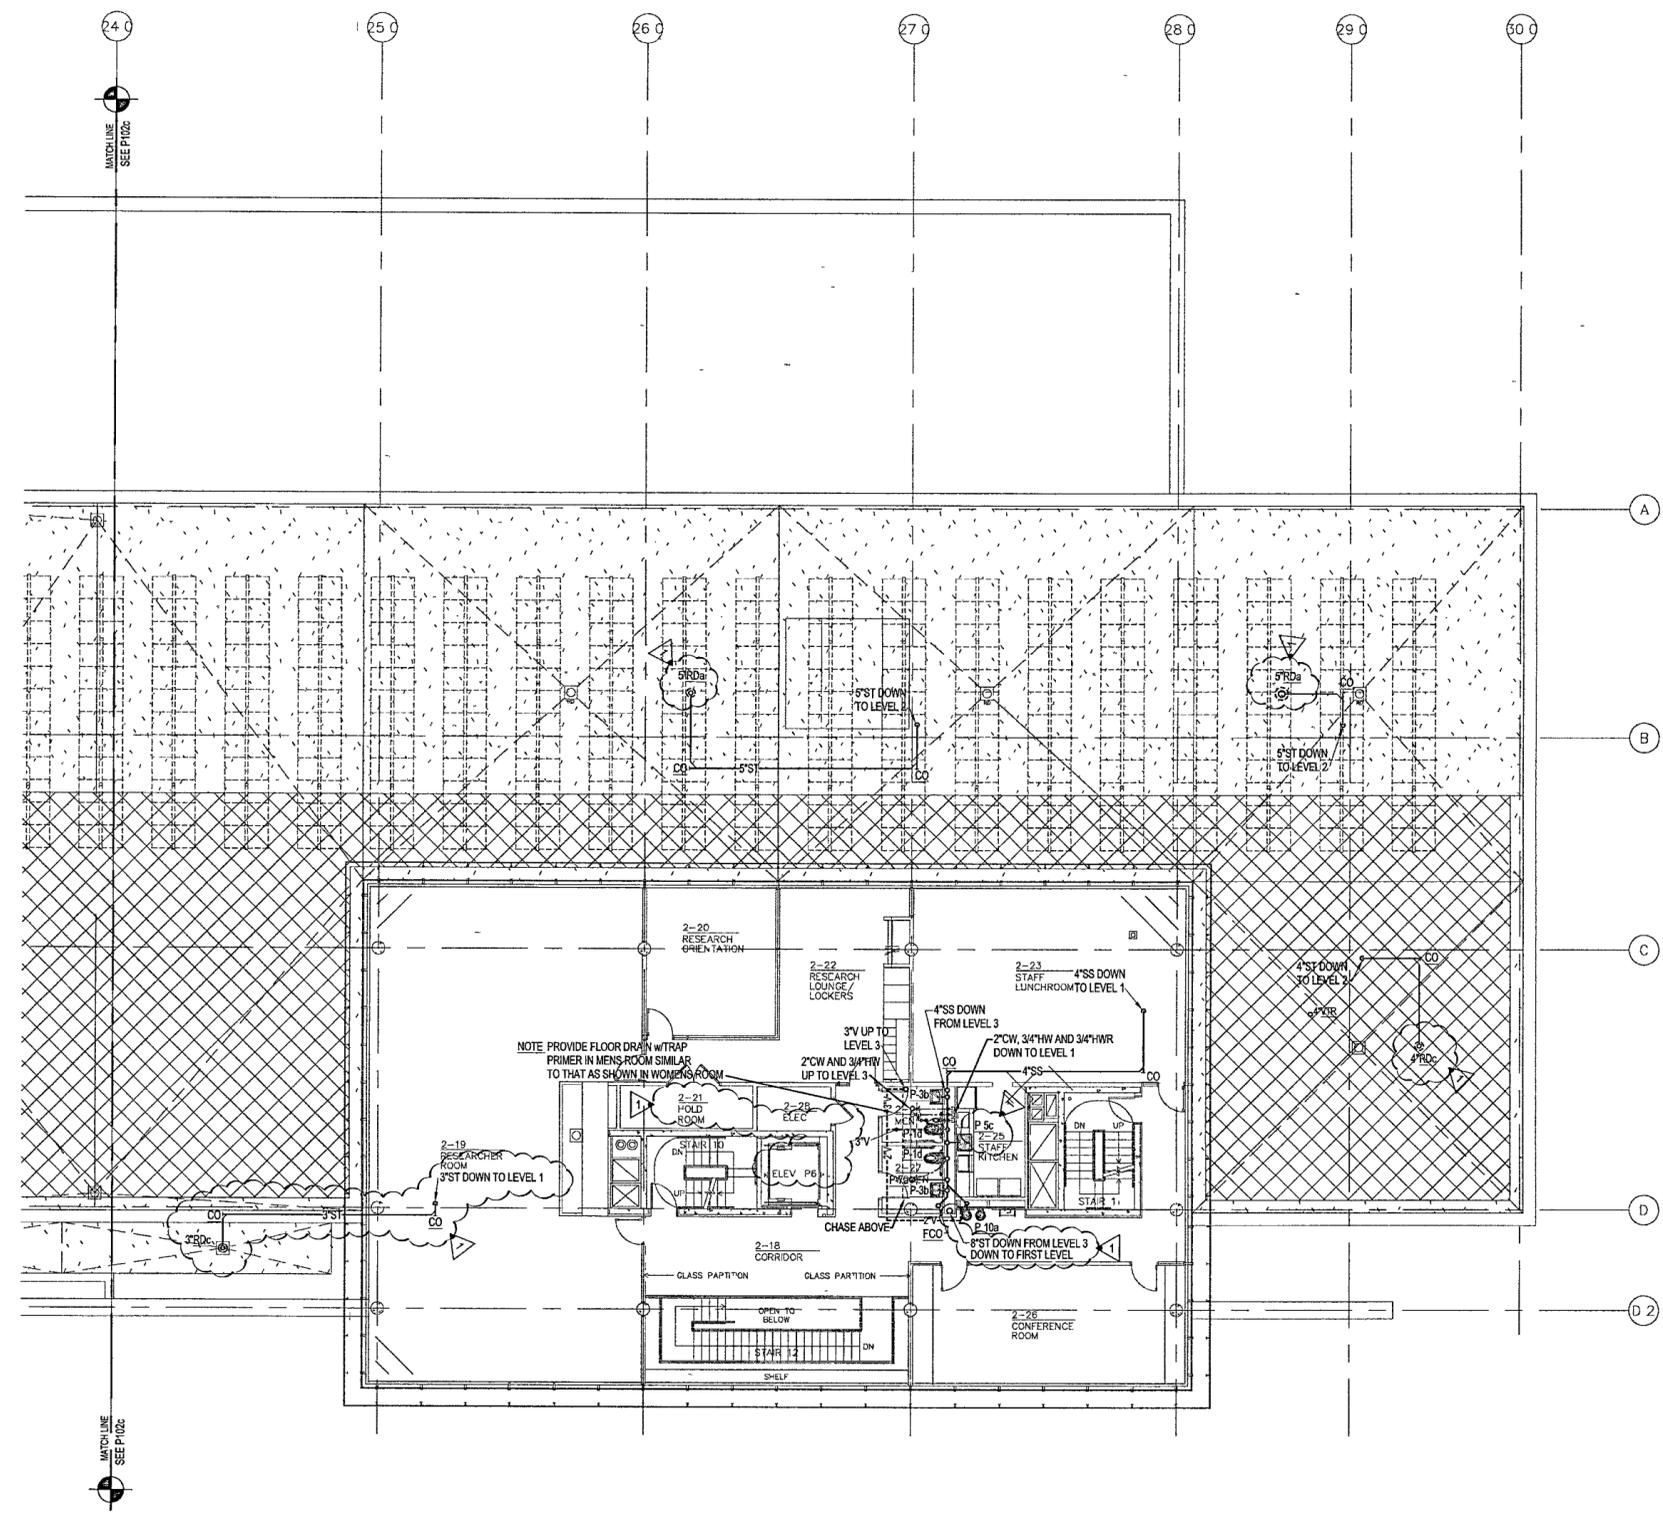

1 ARCHIVES - ROOF/SECOND LEVEL PLUMBING PLAN
FP102c FP102c 1/8" = 1'-0"



1448