

**WILLIAM J CLINTON  
PRESIDENTIAL  
CENTER**

LITTLE ROCK, ARKANSAS

Architect  
POLSHKE PARTNERSHIP LLP  
320 West 13th Street  
New York, New York 10014  
212.807.7171

Coordinating Architects  
POLK STANLEY YEARY ARCHITECTS Ltd  
700 South Schaller Street  
Little Rock, Arkansas 72201  
501.378.8878

WITSELL EVANS RASCO  
901 West Third Street  
Little Rock, Arkansas 72201  
501.374.5300

WOODS GARADINE ARCHITECTS  
2200 South Main Street  
Little Rock, Arkansas 72206  
501.374.4060

Landscape Architects  
HARGREAVES ASSOCIATES  
118 Magazine Street  
Cambridge, Massachusetts 02138  
617.661.0070

LANDSCAPE ARCHITECTURE, Inc.  
2300 Cotterdale Lane Suite 202  
Little Rock, Arkansas 72202  
501.374.5810

Structural Engineer  
LESLIE E. ROBERTSON ASSOC. RLLP  
30 Broad Street, 47th Floor  
New York, New York 10004  
212.750.9000

MEP Engineers  
FLACK + KURTZ Inc.  
475 Fifth Avenue  
New York, New York 10017  
212.532.9800


CROMWELL ARCHITECTS ENGINEERS  
101 South Spring Street  
Little Rock, Arkansas 72201  
501.372.2900

Contractor Consultant  
R. A. HEINTGES ARCHITECTS  
128 Fifth Avenue, 9th Floor  
New York, New York 10011  
212.652.2966

**100% PLUMBING  
CONSTRUCTION DRAWINGS  
ISSUE - JULY 1, 2002**




Issue	Date
100% Construction Documents	08/27/02
90% Progress Printing	08/30/02
General Revisions ASI #6	26 Aug 02
General Revisions ASI #3	9 Aug 02
Plumbing Contract Documents	07/01/02
100% Design Development	03/01/02

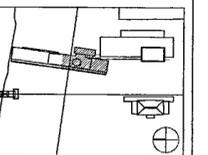

Job No: POLSHEK & PARTNERS ARCH 9908  
CROMWELL A/E 99-114  
Scale: 1/8" = 1'-0"  
Date: JULY 01, 2002

Title: **MUSEUM  
LOWER LEVEL  
PLUMBING  
PARTIAL PLAN**

Sheet No: **P103b**

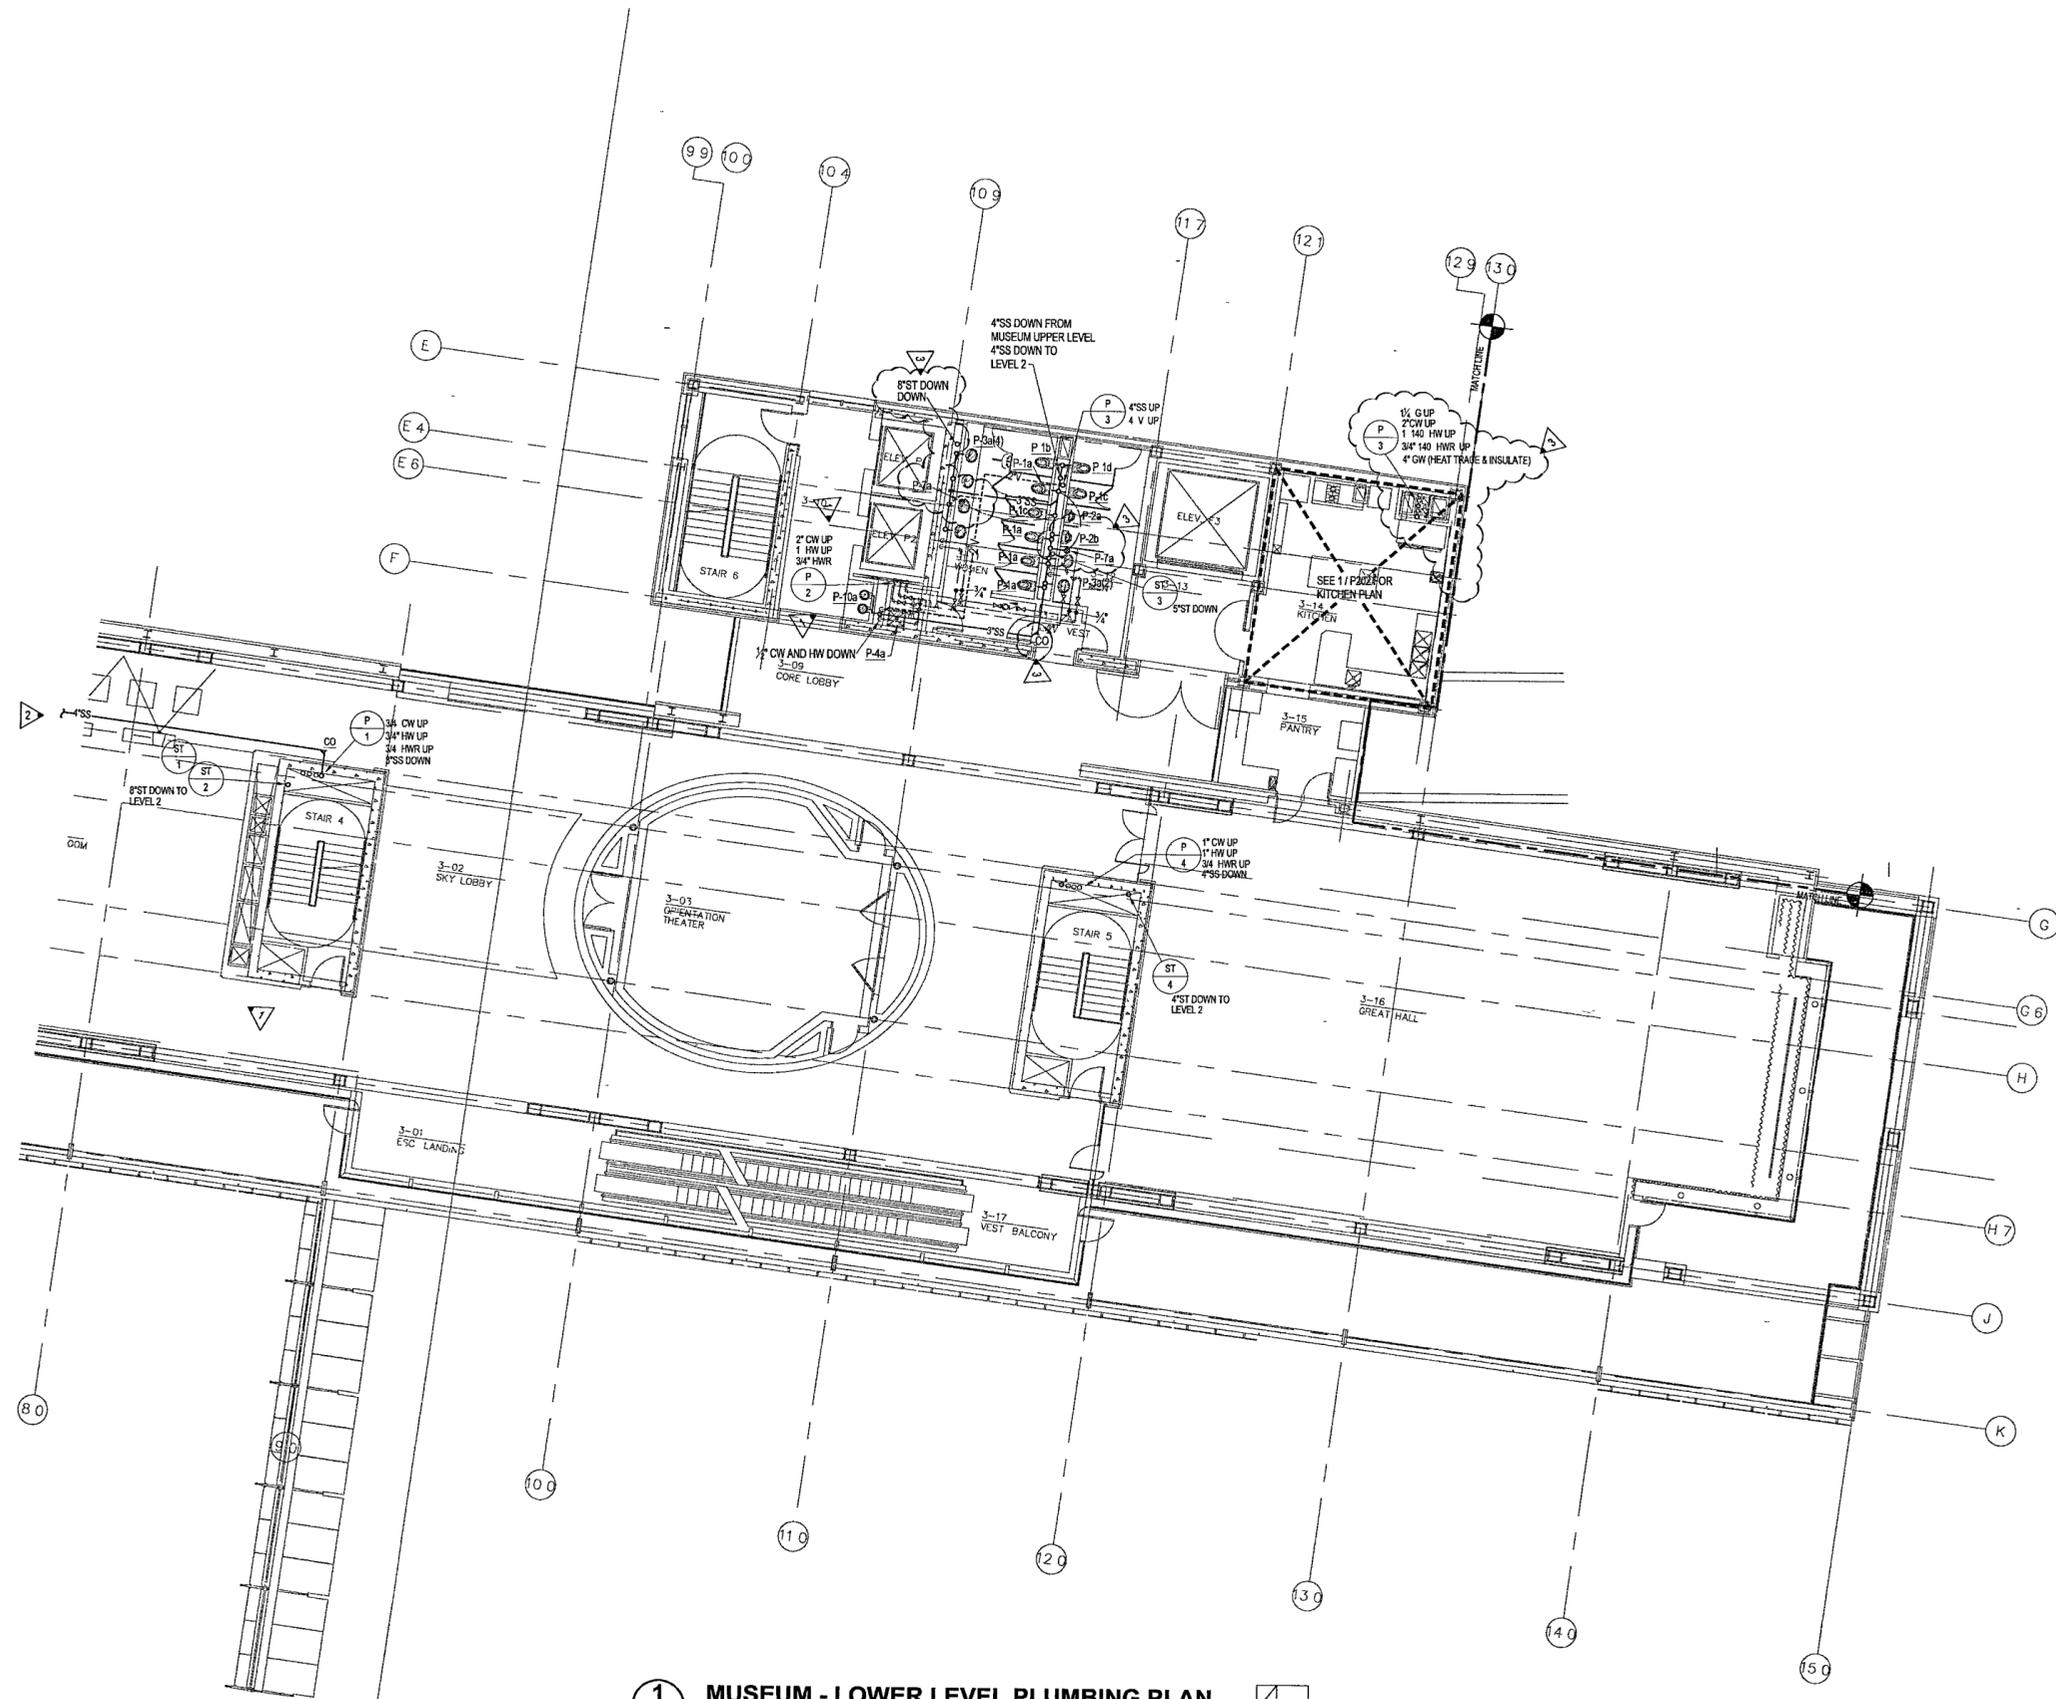

**1 MUSEUM - LOWER LEVEL PLUMBING PLAN**  
P103b P103b 1/8" = 1'-0" NORTH

FOR OFFICIAL USE ONLY